

Notes: All door hardware (closers, hinges, locksets, etc.) for fire rated assemblies shall be U.C. listed for the rating being used.

OPENING SCHEDULE

NO.	TYPE	DEPTH	SIZE		T	MAT.	TYPE	GLASS	FIRE RATING	THRESH. HOLD	HARDWARE	SPECIAL INSERT	NOTE	HEAD	JAMB	SILL	REMARKS
			W.	H.													
1a	(E)		3'-0"	6'-8"	1 3/4"	WD	B		1 1/2 hr.					11E	11E		
2a	WD-1		3'-0"	6'-8"	1 3/4"	WD	B		1 1/2 hr.					4H	4H		
3a														4H	4H		
4a														4H	4H		
5a														4H	4H		
6a														4H	4H		
7a														4H	4H		
8a														4H	4H		
9a	WD-1		3'-0"	6'-8"	1 3/4"	WD	B		1 1/2 hr.					4H	4H		
10a	(E)													(E)	(E)		
11a	WD-1		3'-0"	6'-8"	1 3/4"	WD	B		1 1/2 hr.					4H	4H		
12a	WD-1		3'-0"	6'-8"	1 3/4"	WD	B		1 1/2 hr.					4H	4H		
13a	WD-1		3'-0"	6'-8"	1 3/4"	WD	B		1 1/2 hr.					4H	4H		
14a	WD-1		3'-0"	6'-8"	1 3/4"	WD	B		1 1/2 hr.					4H	4H		
15a	WD-1		3'-0"	6'-8"	1 3/4"	WD	B		1 1/2 hr.					4H	4H		
16a	WD-1		3'-0"	6'-8"	1 3/4"	WD	B		1 1/2 hr.					4H	4H		
17a	WD-1		3'-0"	6'-8"	1 3/4"	WD	B		1 1/2 hr.					4H	4H		
18a	WD-1		3'-0"	6'-8"	1 3/4"	WD	B		1 1/2 hr.					4H	4H		
19a	WD-1		3'-0"	6'-8"	1 3/4"	WD	B		1 1/2 hr.					4H	4H		
20a	WD-1		3'-0"	6'-8"	1 3/4"	WD	B		1 1/2 hr.					4H	4H		
21a	WD-1		3'-0"	6'-8"	1 3/4"	WD	B		1 1/2 hr.					4H	4H		
22a	WD-1		3'-0"	6'-8"	1 3/4"	WD	B		1 1/2 hr.					4H	4H		
23a	WD-1		3'-0"	6'-8"	1 3/4"	WD	B		1 1/2 hr.					4H	4H		

MODULAR CABINET SCHEDULE

BLDG.	ROOM NO.	GROUP NO.	DESCRIPTION	W.C. NO.	NO. REQ.	LENGTH	HEIGHT	DEPTH	ACCESS REQ.	W.C. GRADE	REMARKS
4	10	1	Tall storage cab.	402	3	48"	84"	12"		C	
			Tall storage cab.	401	1	24"	84"	12"		C	
			Tall storage cab.	402	3	48"	84"	12"		C	
			Tall storage cab.	402	1	76"	84"	12"		C	
11	10	1	Base cab.	102	1	36"	30"	24"		C	
			Tall storage cab.	402	2	42"	84"	24"		C	
13	10	1	Tall storage cab.	402	2	76"	84"	18"		P	Wood veneer
			Base cab.	102	2	30"	32"	18"		P	Wood veneer
19	10	1	Tall storage cab.	402	2	30"	84"	24"		C	
21	10	1	Base cab.	222	2	30"	30"	24"		C	
			Sink base cab.	150	1	76"	30"	24"		C	W/Removable toe base
			Wall hang cab.	302	2	30"	30"	12"		C	
			Wall hang cab.	302	1	76"	10"	12"		C	

MODULAR CABINET NOTES:

- Field verify all dimensions prior to installation.
- W.C. grades: C = custom, P = premium.
- All cabinets and counter tops are plastic lam. covered (U.C.N.).

DOOR NOTES

- All new door operating hardware shall be operable from the inside without the use of a key or special knowledge or effort.
- Manually operated edge or surface mounted flush and/or surface bolts shall not be installed on required exit doors.
- All new door operating hardware shall be exit type or push/pull activated.
- Thresholds shall not exceed 1/2" in height above the finished floor.
- For wall bumper See det.

FRAME TYPES



HM-1 WD-1 WD-2

DOOR TYPES


A HM B WD C WD

FRAME PROFILE TYPES

A HM B WD C WD

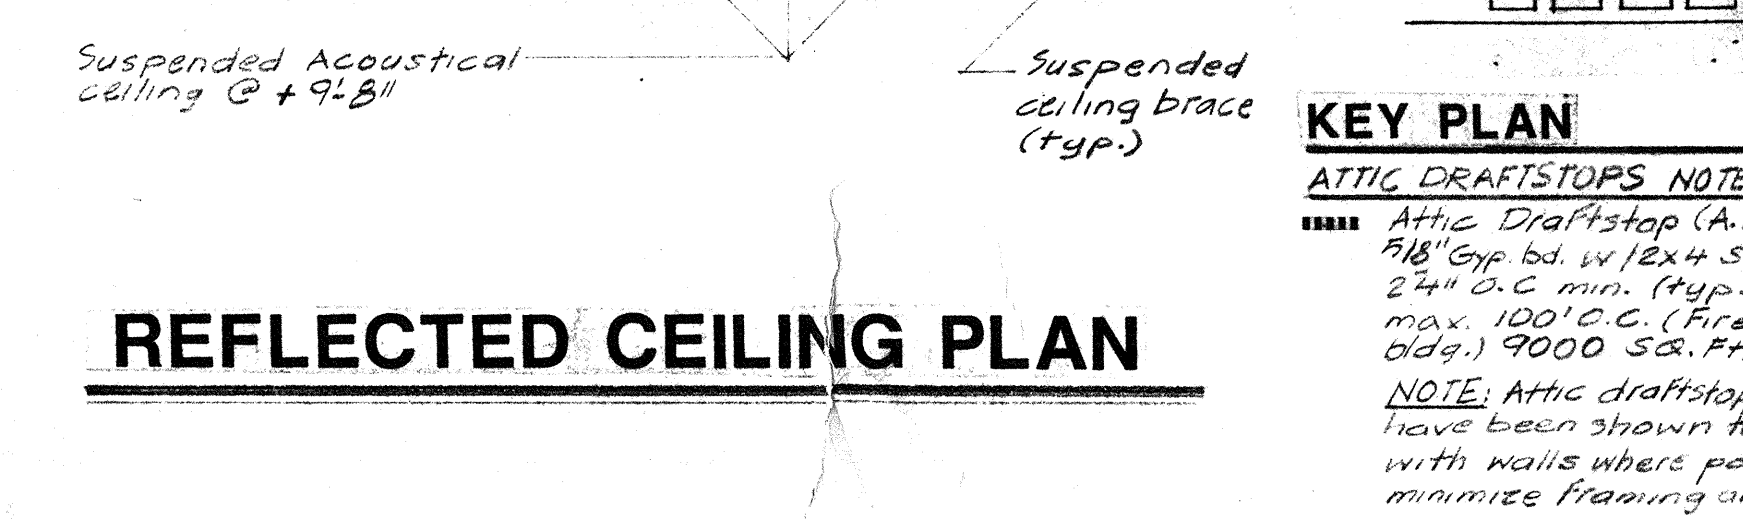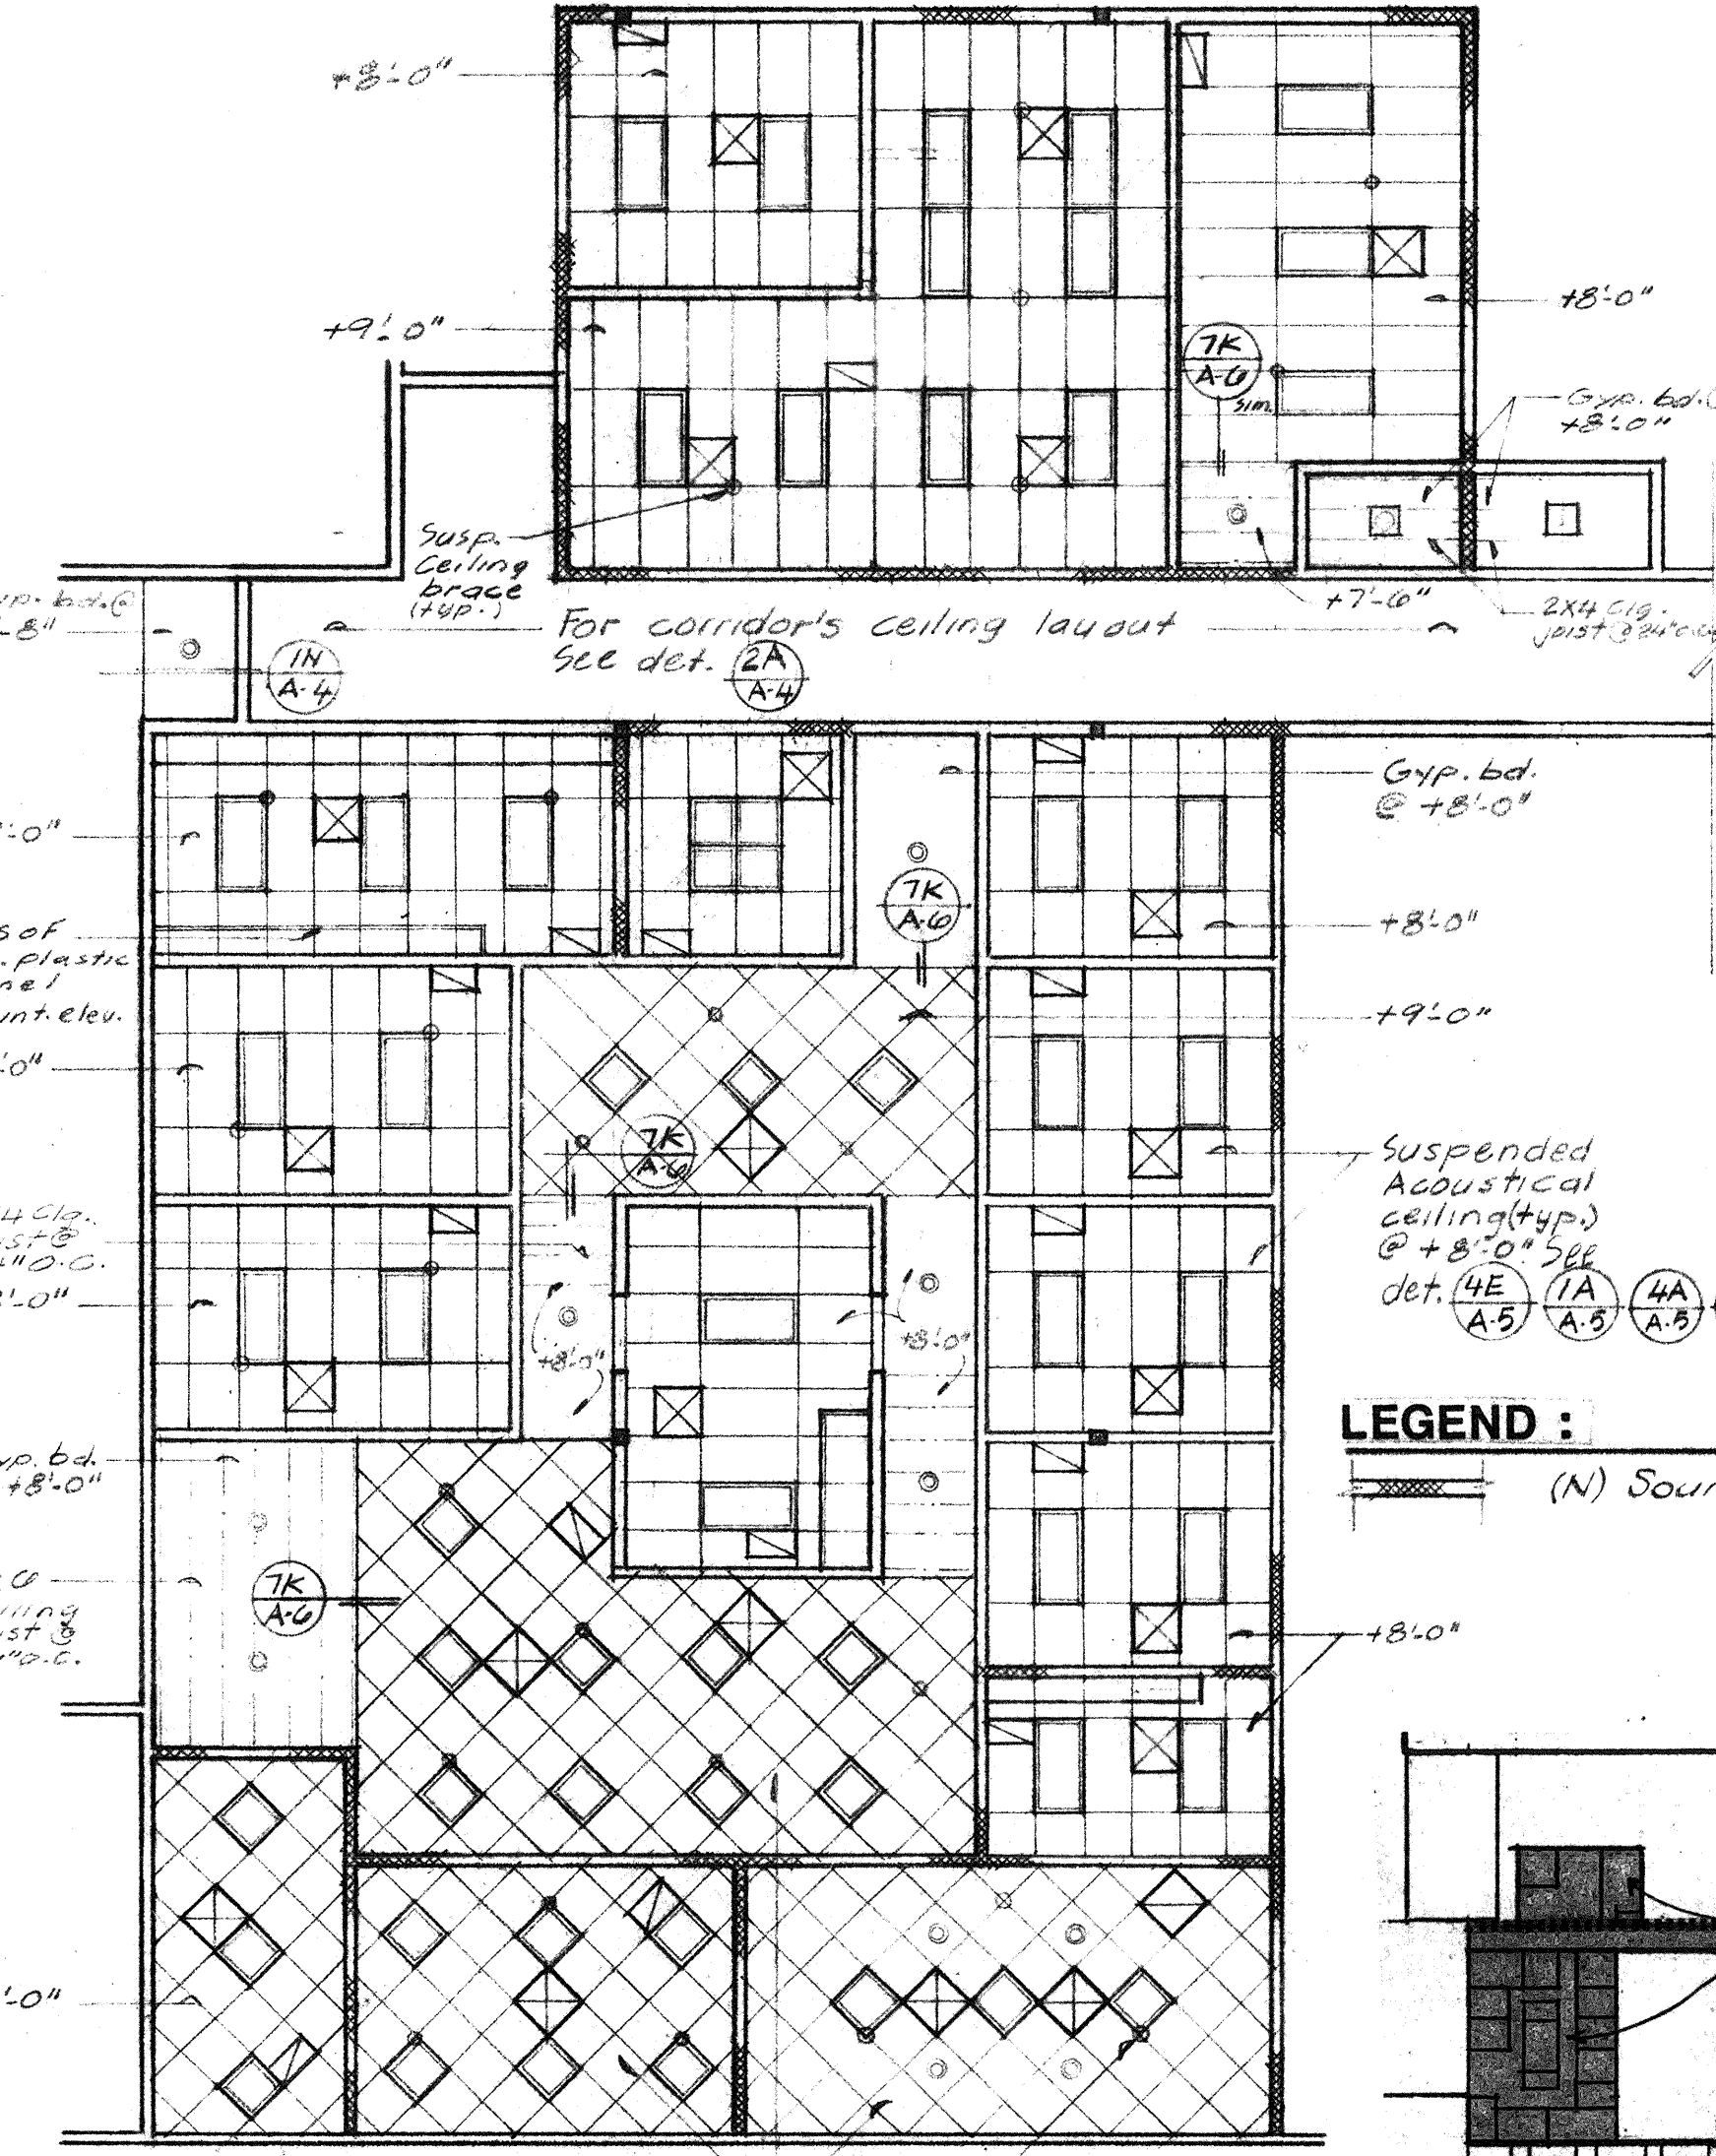

REFLECTED CEILING PLAN

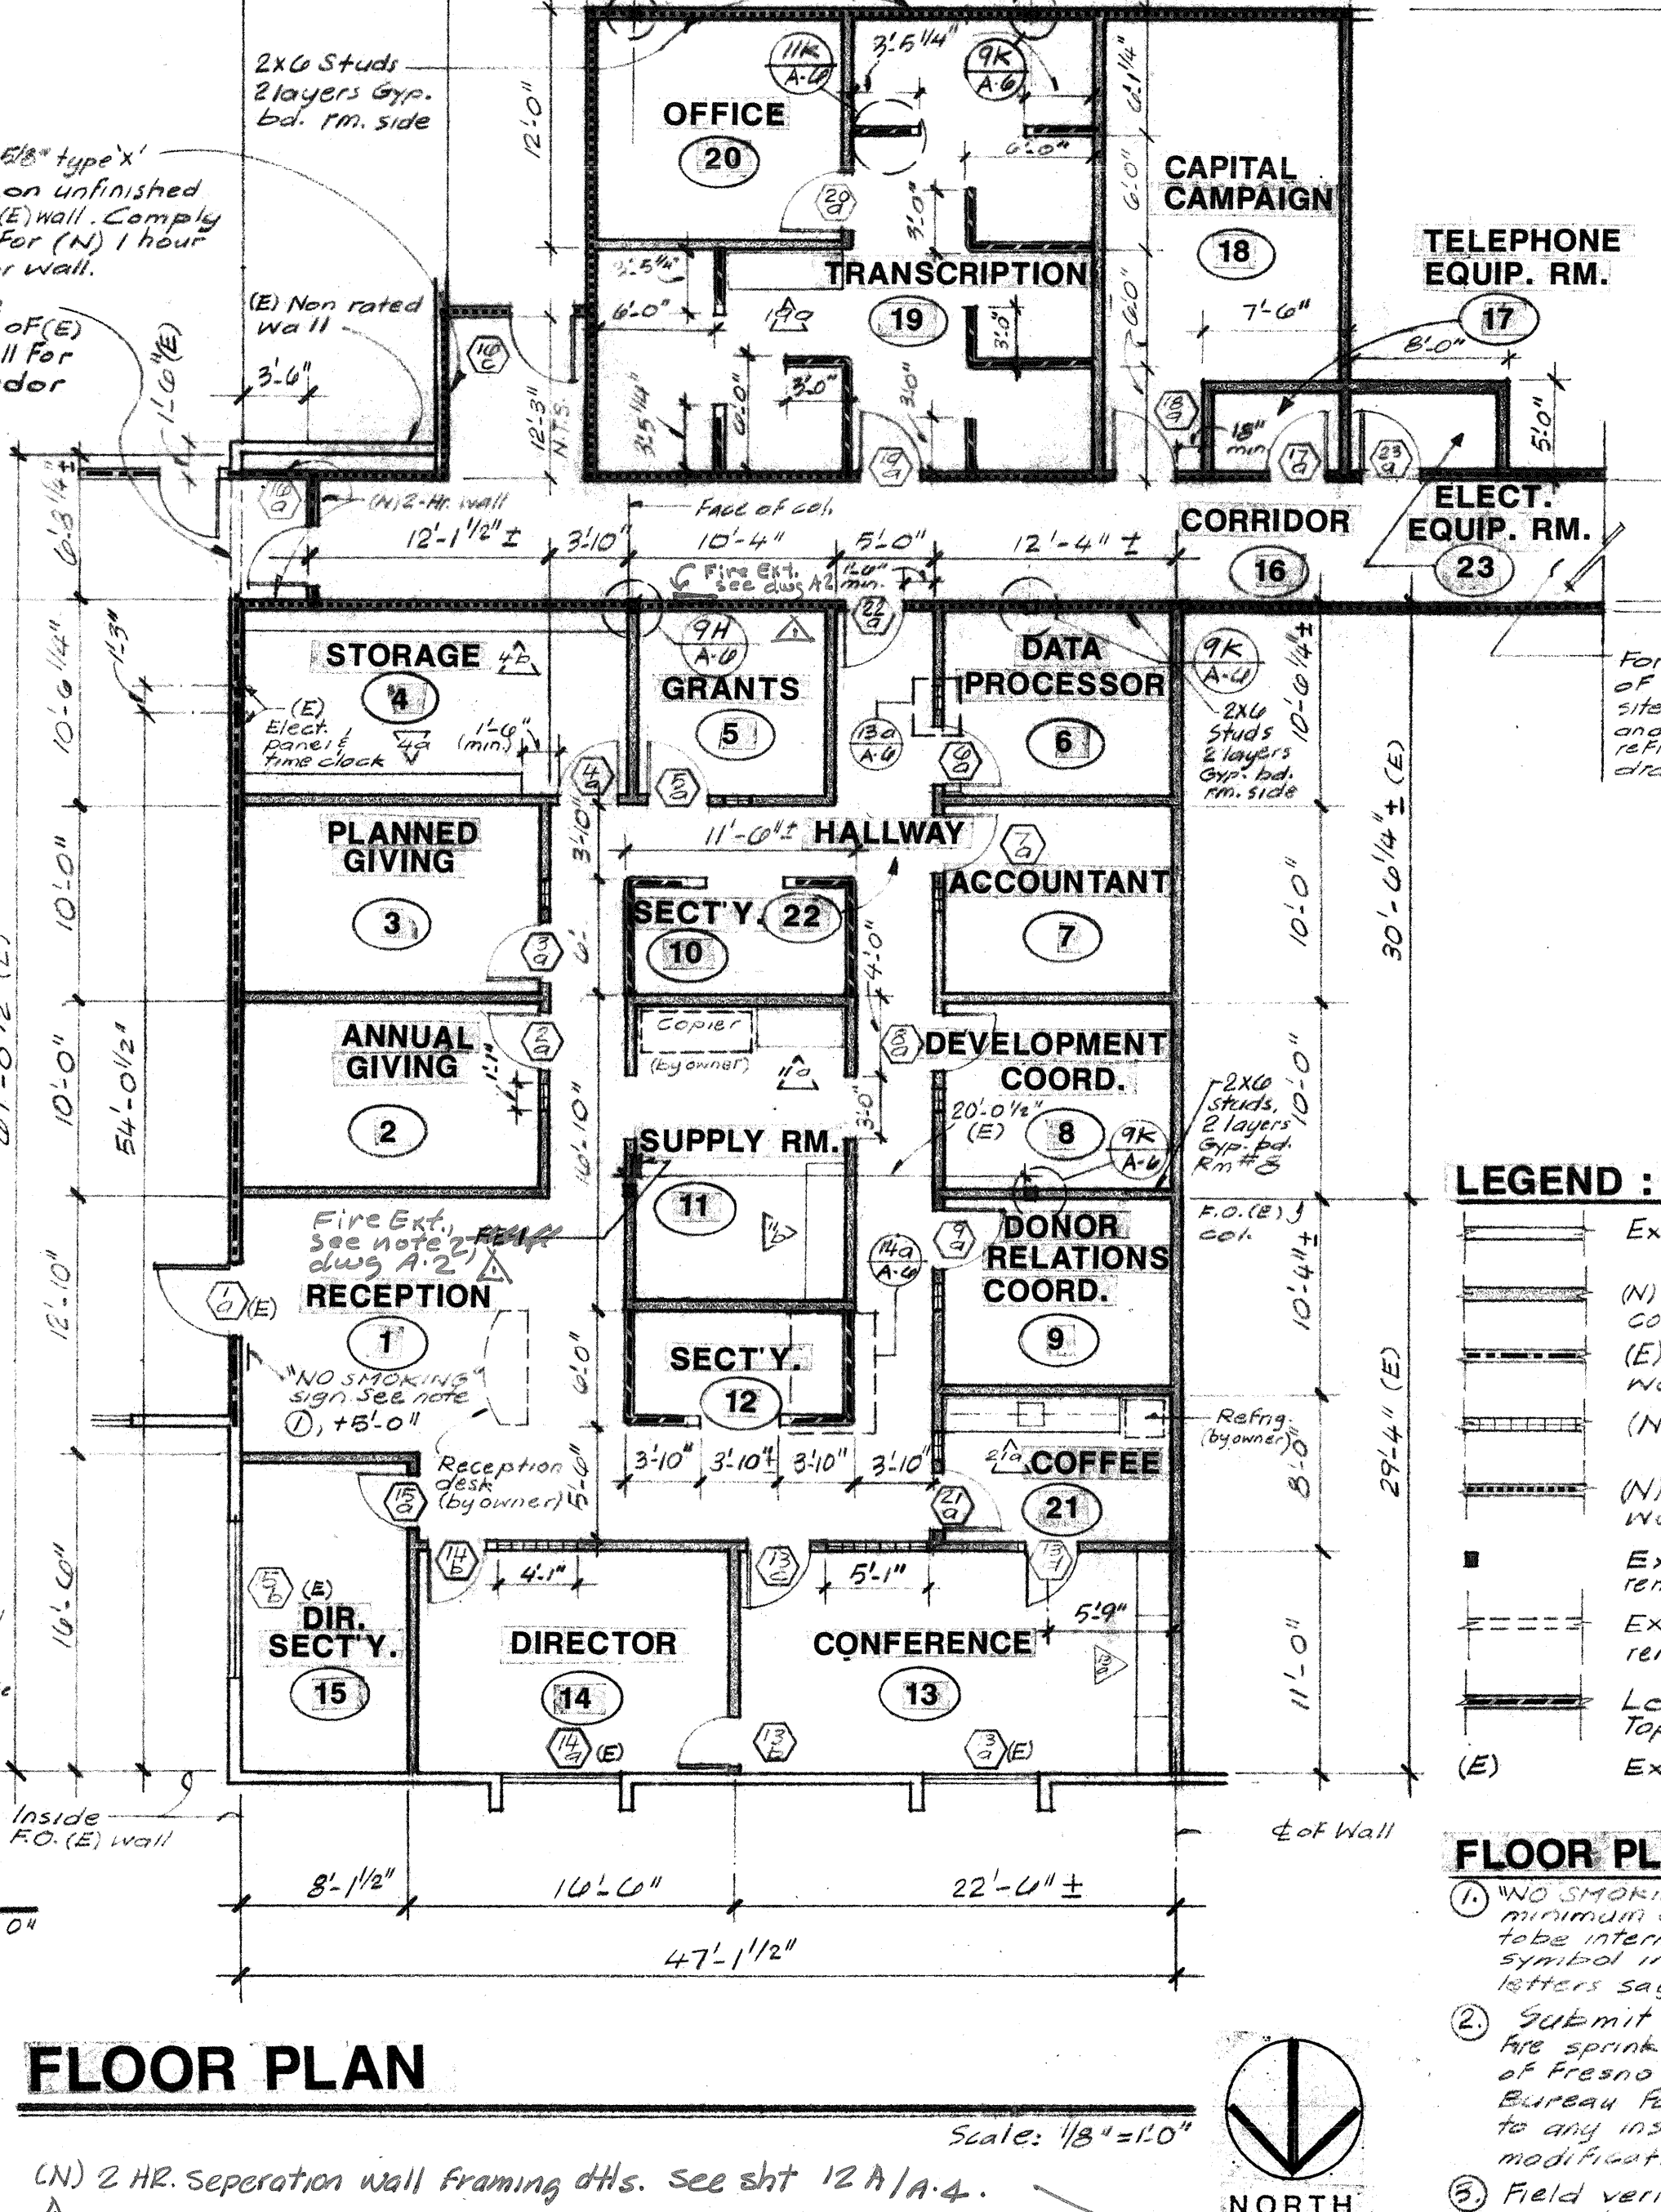

FLOOR PLAN


INTERIOR FINISH SCHEDULE

NO.	ROOM NAME	FLOOR	BASE	WALLS	CEILING	MISC
1	RECEPTION	FF		FF	DN-1	M-2 W-2
2	ANNUAL GIVING					
3	PLANNED GIVING					
4	STORAGE					
5	GRANTS					
6	DATA PROCESSOR					
7	ACCOUNTANT					
8	DEVEL. COORD.					
9	DONOR REL. COORD.					
10	SECT. Y.					
11	SUPPLY ROOM					
12	SECT. Y.					
13	CONFERENCE					
14	DIRECTOR					
15	DIR. SECT. Y.					
16	CORRIDOR					
17	TEL. EQUIP. RM.					
18	CAPITAL CAMPAIGN					
19	TRANSCRIPTION					
20	OFFICE					
21	COFFEE					
22	HALLWAY					
23	ELECTRICAL EQUIP.					

NOTES

- FF = Factory Finish (See appropriate Specification Section for requirements)
- (E) Slabs = (Exposed existing slab)
- HM = Hollow metal
- WD = Wood
- For DW-1, DW-2, M-2 See Specification Section 09-900, painting

EAST INDIANAPOLIS

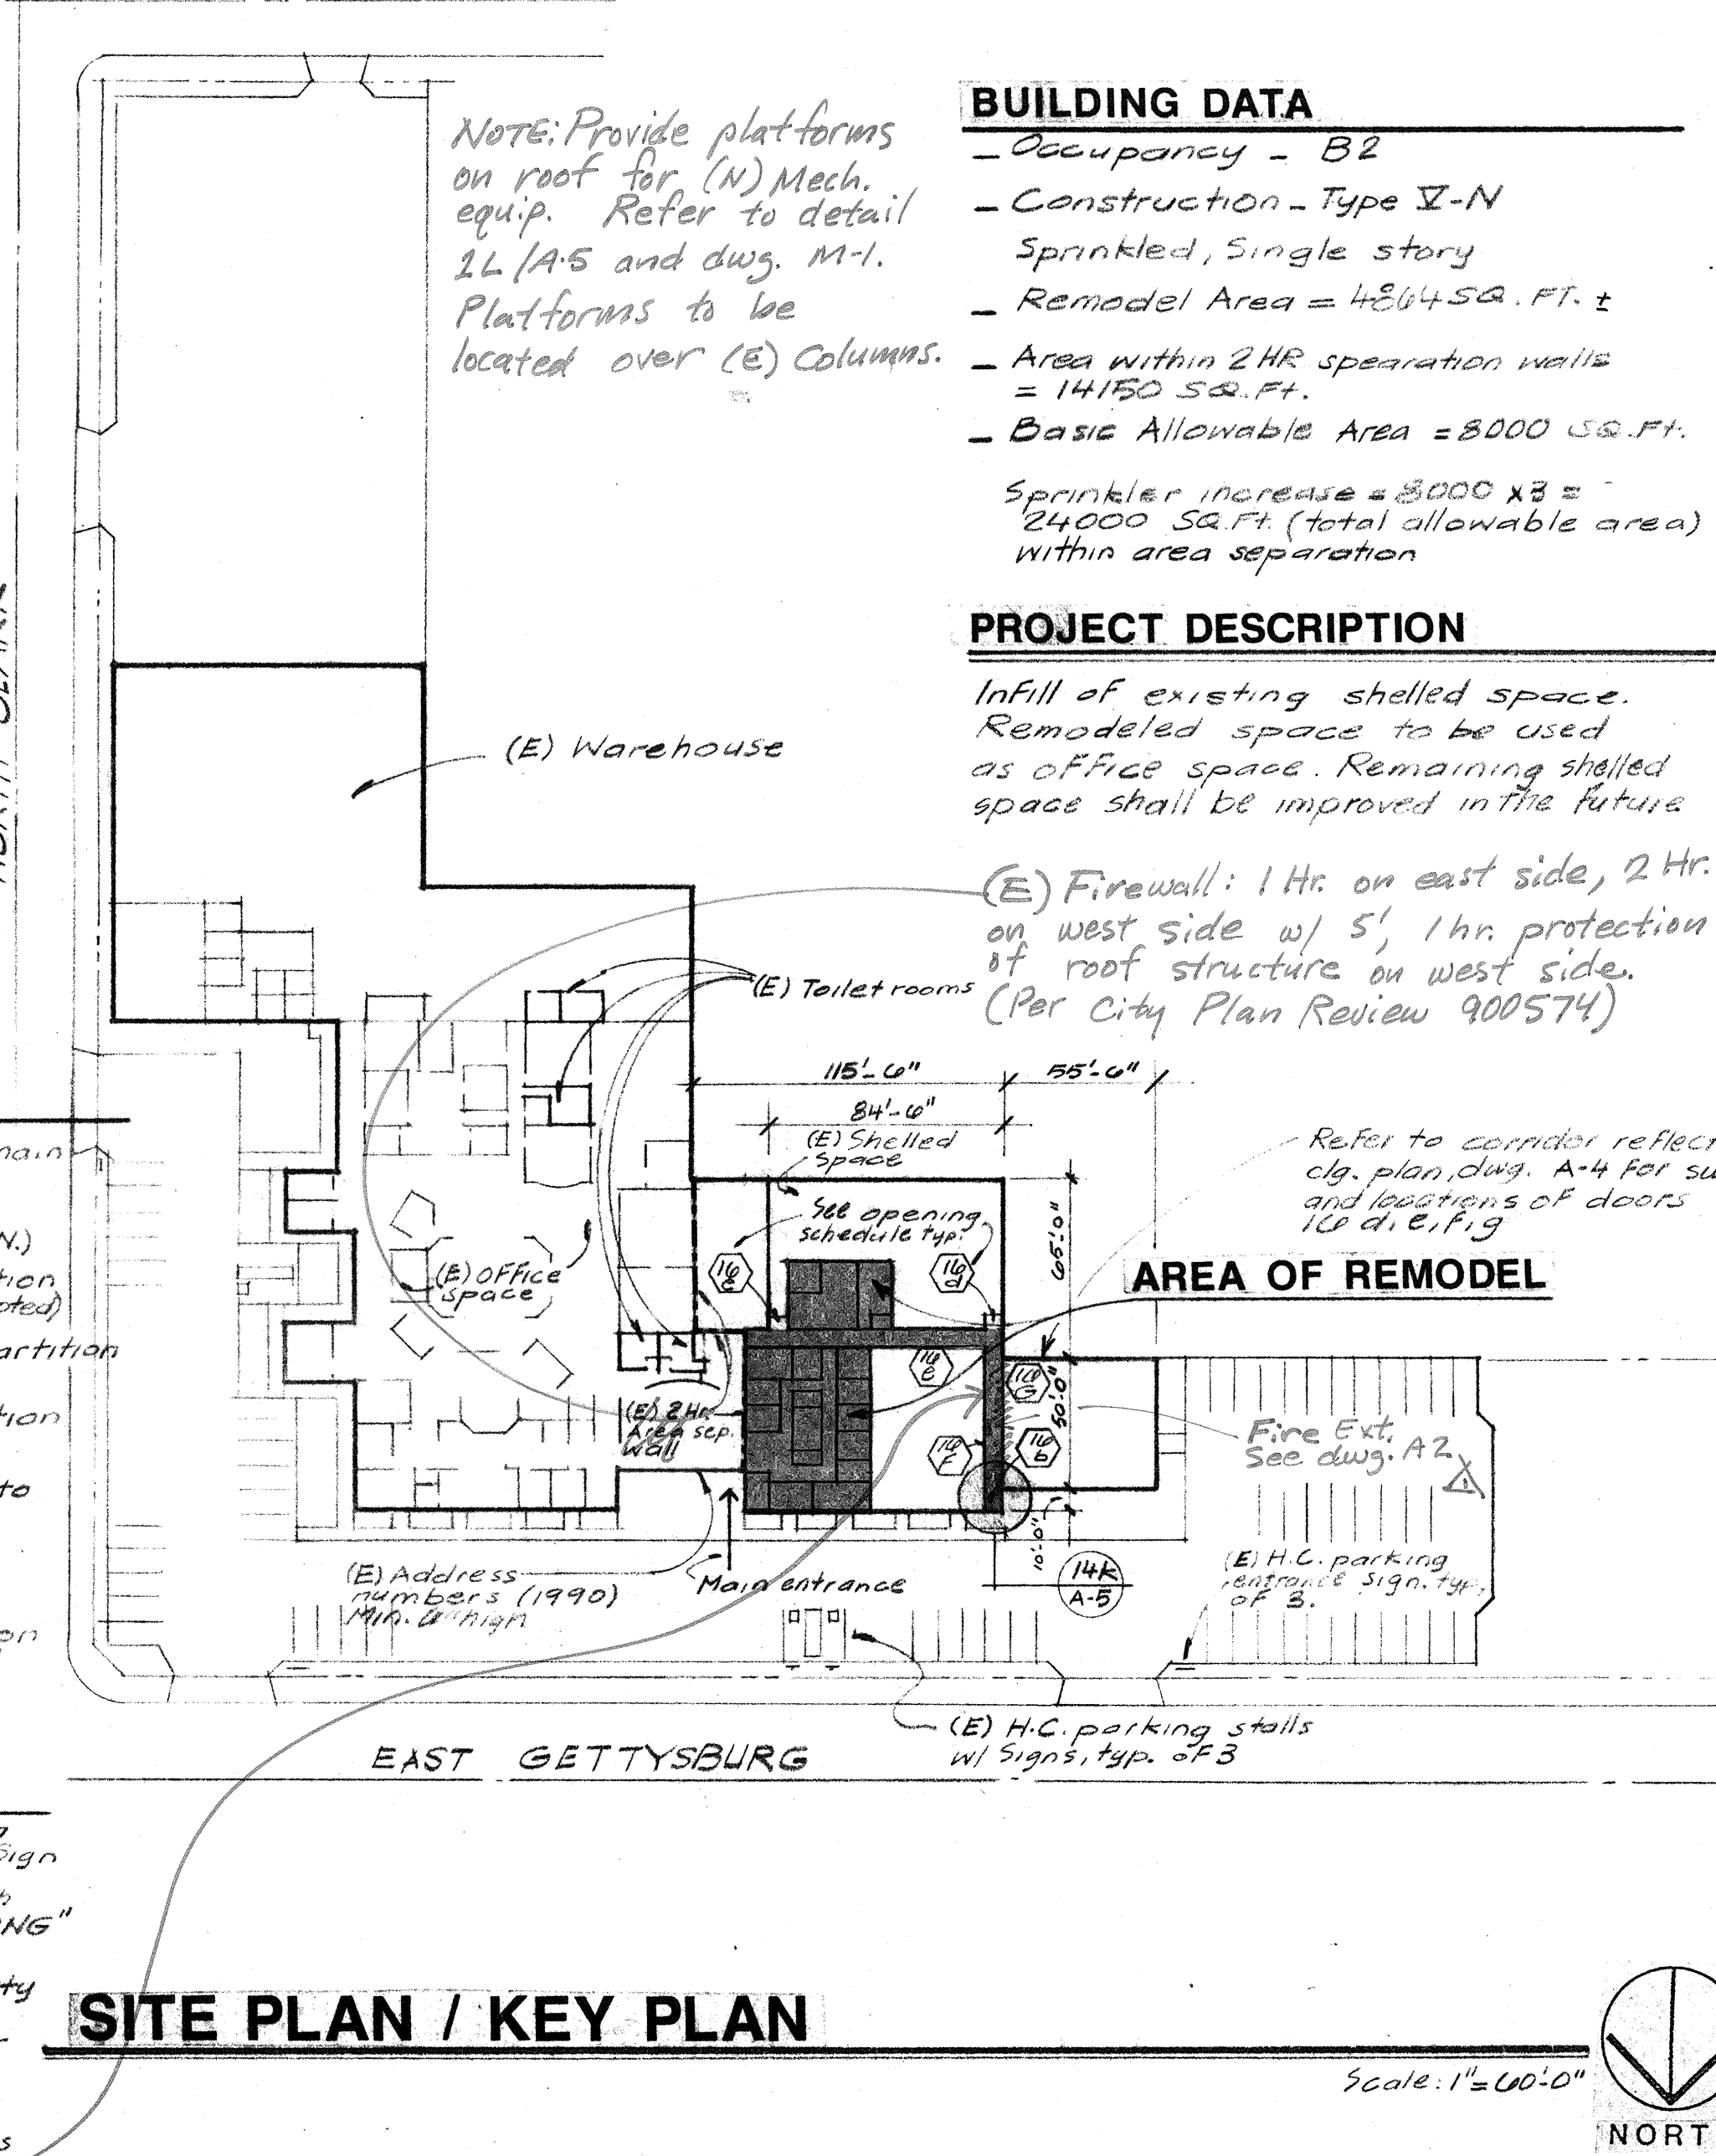

SITE PLAN / KEY PLAN

GENERAL NOTES:

- Insulation Note: The existing building envelope is insulated as follows:
1. Floor: None, slab on grade.
2. Exterior walls: R11 Minimum.
3. Roof: R19 Minimum.
4. Any insulation is damaged or missing, provide new to match the existing conditions.

Insulation. All insulation materials including facings, such as vapor barriers or breather papers installed within floor-ceiling assemblies, roof-ceiling assemblies, walls, crawl spaces or attics, shall have a flame spread rating not to exceed 25 and a smoke density not to exceed 450 when tested in accordance with U.S.C. Standard No. 82-1.

- Provide acoustical unfaced batt insulation at the following locations:
1. All walls rooms 13, 14, 16, 21
2. West walls rooms 6, 7, 8, 9, 13
3. South walls rooms 13, 20
4. East and south perimeter walls room 19. See detail (H) for typical wall section.

- Spot cut, patch, and repair (E) concrete slabs as required for new utility lines and under floor electrical conduits. New concrete shall be placed in 28 days min. Provide 1/2" rebar at 18" o.c. in right fit holes 24" o.c. at corners to be patched. Patch and repair existing vapor barrier.

INDEX TO DRAWINGS

- A BACKFLOW PREVENTION DEVICE IS REQUIRED UNDER CITY PLAN CHECK #910776
- CONTACT WATER DIVISION AT 488-1408 FOR REQUIREMENTS.
- DEVICES MUST BE INSTALLED ON-SITE IN A LOCATION APPROVED BY THE CROSS CONNECTION CONTROL OFFICER.
- A PLUMBING PERMIT IS REQUIRED TO INSTALL DEVICE. BACKFLOW PREVENTION DEVICES SHALL BE INSTALLED AT THE CONSUMERS EXPENSE BY A QUALIFIED JOURNEYMAN PLUMBER CERTIFIED AS COMPETENT FOR SUCH PURPOSES BY THE WATER SYSTEMS MANAGER.
- BACKFLOW DEVICES MUST BE TESTED AND ACCEPTED BY THE WATER DIVISION PRIOR TO GRANTING BUILDING FINAL.
- CONTRACTOR IS RESPONSIBLE TO CONTACT THE WATER DIVISION A MINIMUM OF 5 DAYS PRIOR TO REQUEST FOR FINAL BUILDING INSPECTION.

ARCHITECTURAL

- A-1 Floor Plan, Reflected Ceiling Plan, Site/Key Plan, Room, Finish, and Cabinet Schedules
- A-2 Interior Elevations
- A-3 Interior Elevations
- A-4 Corridor Reflected Ceiling Plan and Details
- A-5 Details
- A-6 Details

PLUMBING

- P-1 Plumbing Plan, Schedules and Details

MECHANICAL

- M-1 Air Conditioning Plan
- M-2 Mechanical Schedules and Details

ELECTRICAL

- E-001 Details, Single Line Diagrams, Symbols
- E-002 Power and Lighting Plan
- E-003 Lighting Plan

JUL 02 1991
Any changes to these plans must be approved by the Development Department. The contractor shall obtain a permit from the City of Fresno to install the project in the City of Fresno.

CITY BACK CHECK REVISIONS

No.	Revisions/Submissions	Date
-----	-----------------------	------

Edwin S. Darden Associates, Inc.
ARCHITECTS AND PLANNERS
Edwin S. Darden FAIA / Edwin S. Darden Jr. AIA
Martin E. Dietz AIA CCS / Edwin C. Goodwin AIA
1177 W. Shaw Avenue / Fresno, California 93711 / 209-222-7483
987 Oros Street / San Luis Obispo, California 93401 / 805-543-3965


Consultant

VALLEY CHILDREN'S HOSPITAL PROFESSIONAL CENTER
FOUNDATION OFFICE PROJECT
1990 EAST GETTYSBURG FRESNO CA, Project

FLOOR PLAN, REFLECTED CEILING PLAN, SITE PLAN/KEY PLAN, AND SCHEDULES.
Drawing

Designed By:	Project No.: 9116
Drawn By:	Scale:
Checked By:	
Reviewed By:	
Date:	Sheet: of:

Set #4

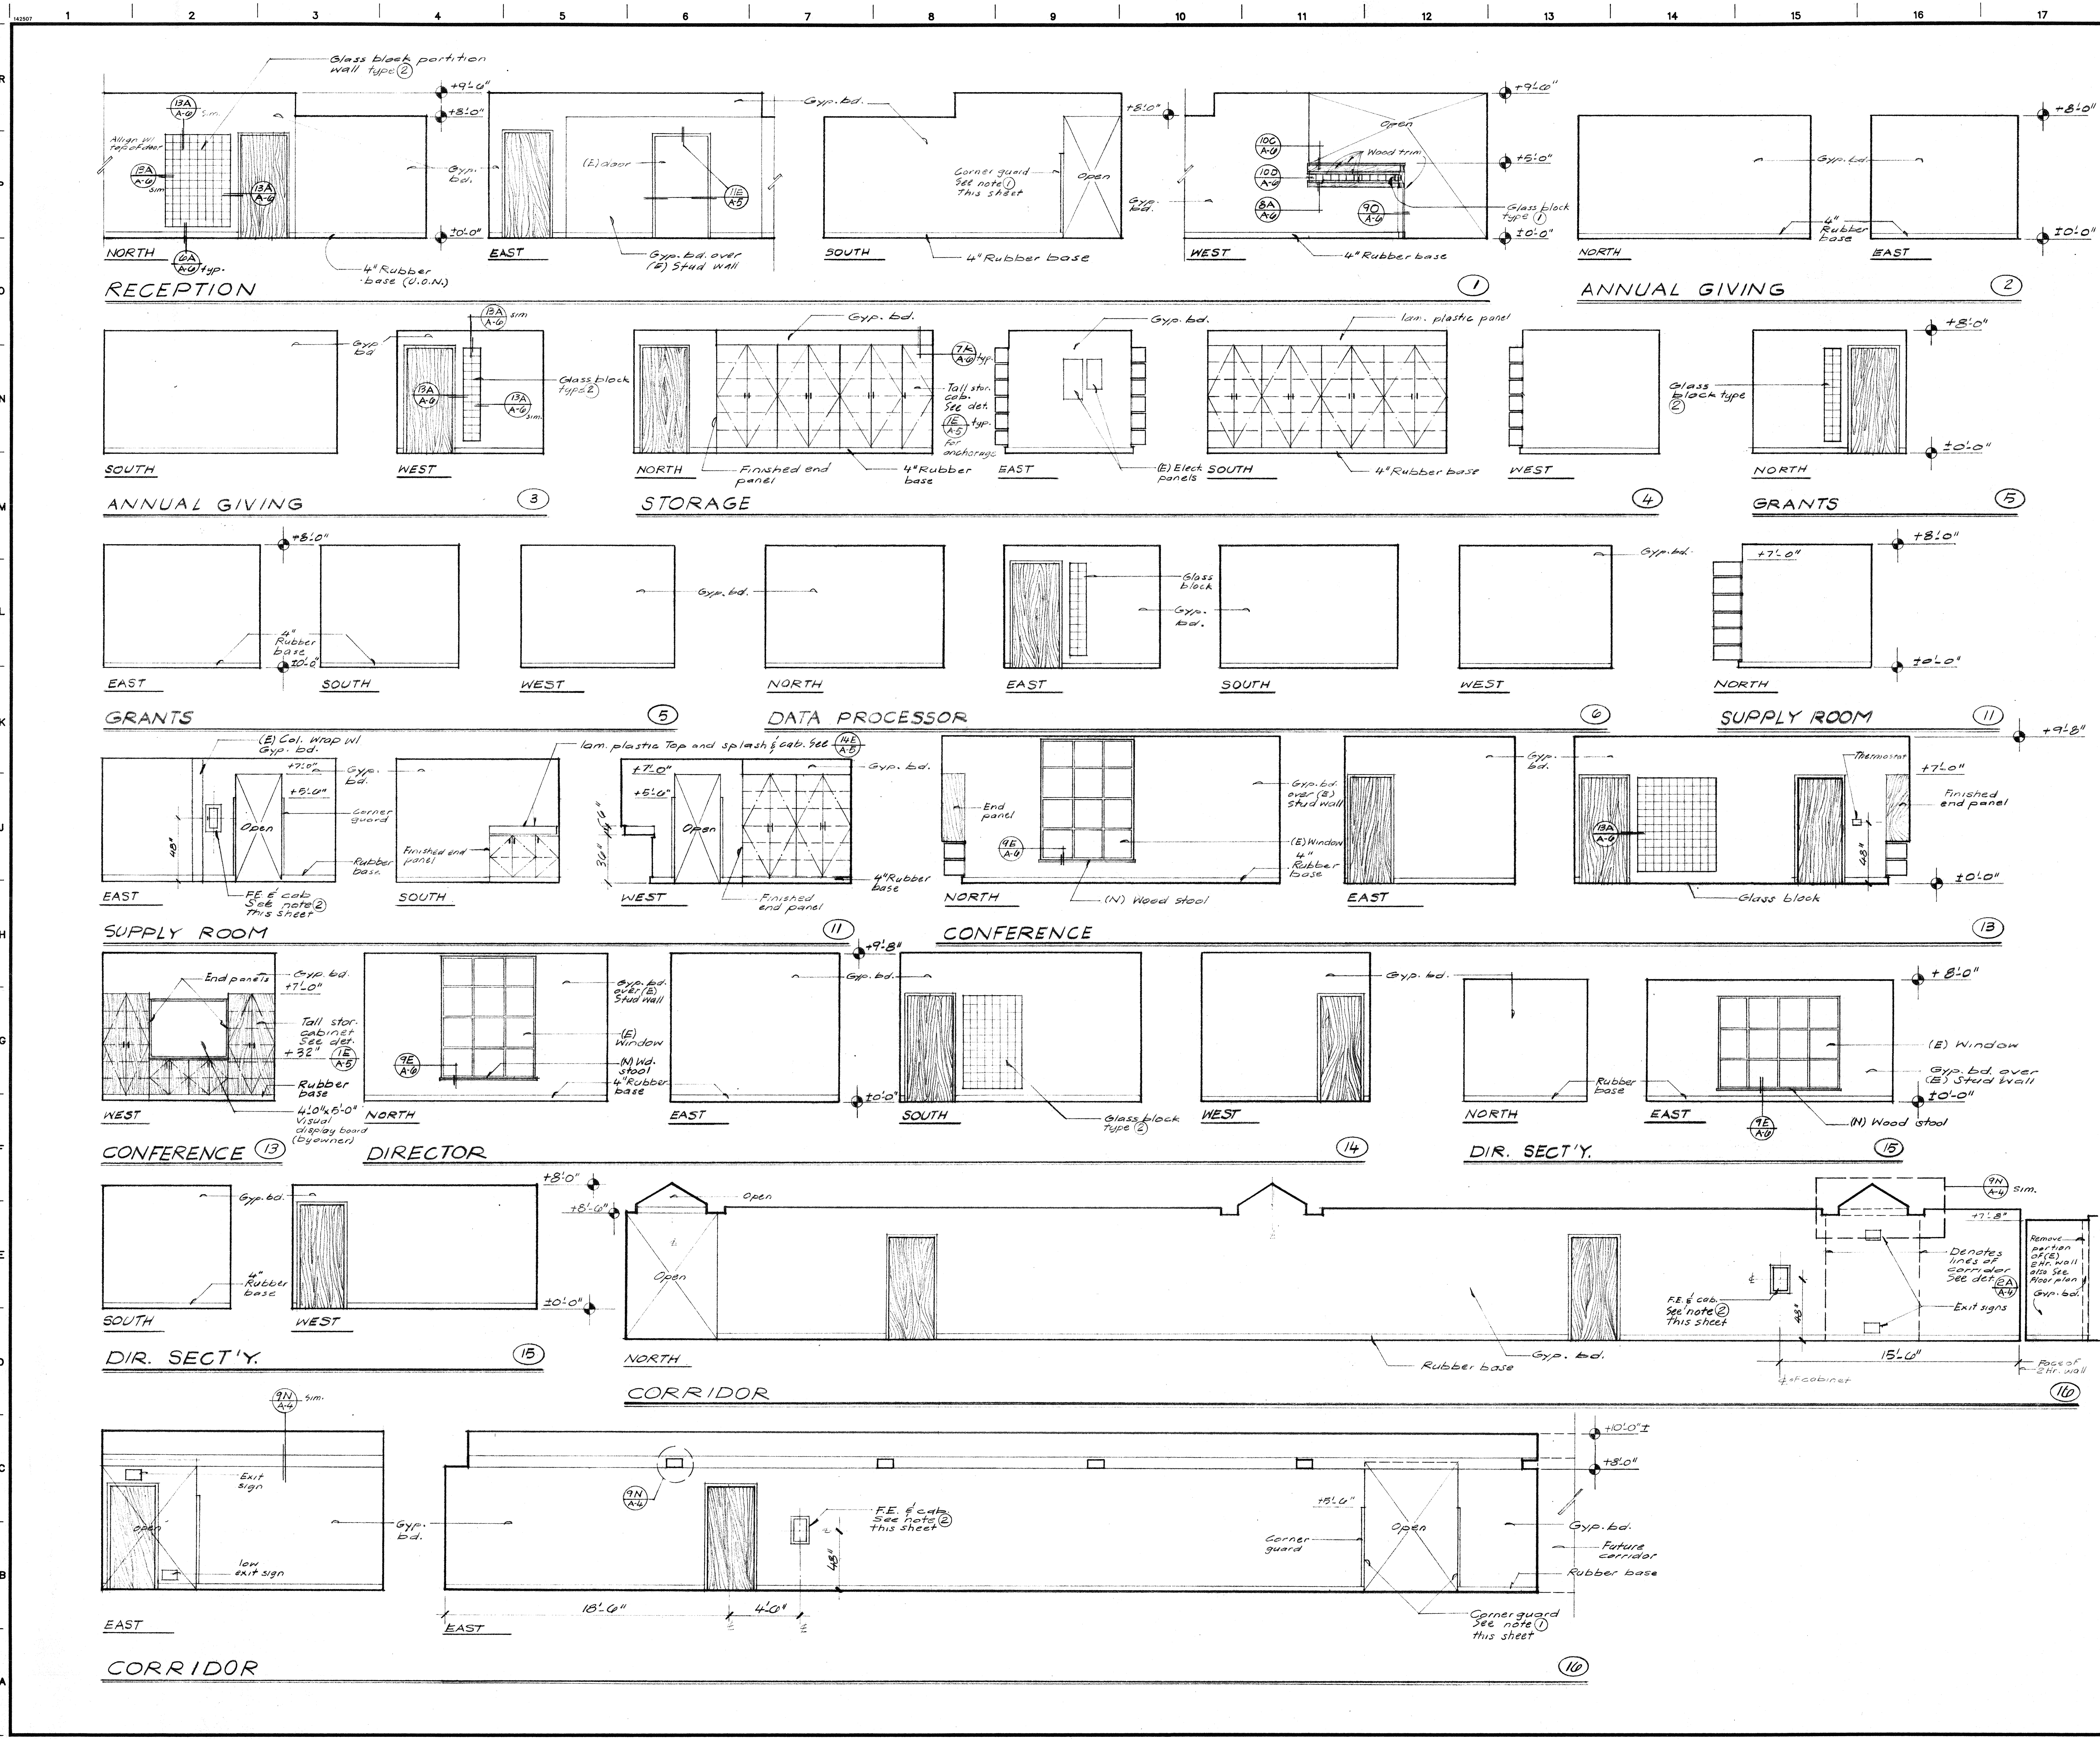

Materials Keying Legend

NOTES

- Provide 2"x2" clear vinyl corner guard
- Fire extinguishers shall be 10lb, 2A10BC capacity. Fire extinguisher cabinets shall be semi-recessed enamel steel w/2"x2" rolled return edge and full break glass door. Where fire extinguishers are installed in 1 hour rated fire walls, maintain the wall fire rating by providing one layer of 5/8" type X gyp. bd. at the top, bottom and sides of recess and two layers at the back of the cabinet recess. Fire extinguishers shall be located so that the maximum travel distance does not exceed 75'.

CITY OF FRESNO
 DEVELOPMENT DEPARTMENT

JUL 02 1991

Any changes to these plans must be approved by the Development Department. The issuance of a permit does not serve to give anyone the right to violate City or State Laws.

No.	Revisions/Submissions	Date:


Edwin S. Darden Associates, Inc.
 ARCHITECTURE AND PLANNING
 Edwin S. Darden F.A.I.A. / Edwin S. Darden Jr. AIA
 Martin E. Dierks AIA CCS / Edwin C. Goodwin AIA

1177 W. Shaw Avenue / Fresno, California 93711 / 209 233 7463
 987 Oscar Street / San Luis Obispo, California 93401 / 805 543 3965

VALLEY CHILDREN'S HOSPITAL PROFESSIONAL CENTER
 FOUNDATION OFFICE PROJECT
 1990 EAST GETTYSBURG FRESNO CA Project

INTERIOR ELEVATIONS
 Drawing

Designed By:	Project No.: 9116
Drawn By:	Scale:
Checked By:	A.2
Reviewed By:	
Date:	Sheet: of:

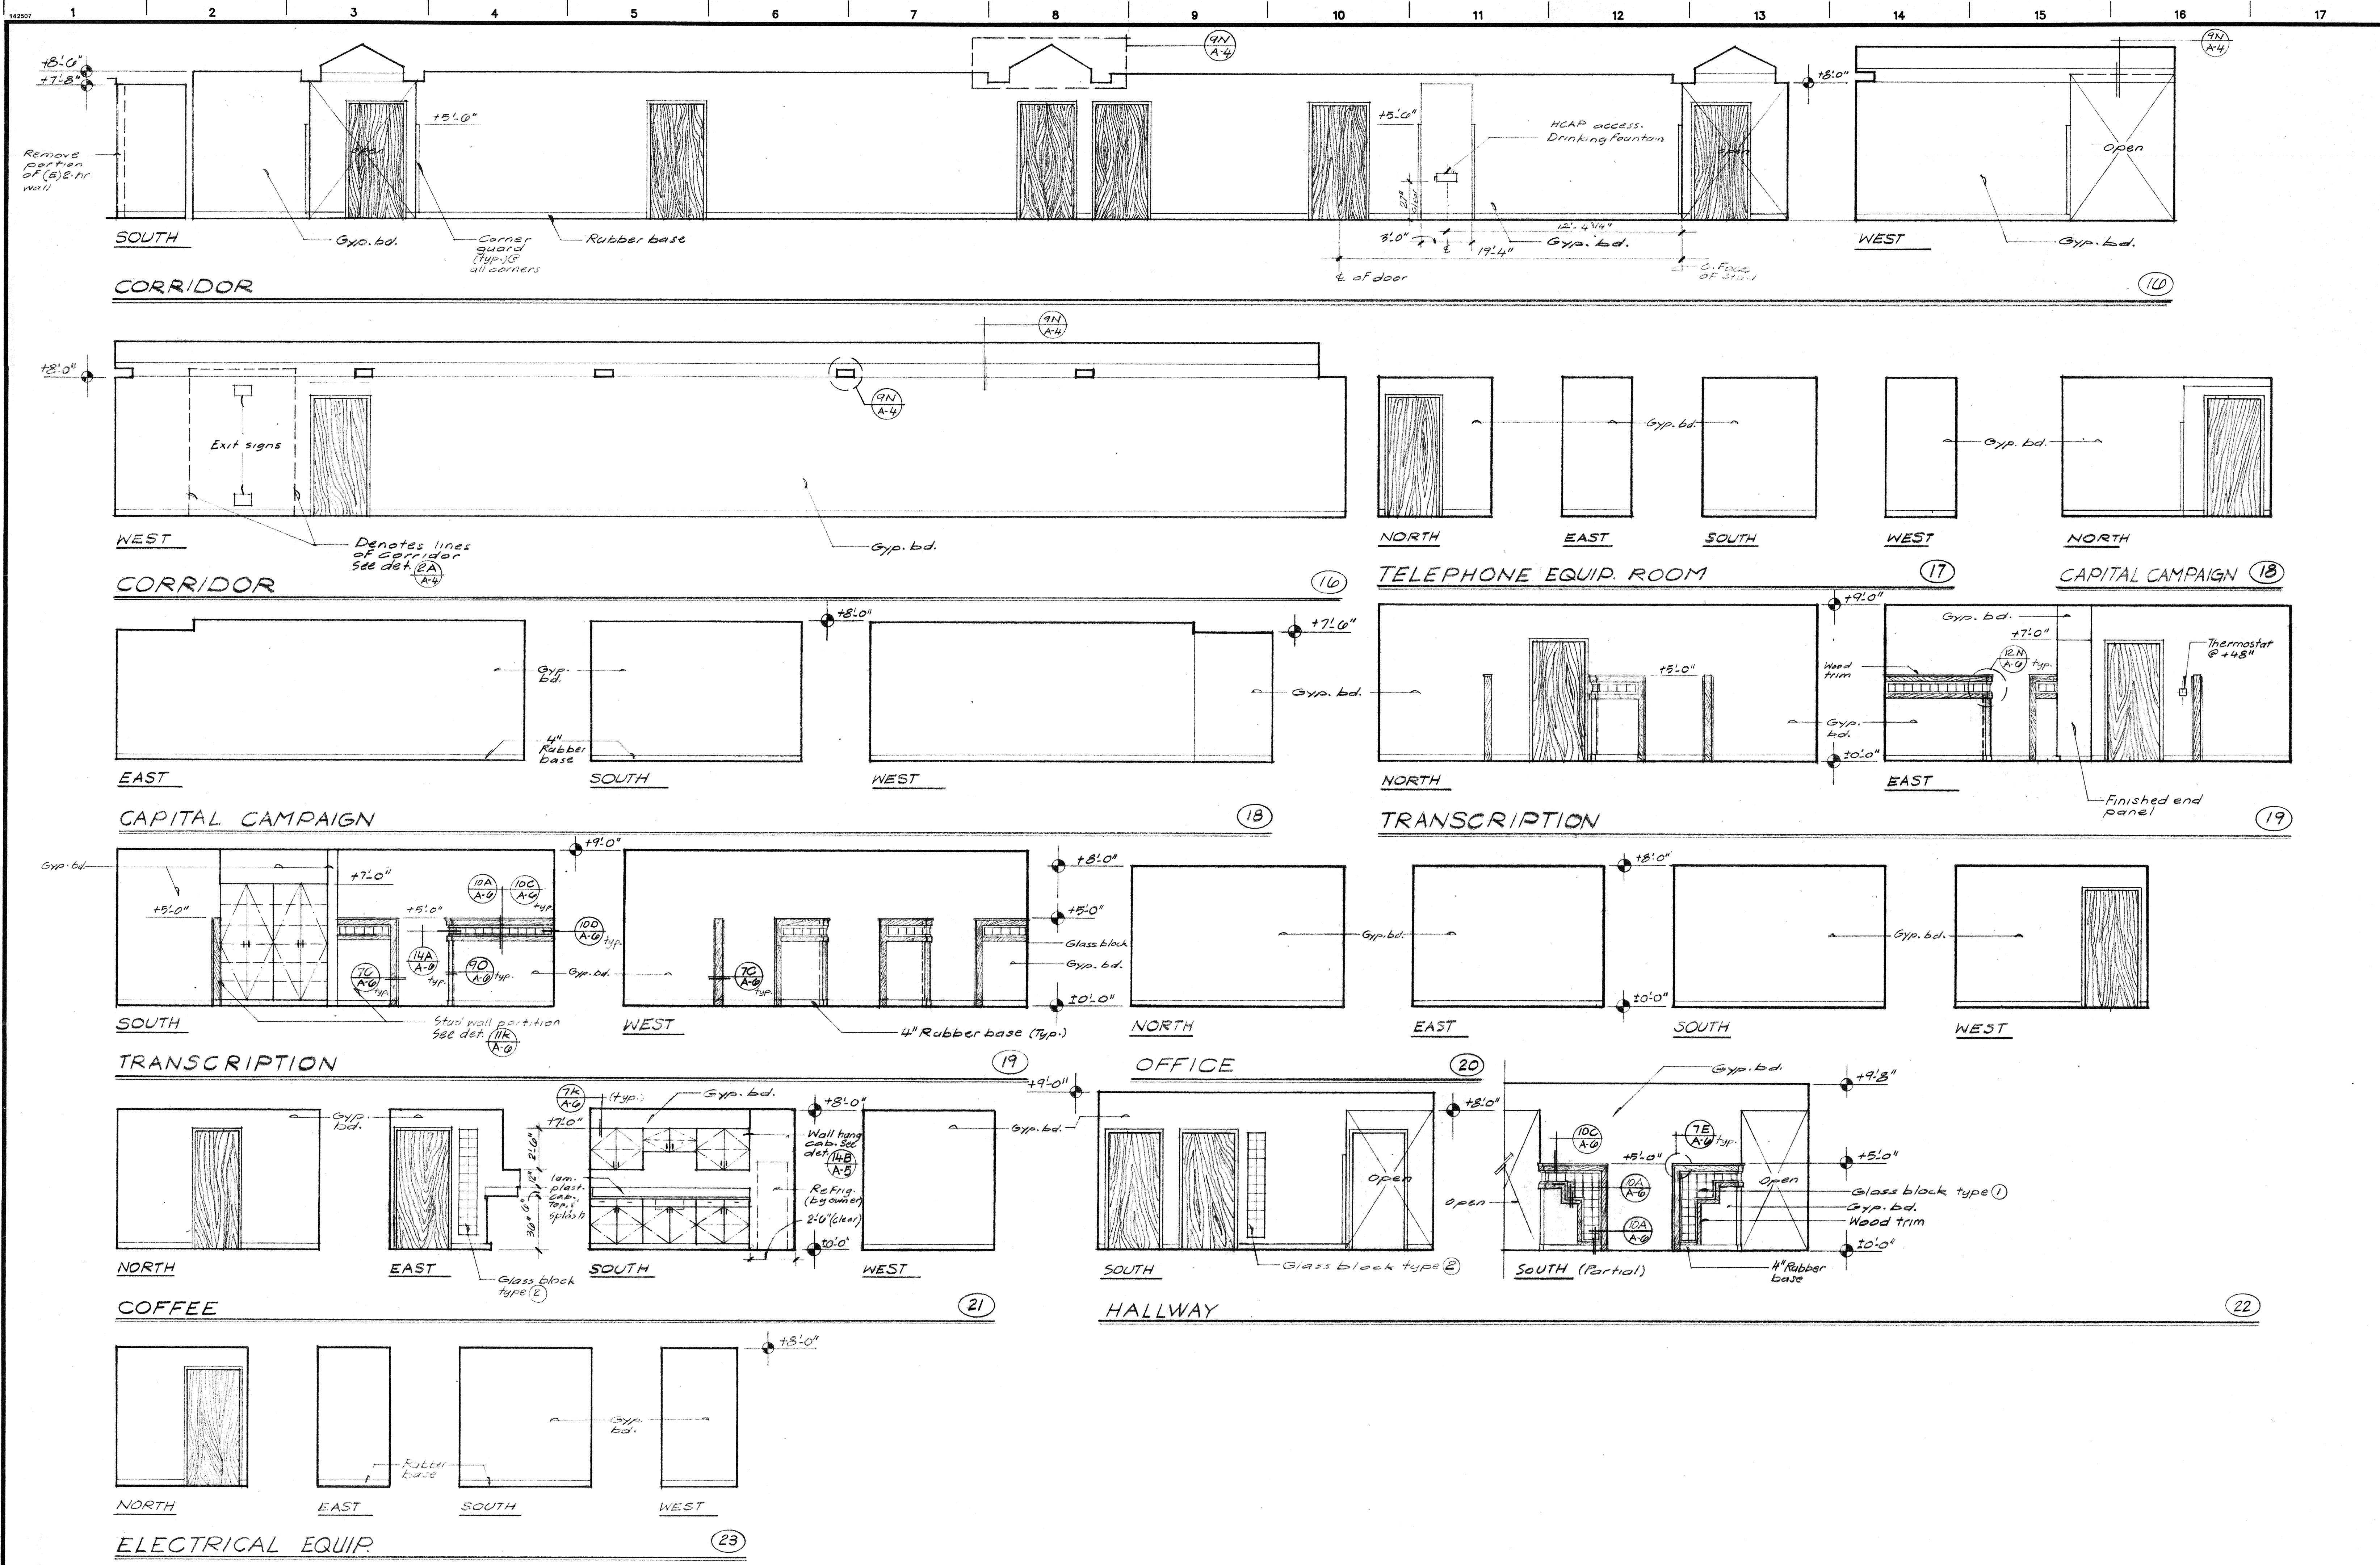

Materials Keying Legend

CITY OF FRESNO
DEVELOPMENT DEPARTMENT
JUL 02 1991
Any changes to these plans must be approved by the
Development Department. The issuance of a permit
does not grant to any person the right to violate City or
State Laws.
APPROVED

No.	Revisions/Submissions	Date

Edwin S. Darden Associates, Inc.
ARCHITECTURE AND PLANNING
Edwin S. Darden F.A.A. / Edwin S. Darden Jr. AIA
Martin E. Dietz AIA C.C.S. / Edwin C. Goodwin AIA
1177 W. Shaw Avenue / Fresno, California 93711 / 209 222-7463
987 Oros Street / San Luis Obispo, California 93401 / 805 543-3965


**VALLEY CHILDREN'S HOSPITAL PROFESSIONAL CENTER
FOUNDATION OFFICE PROJECT**
1990 EAST GETTYSBURG FRESNO CA Consultant

INTERIOR ELEVATIONS
Project

Drawing

Designed By:	Project No.: 9116
Drawn By:	Scale:
Checked By:	A.3
Reviewed By:	
Date:	Sheet: of:

SEAL
EDWIN S. DARDEN
NO. 014188
1993
FRESNO, CALIF.
STATE OF CALIFORNIA

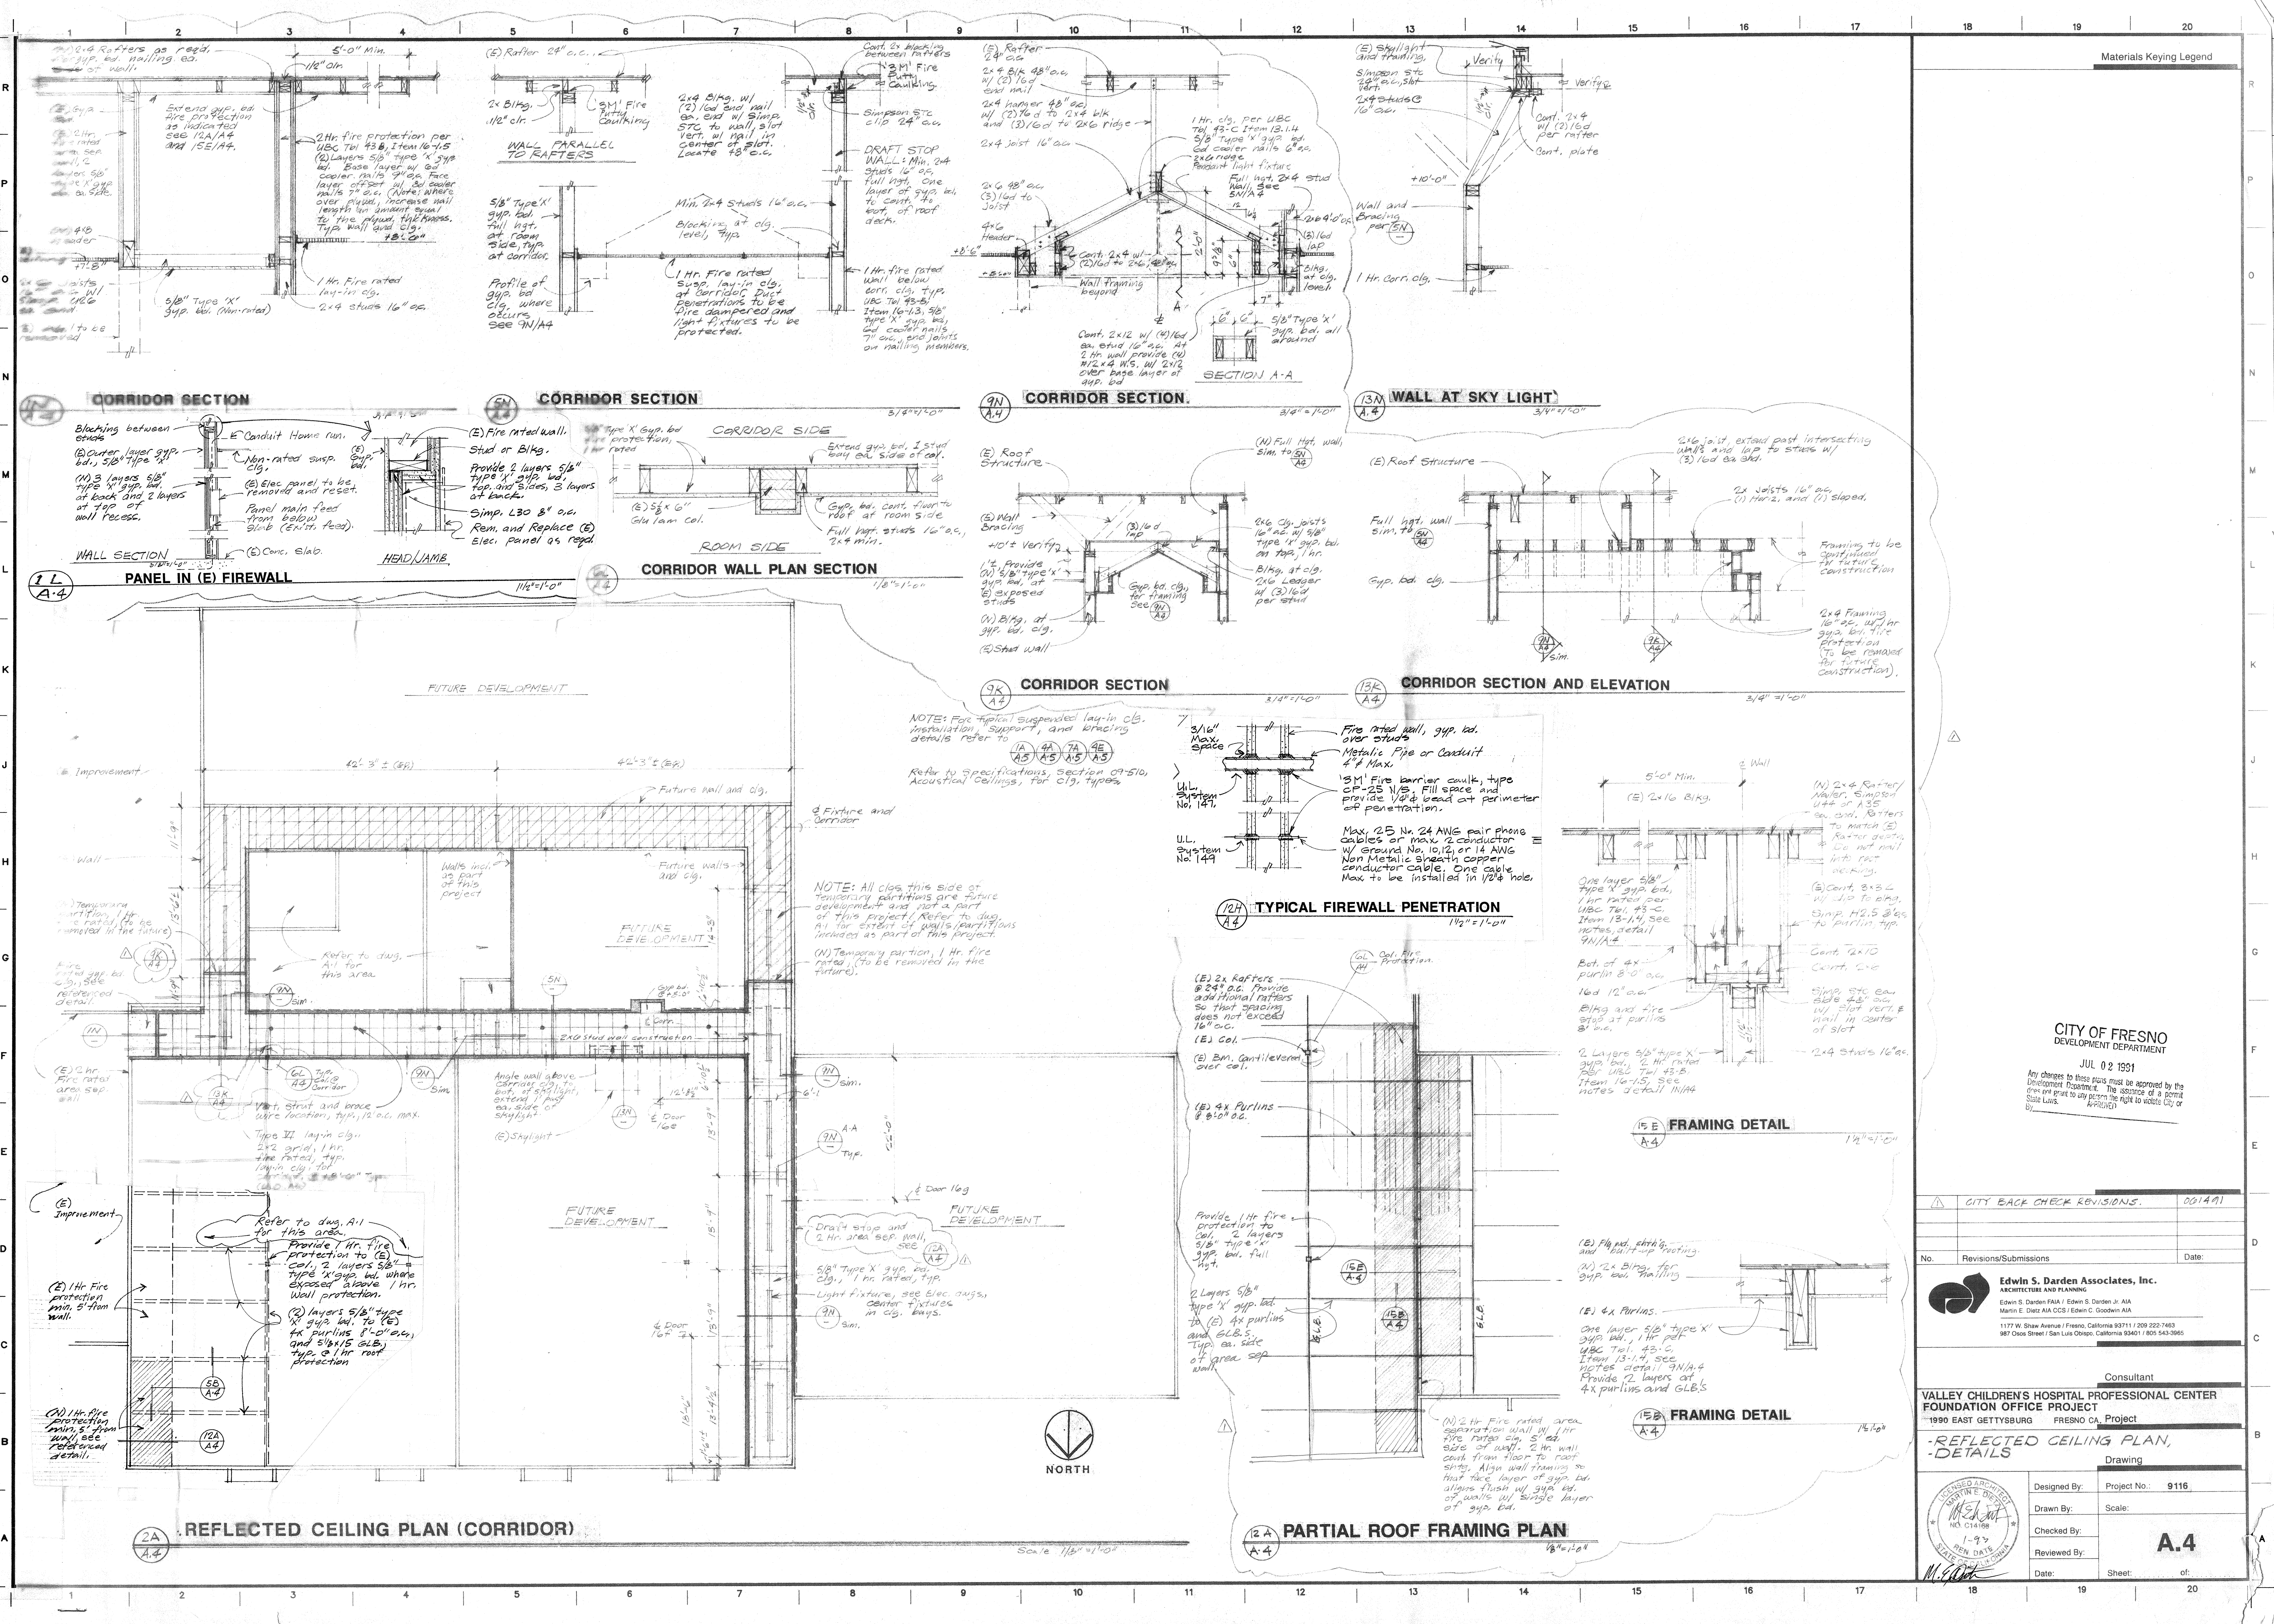

Materials Keying Legend

CITY OF FRESNO
DEVELOPMENT DEPARTMENT

JUL 02 1991

Any changes to these plans must be approved by the
Development Department. The issuance of a permit
does not grant to any person the right to violate City or
State Laws.

APPROVED

CITY BACK CHECK REVISIONS.		001491
No.	Revisions/Submissions	Date:

Edwin S. Darden Associates, Inc.

ARCHITECTURAL AND PLANNING

Edwin S. Darden P.A. / Edwin S. Darden Jr. AIA
Martin E. Dietz AIA CCS / Edwin C. Goodwin AIA

1177 W. Shaw Avenue / Fresno, California 93711 / 209 222-7463
987 Oscar Street / San Luis Obispo, California 93401 / 805 543-3965

Consultant

VALLEY CHILDREN'S HOSPITAL PROFESSIONAL CENTER
FOUNDATION OFFICE PROJECT
1990 EAST GETTYSBURG FRESNO CA, Project

























REFLECTED CEILING PLAN,
DETAILS

Drawing

Designed By:	Project No.:
Drawn By:	Scale:
Checked By:	
Reviewed By:	
Date:	Sheet: of:

1-97
REV. DATE
STATE OF CALIFORNIA

A.4

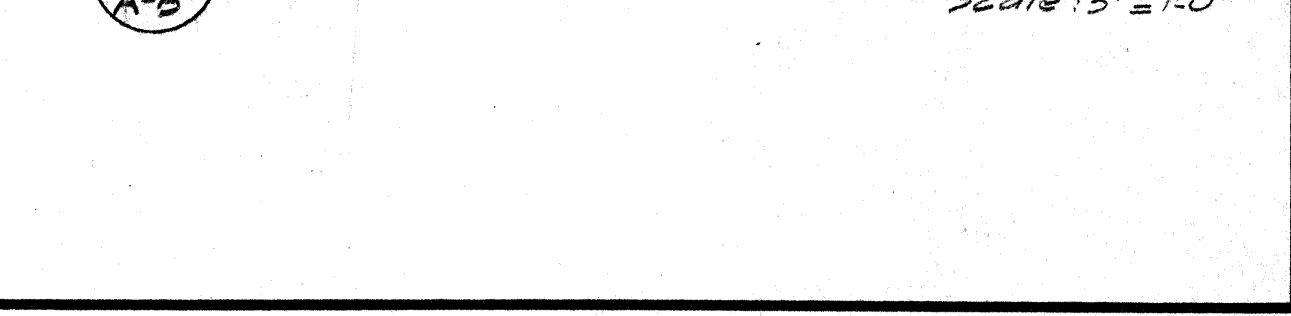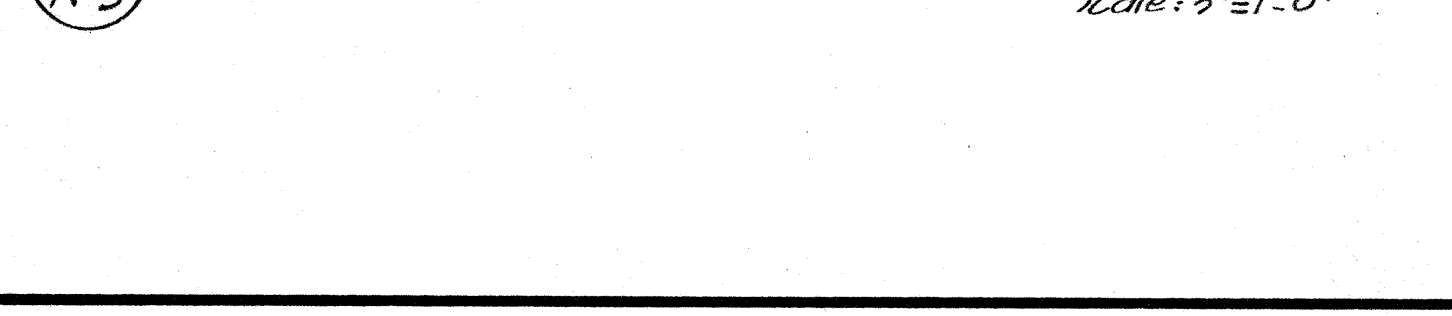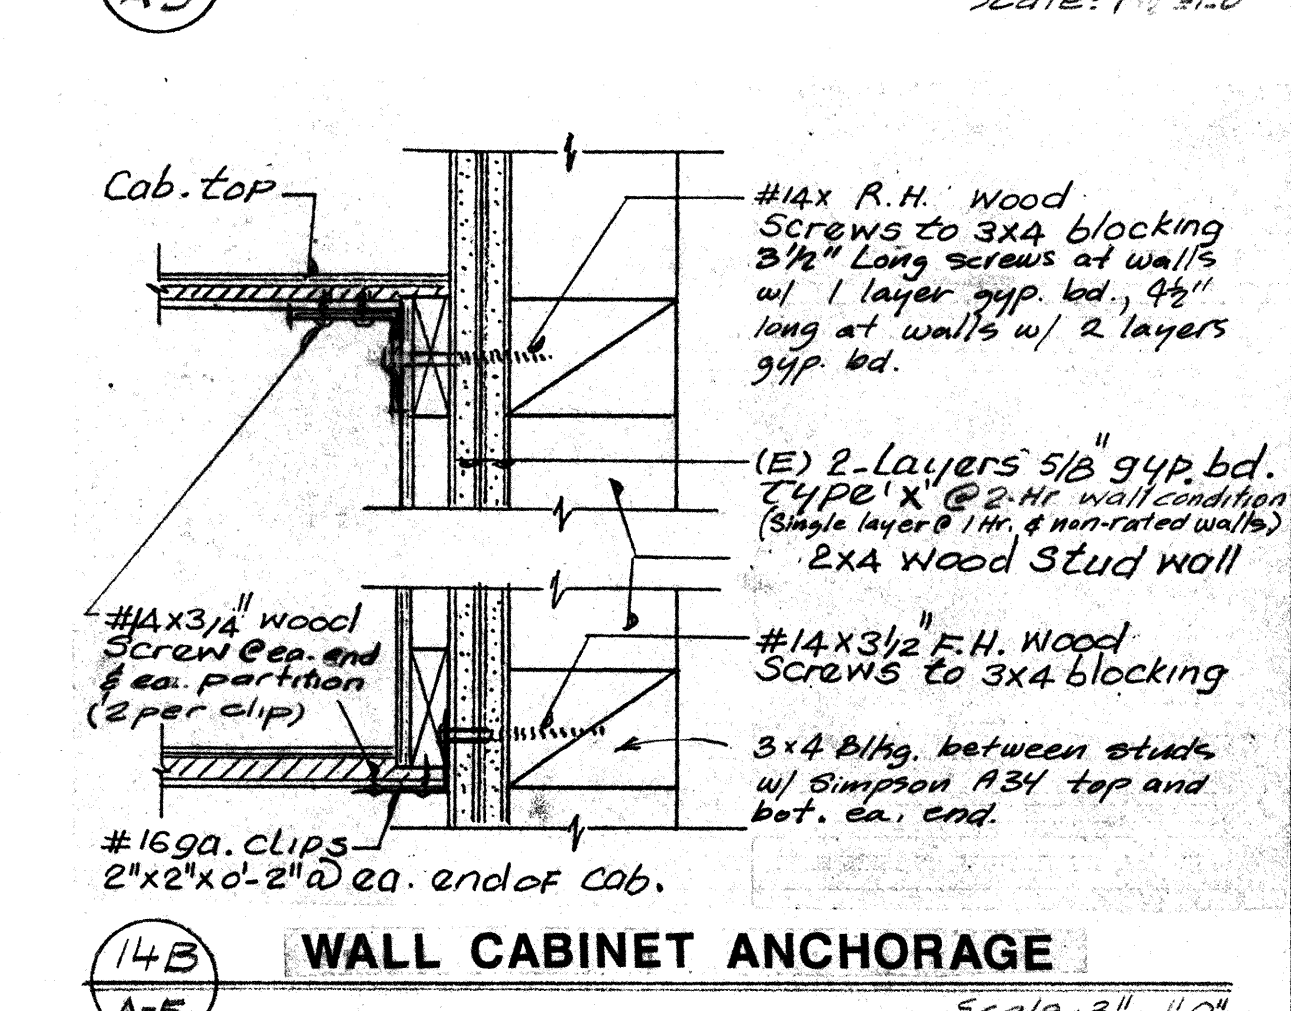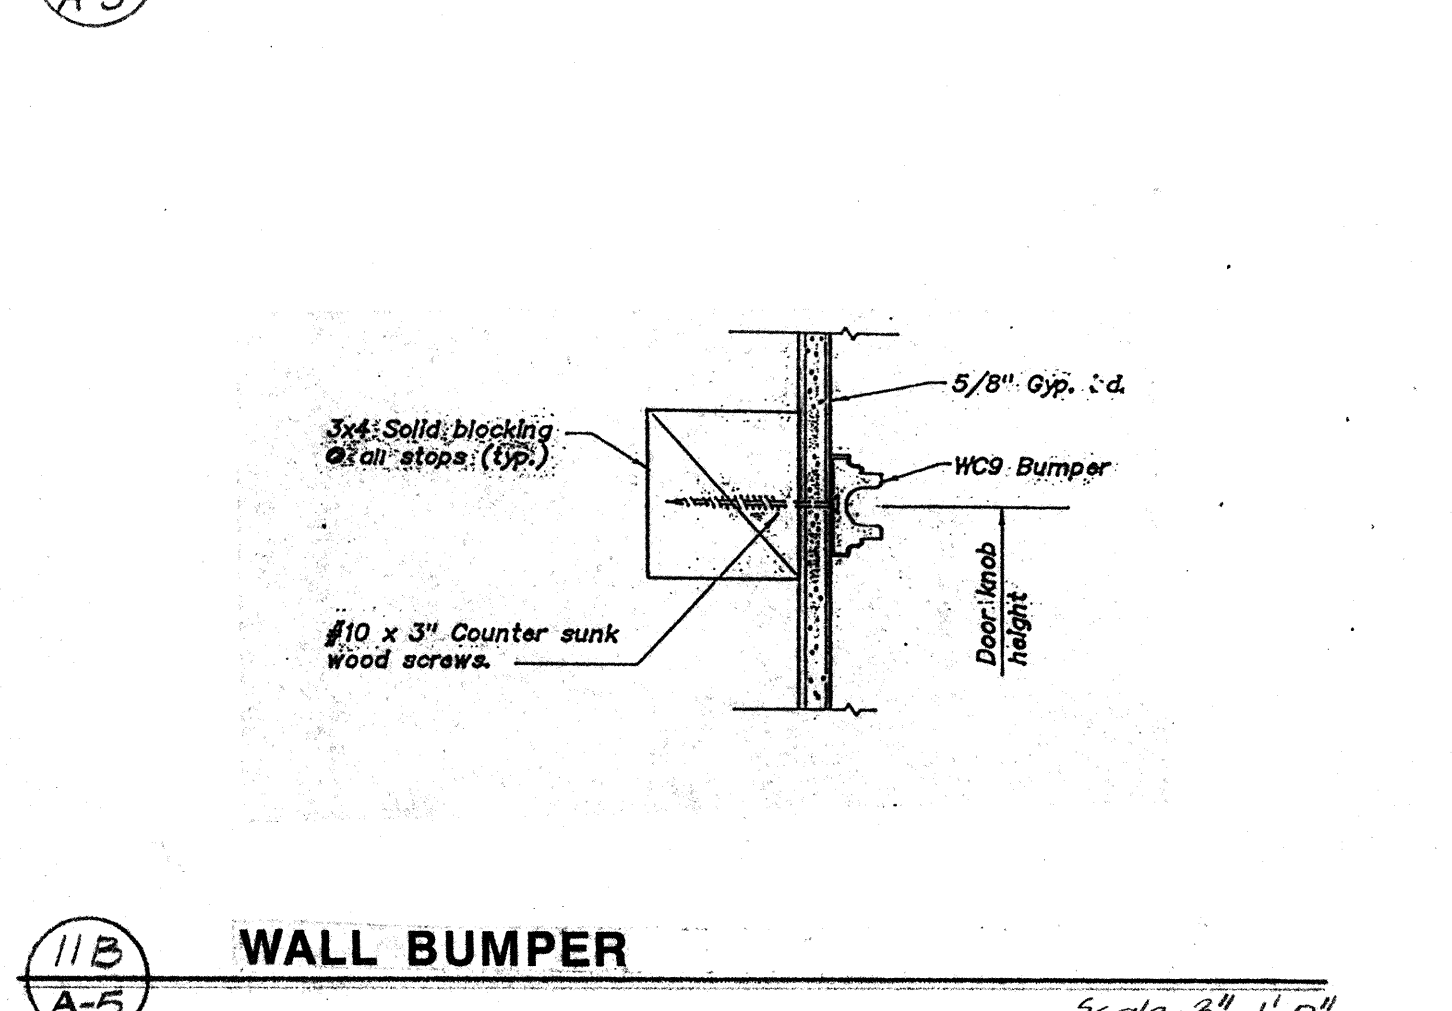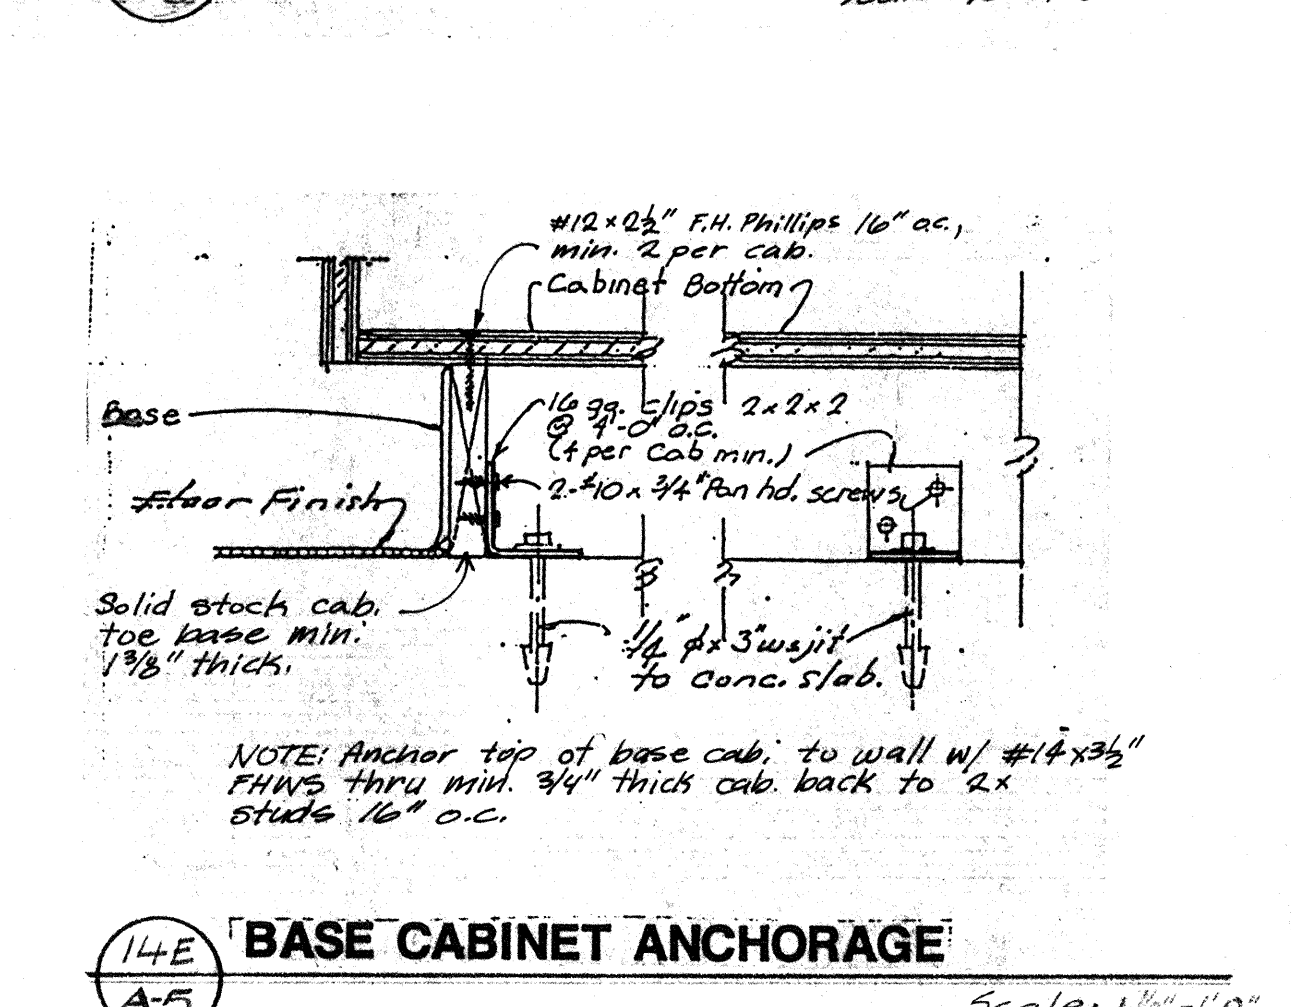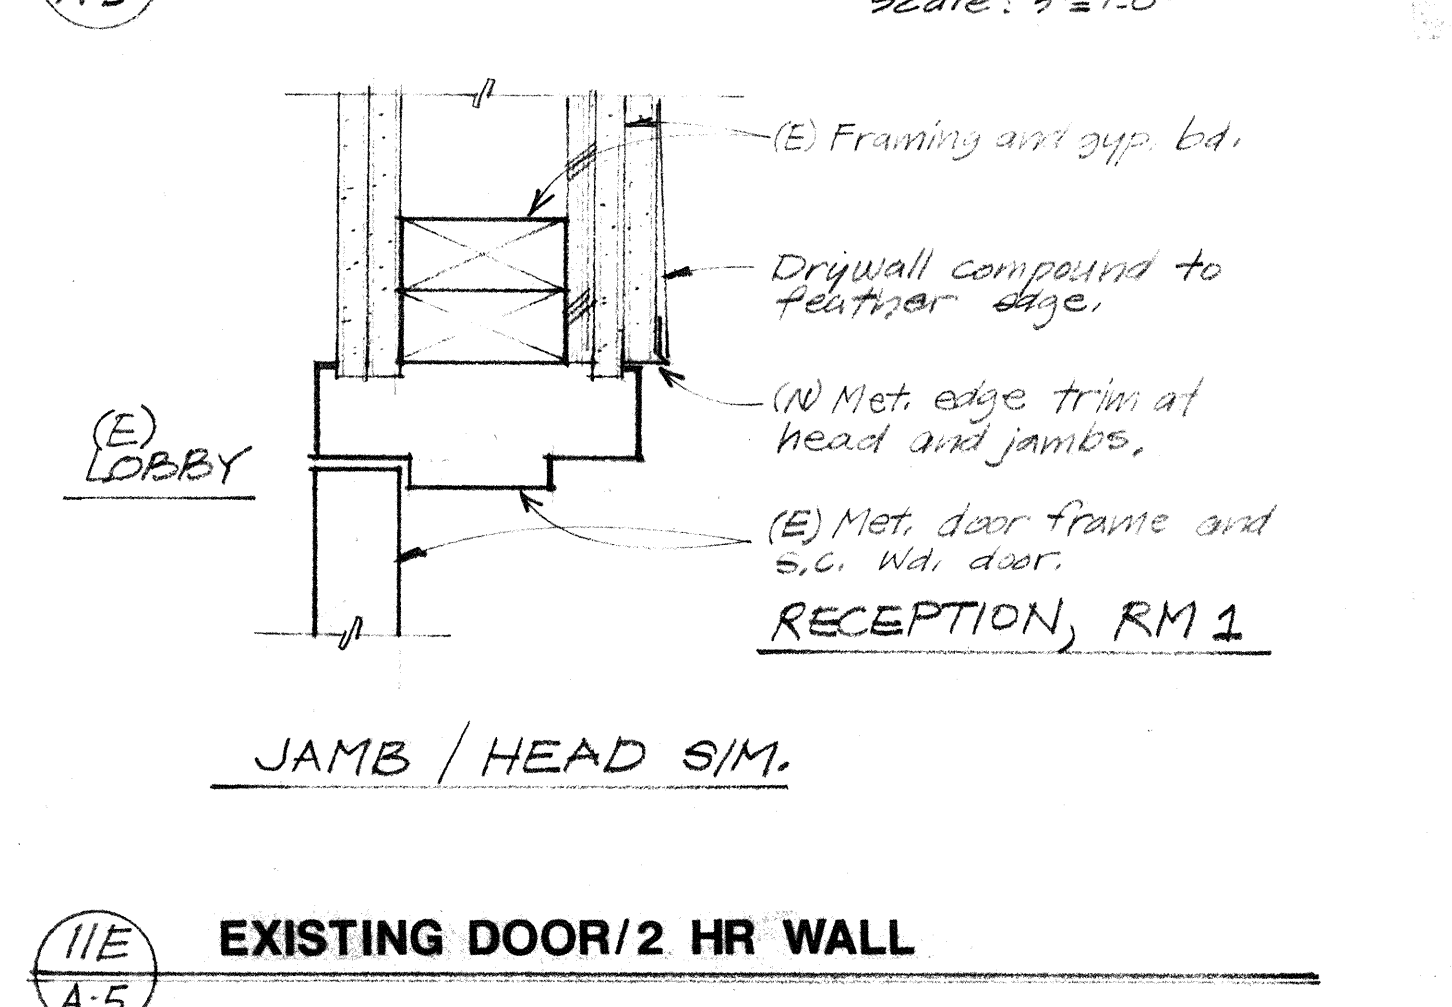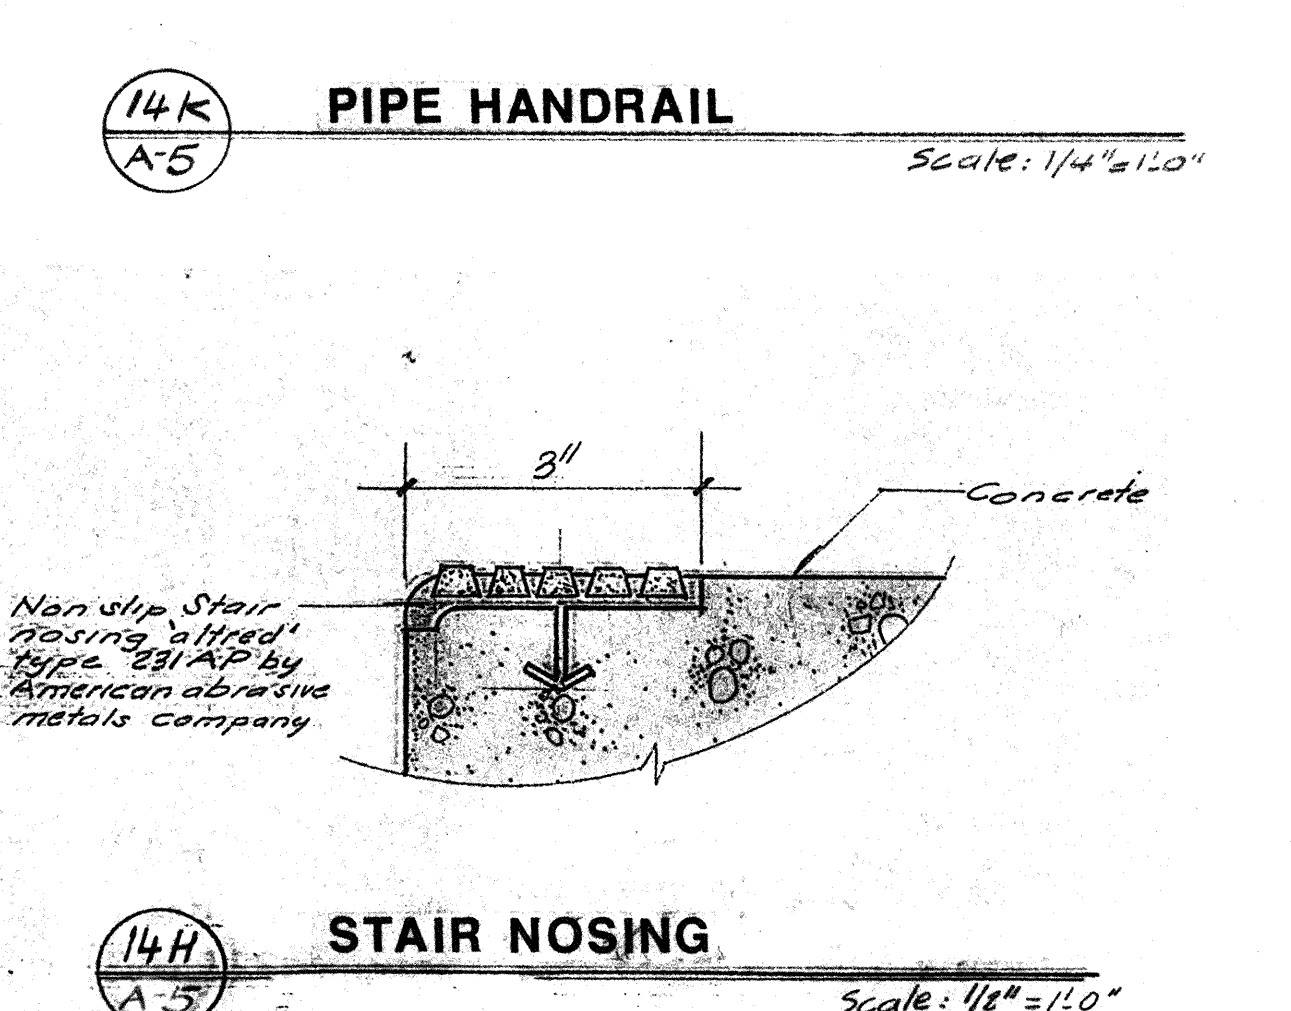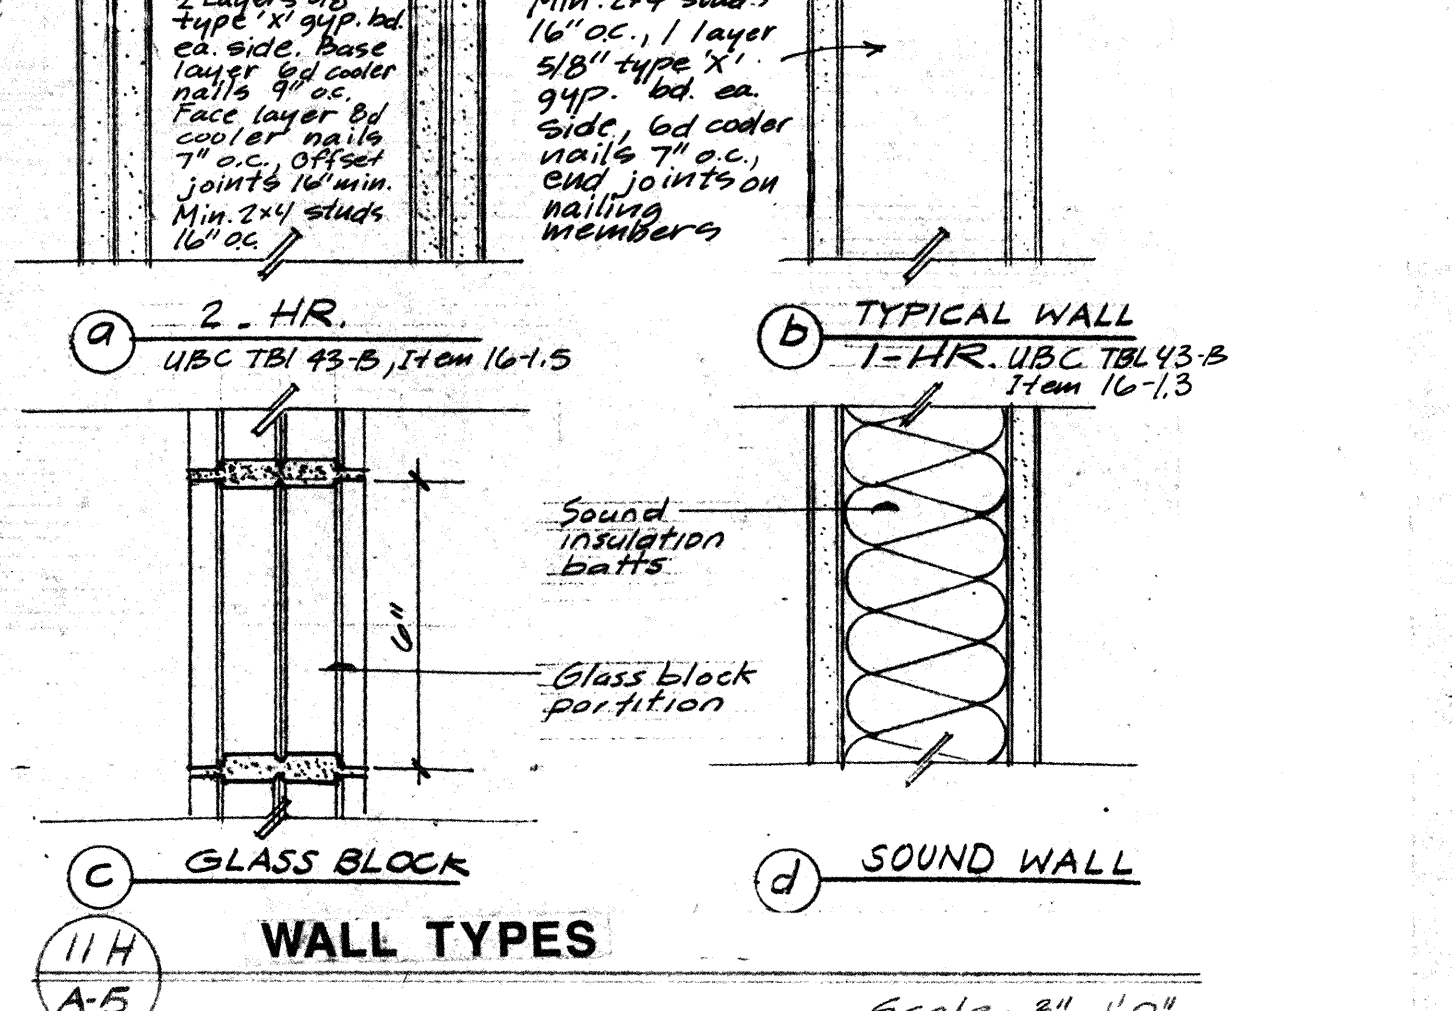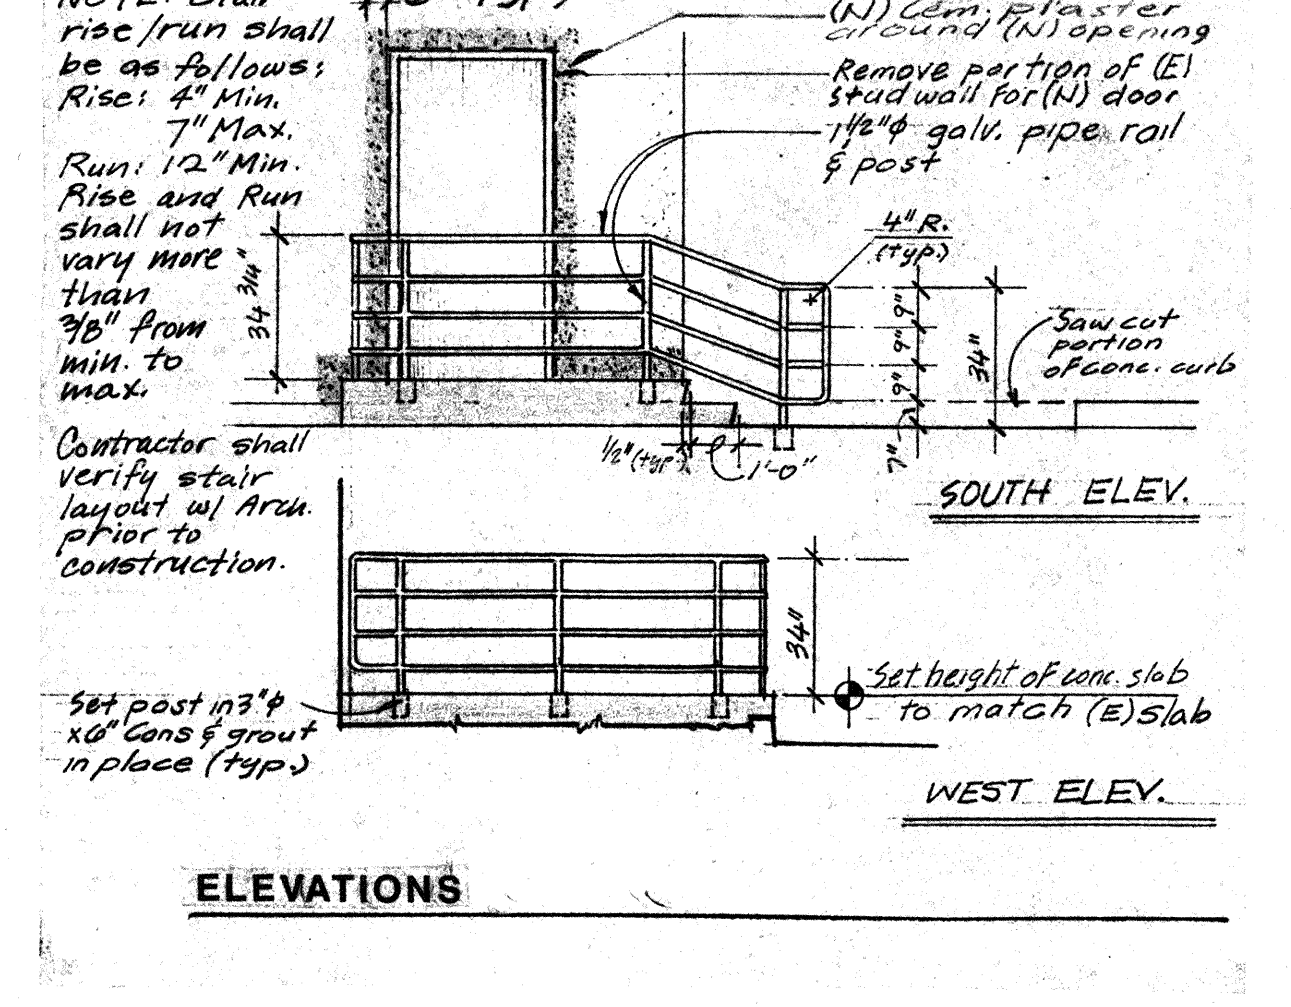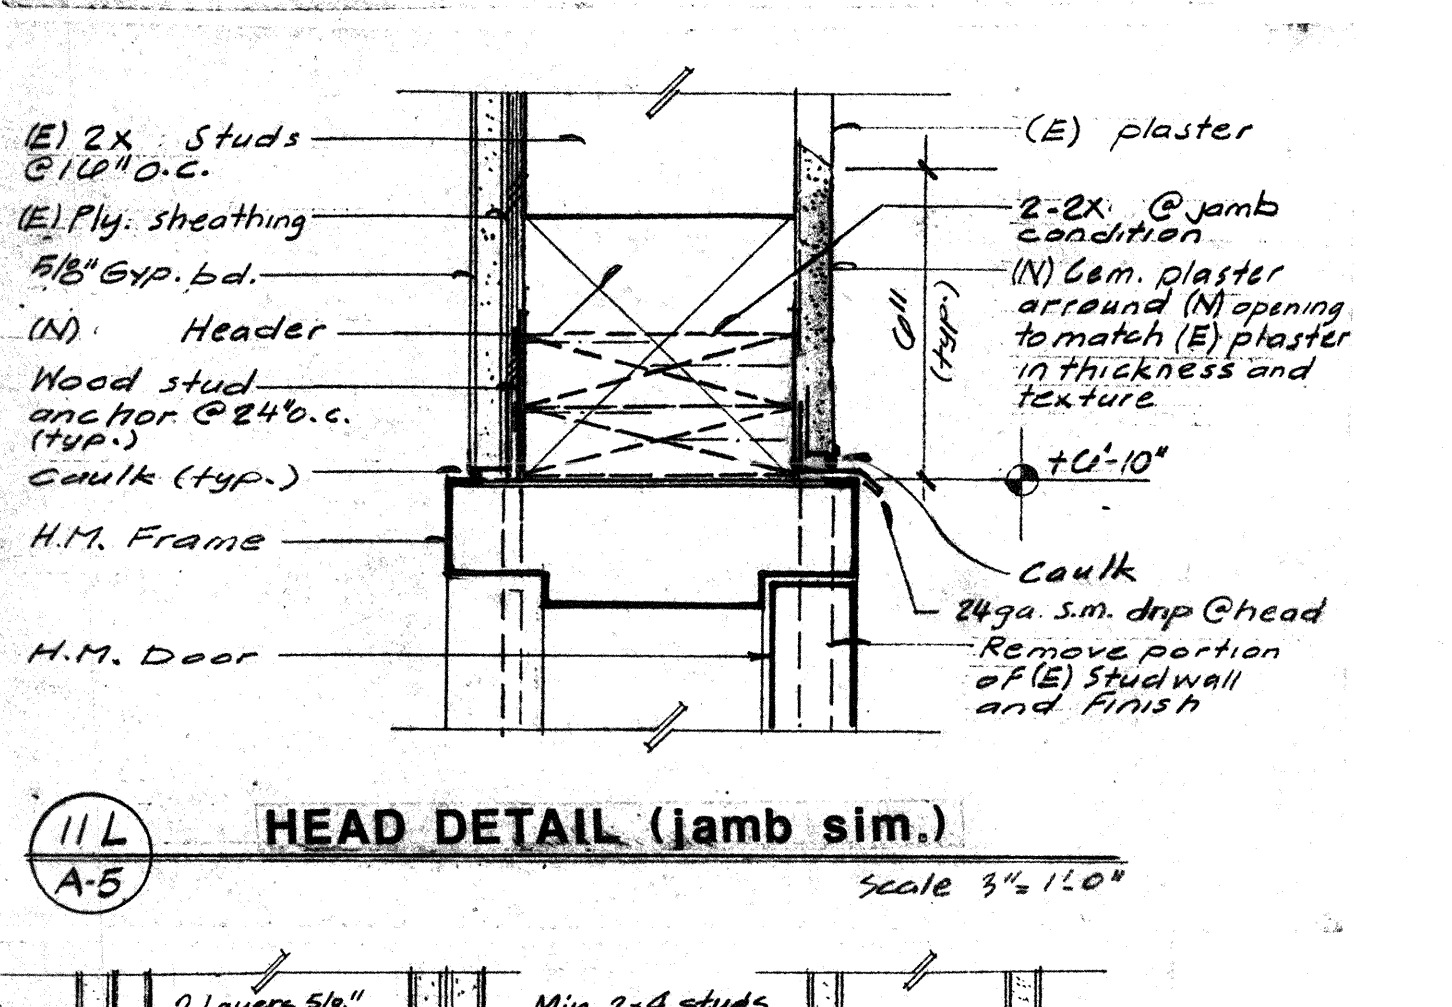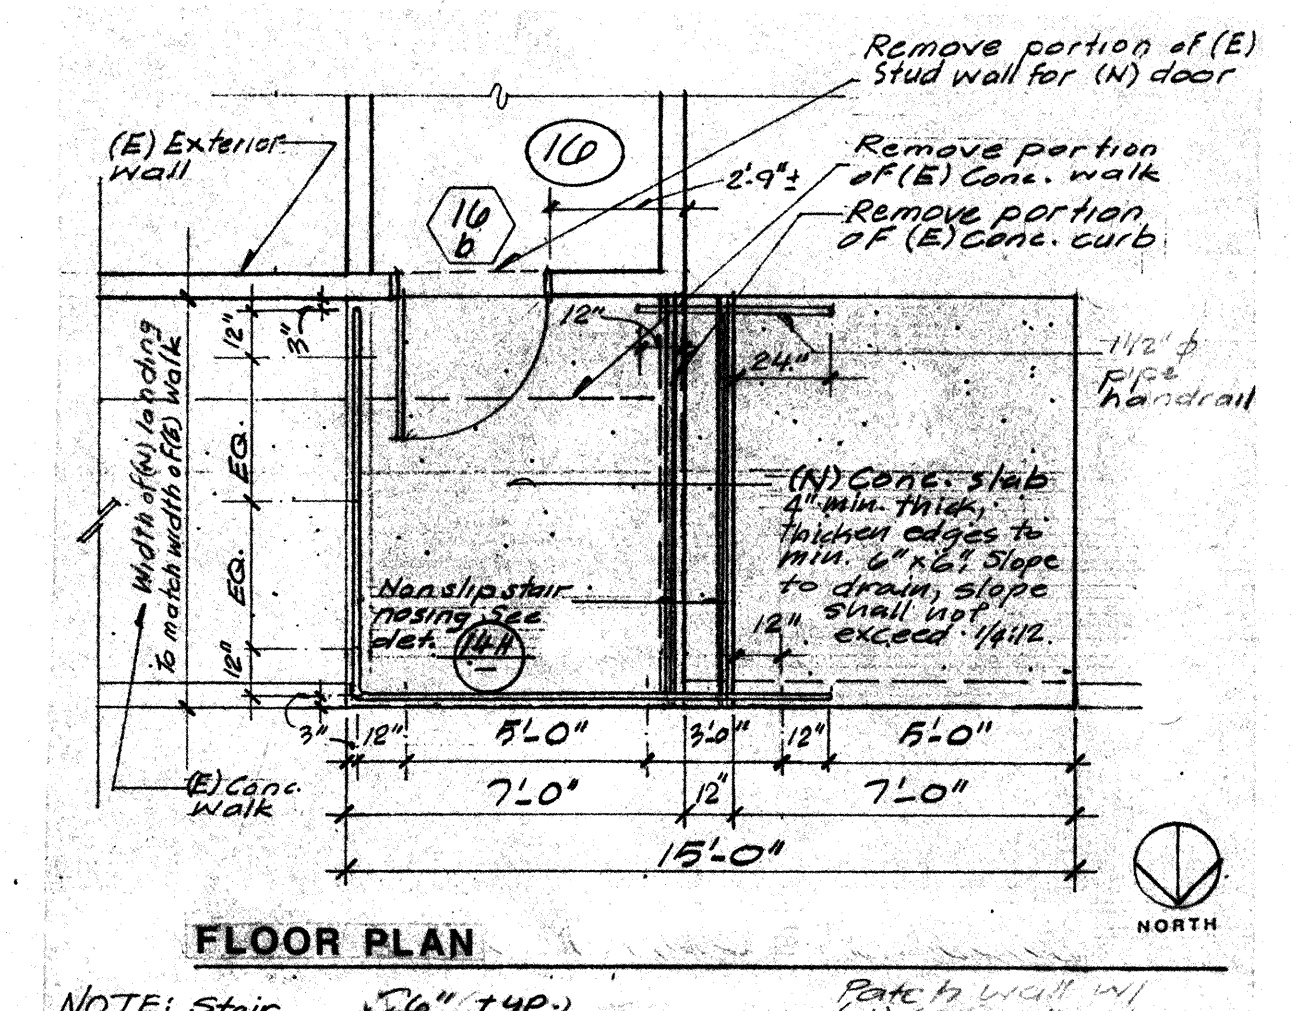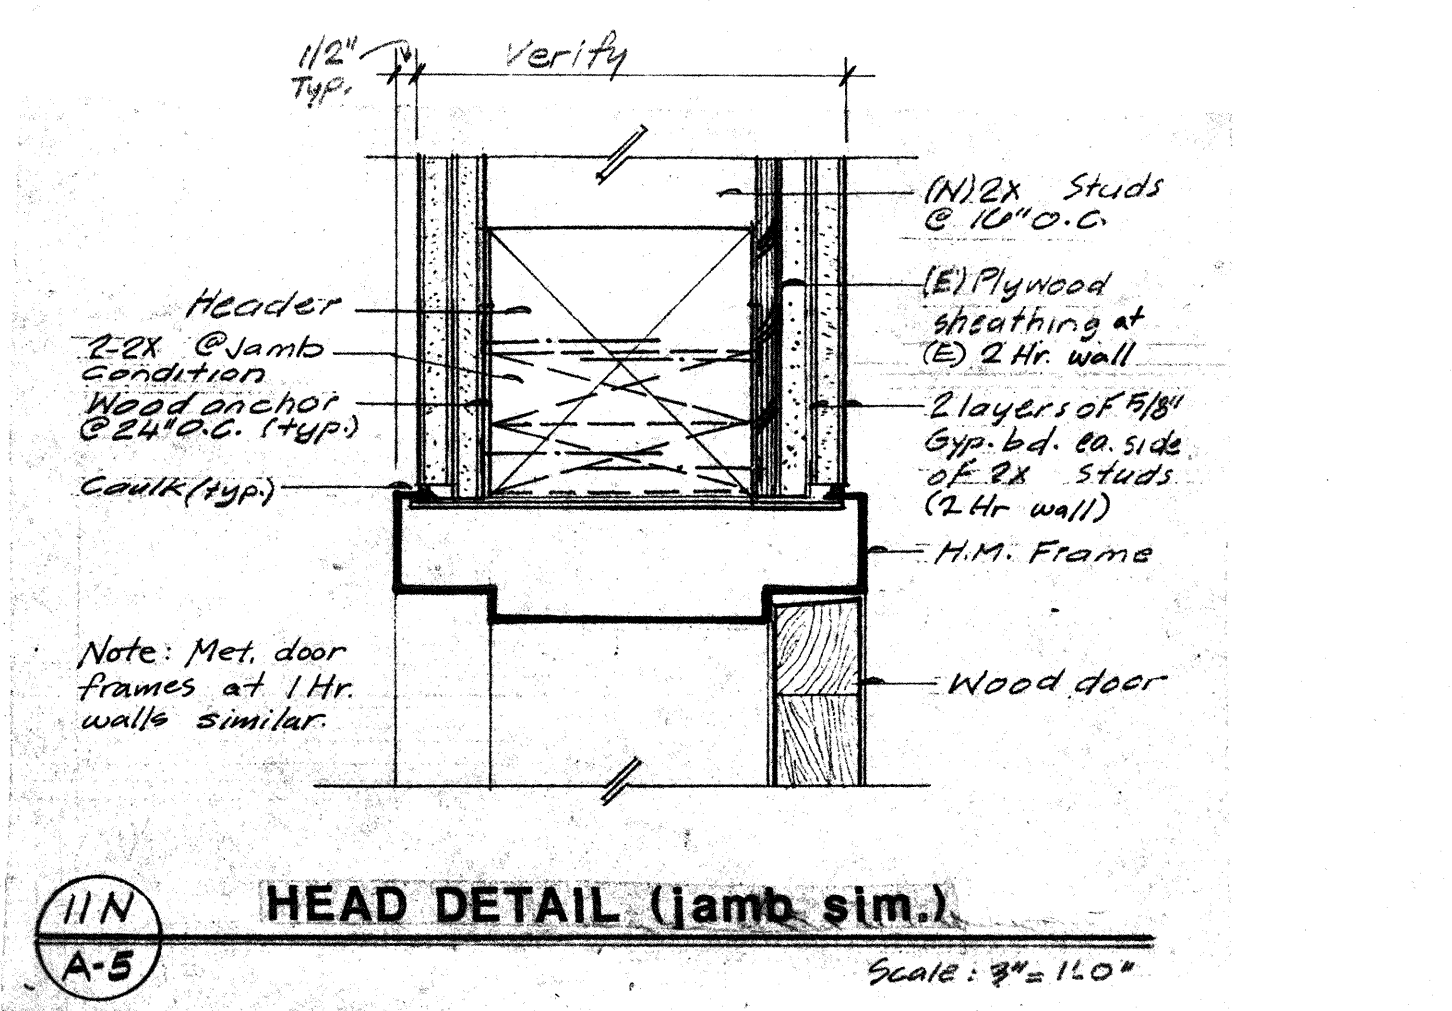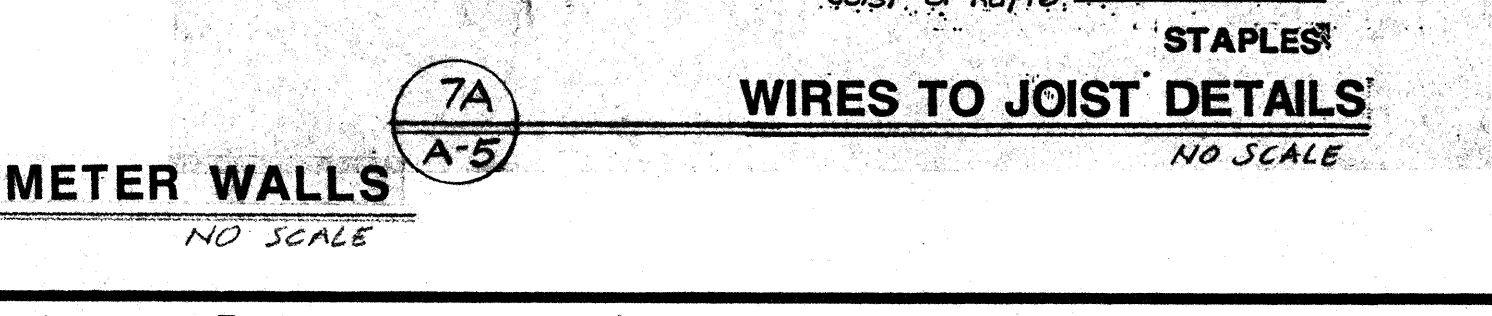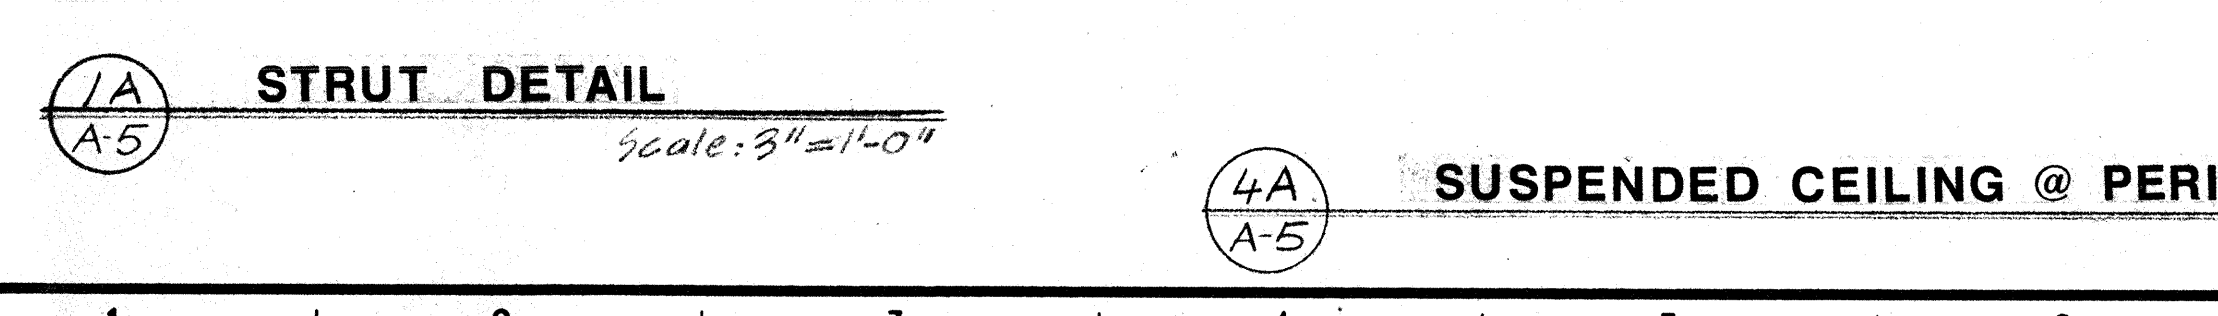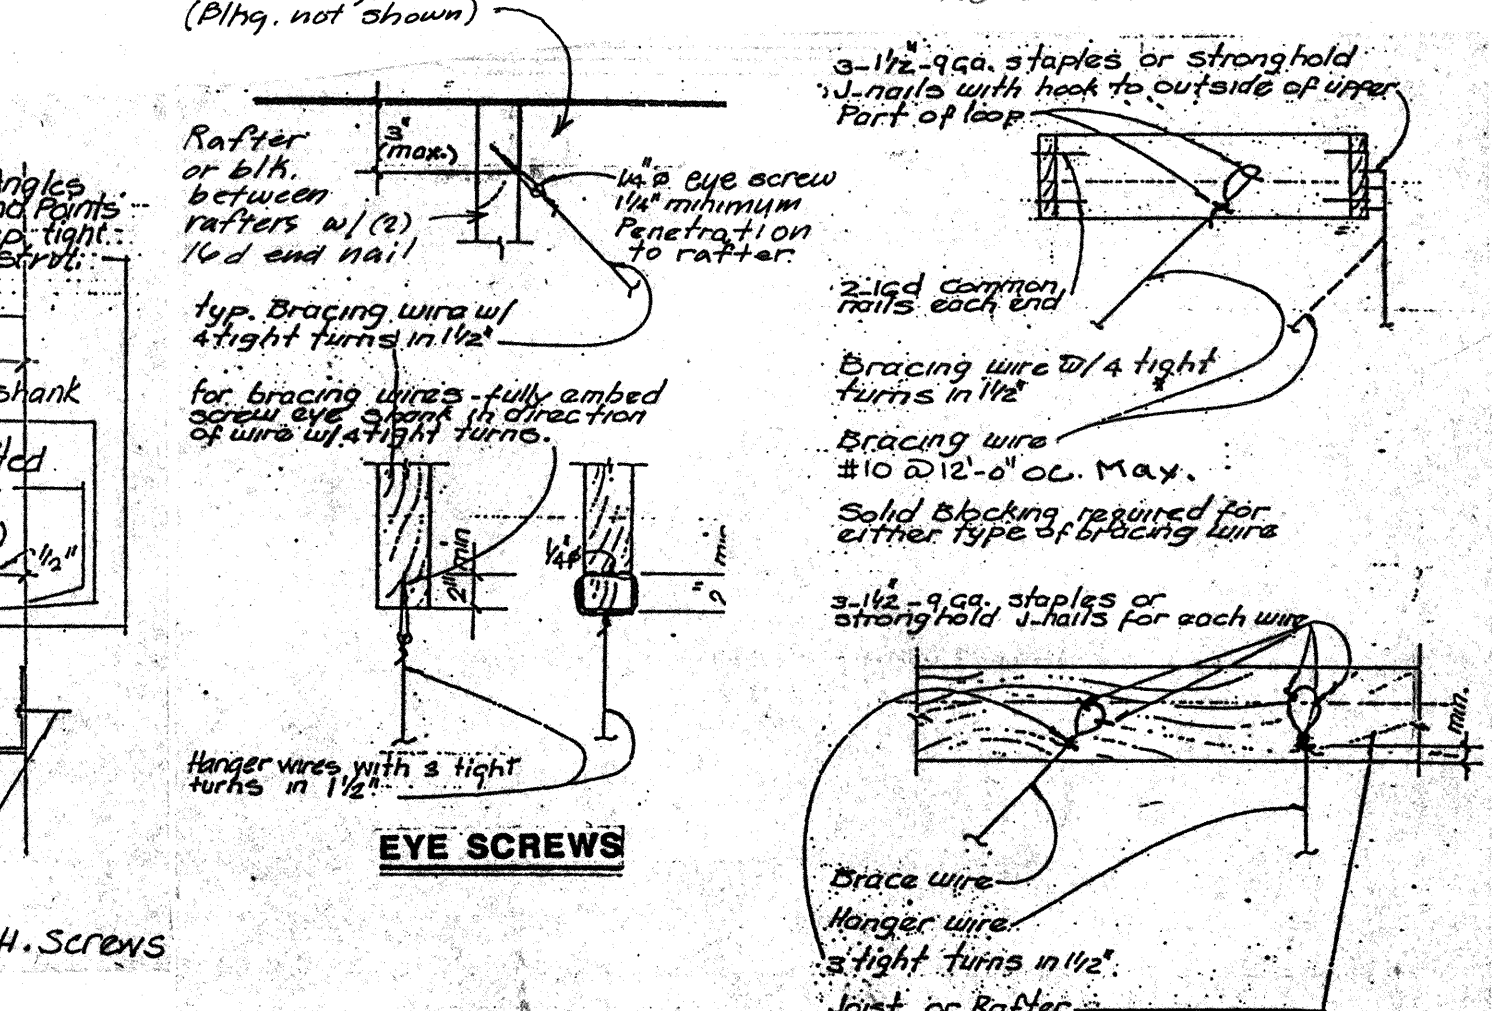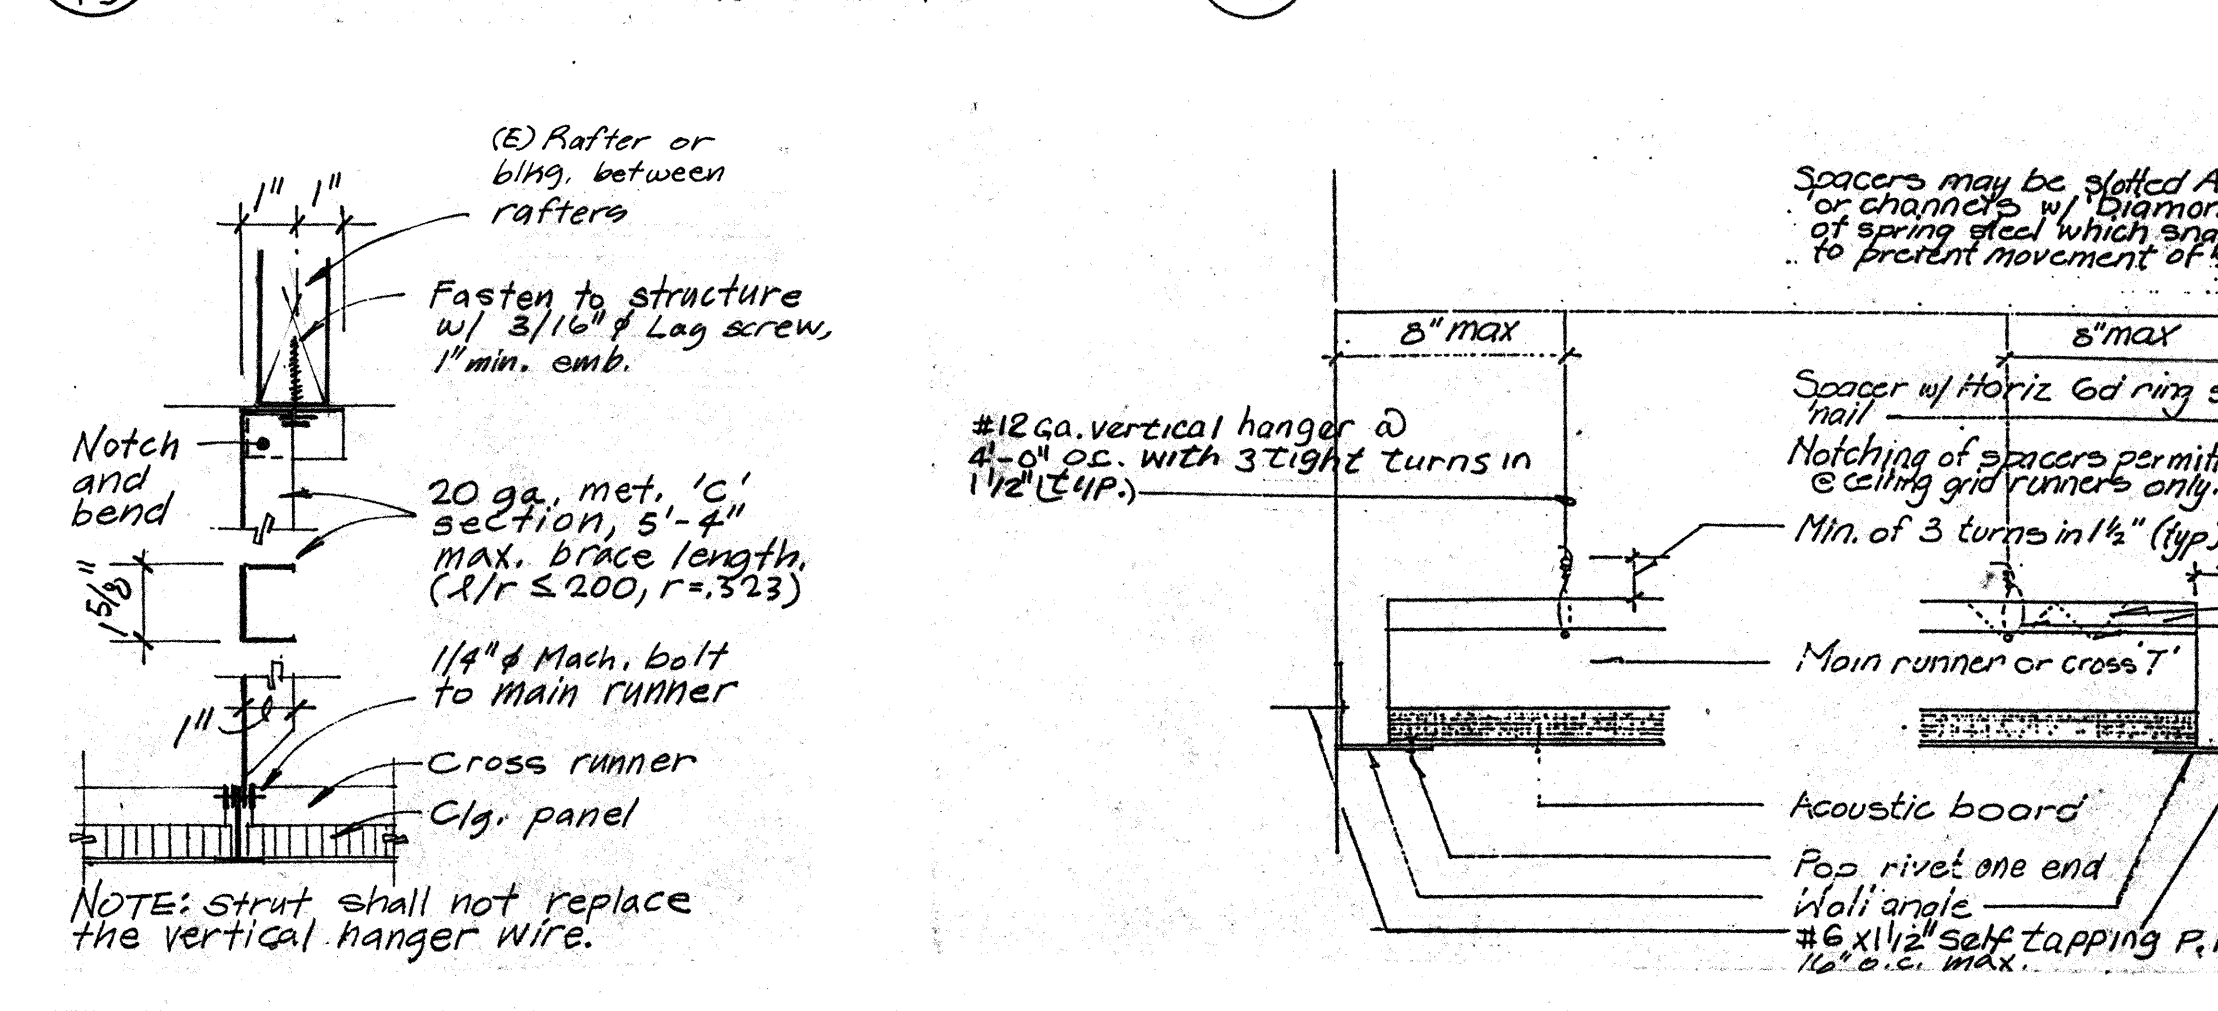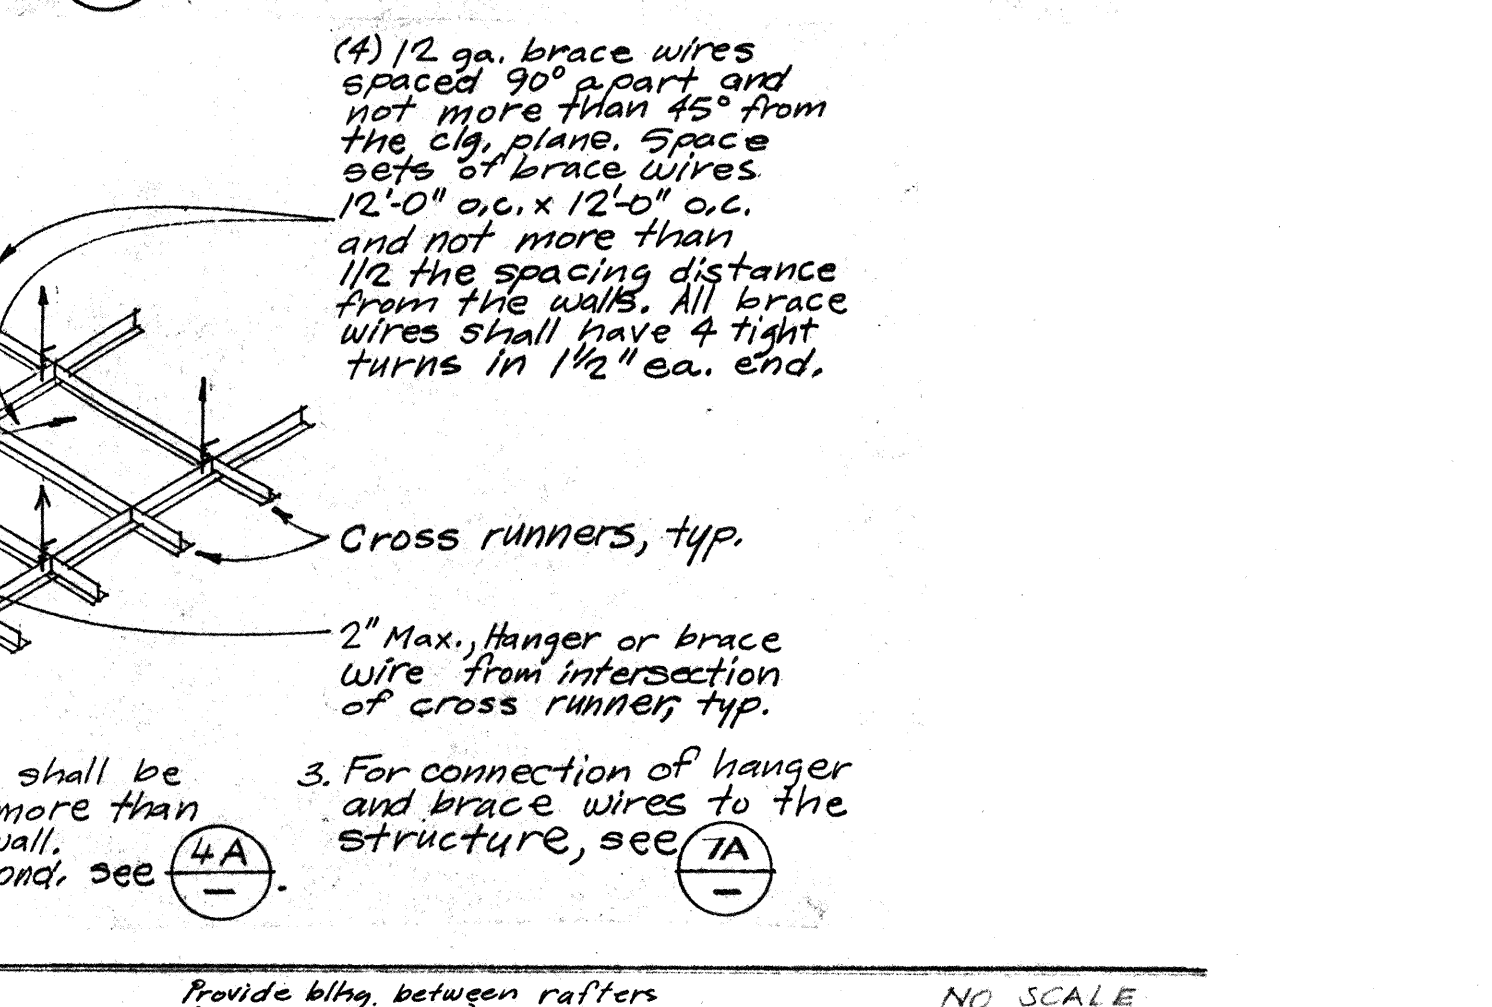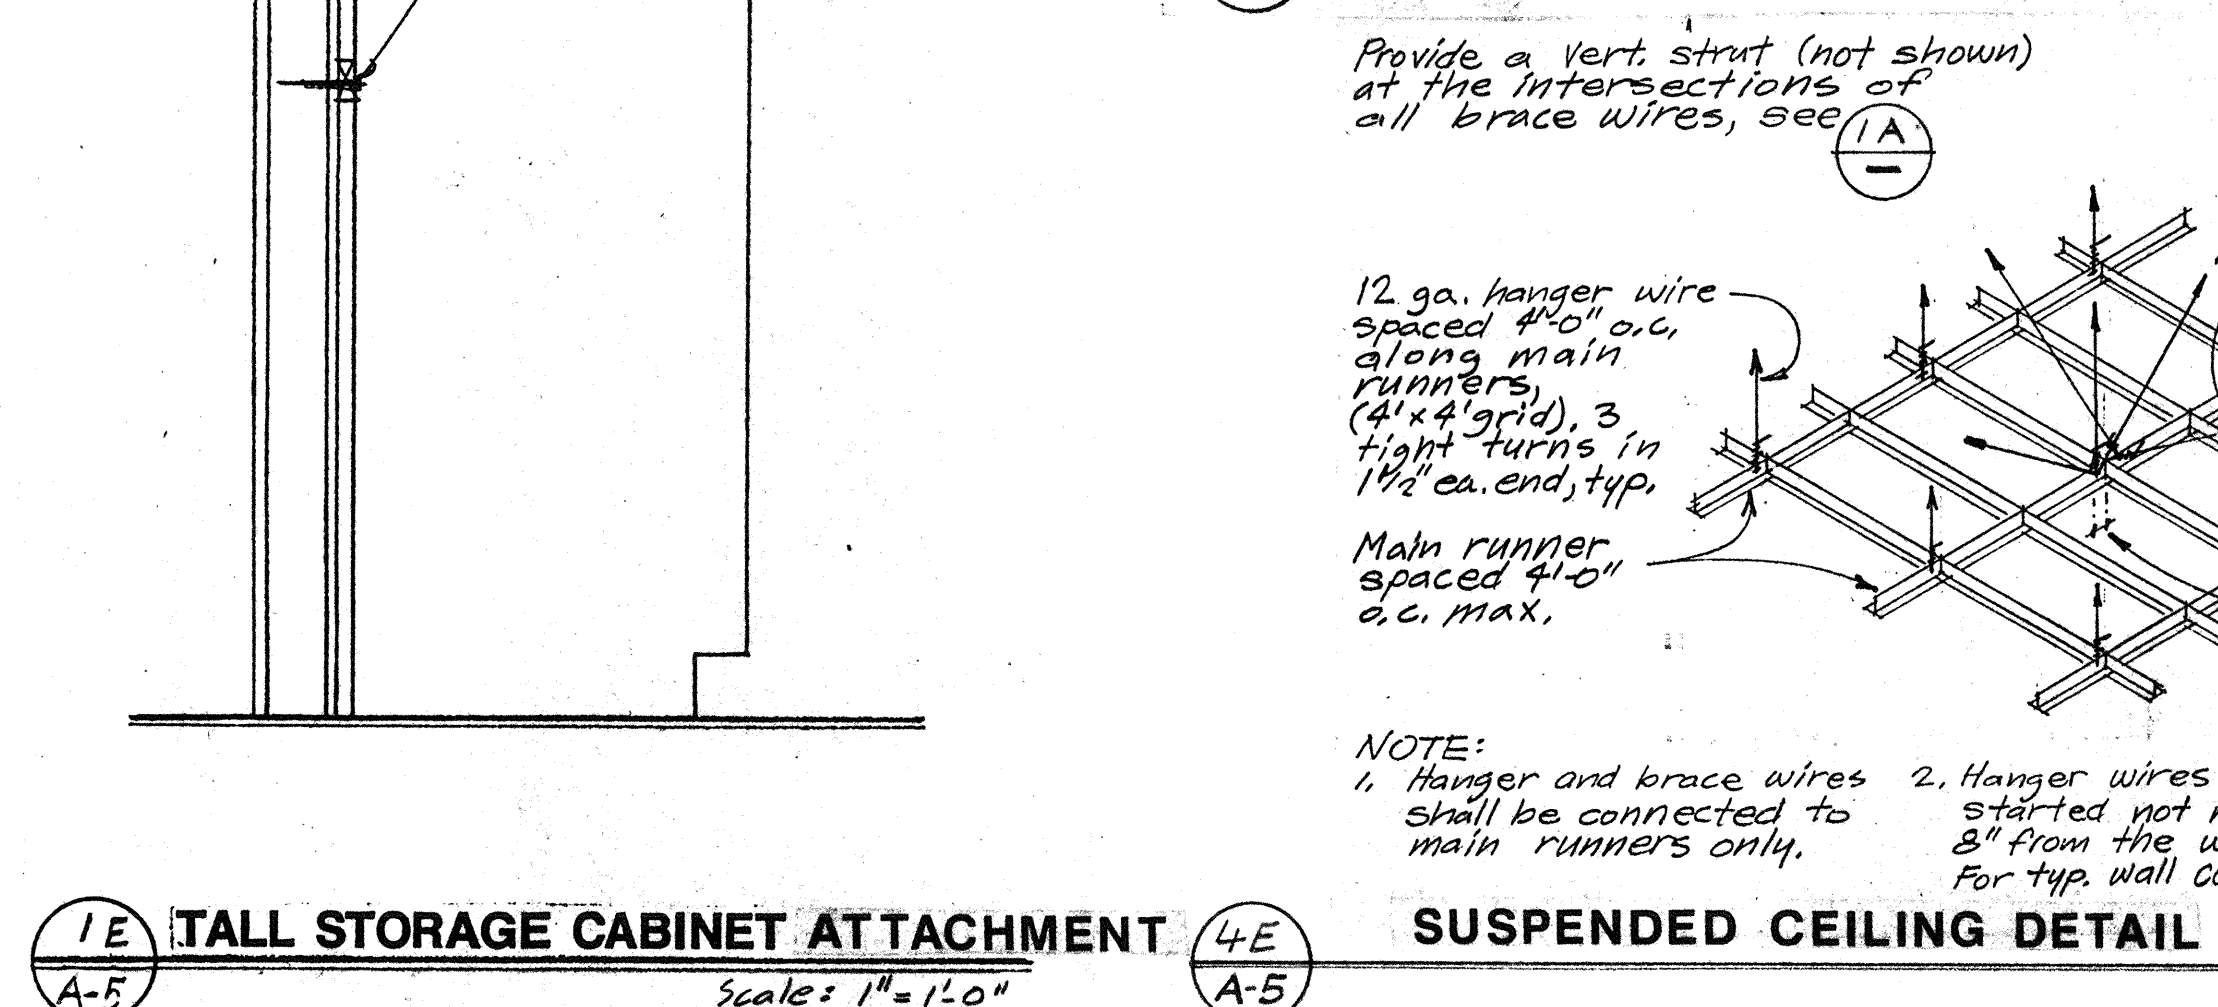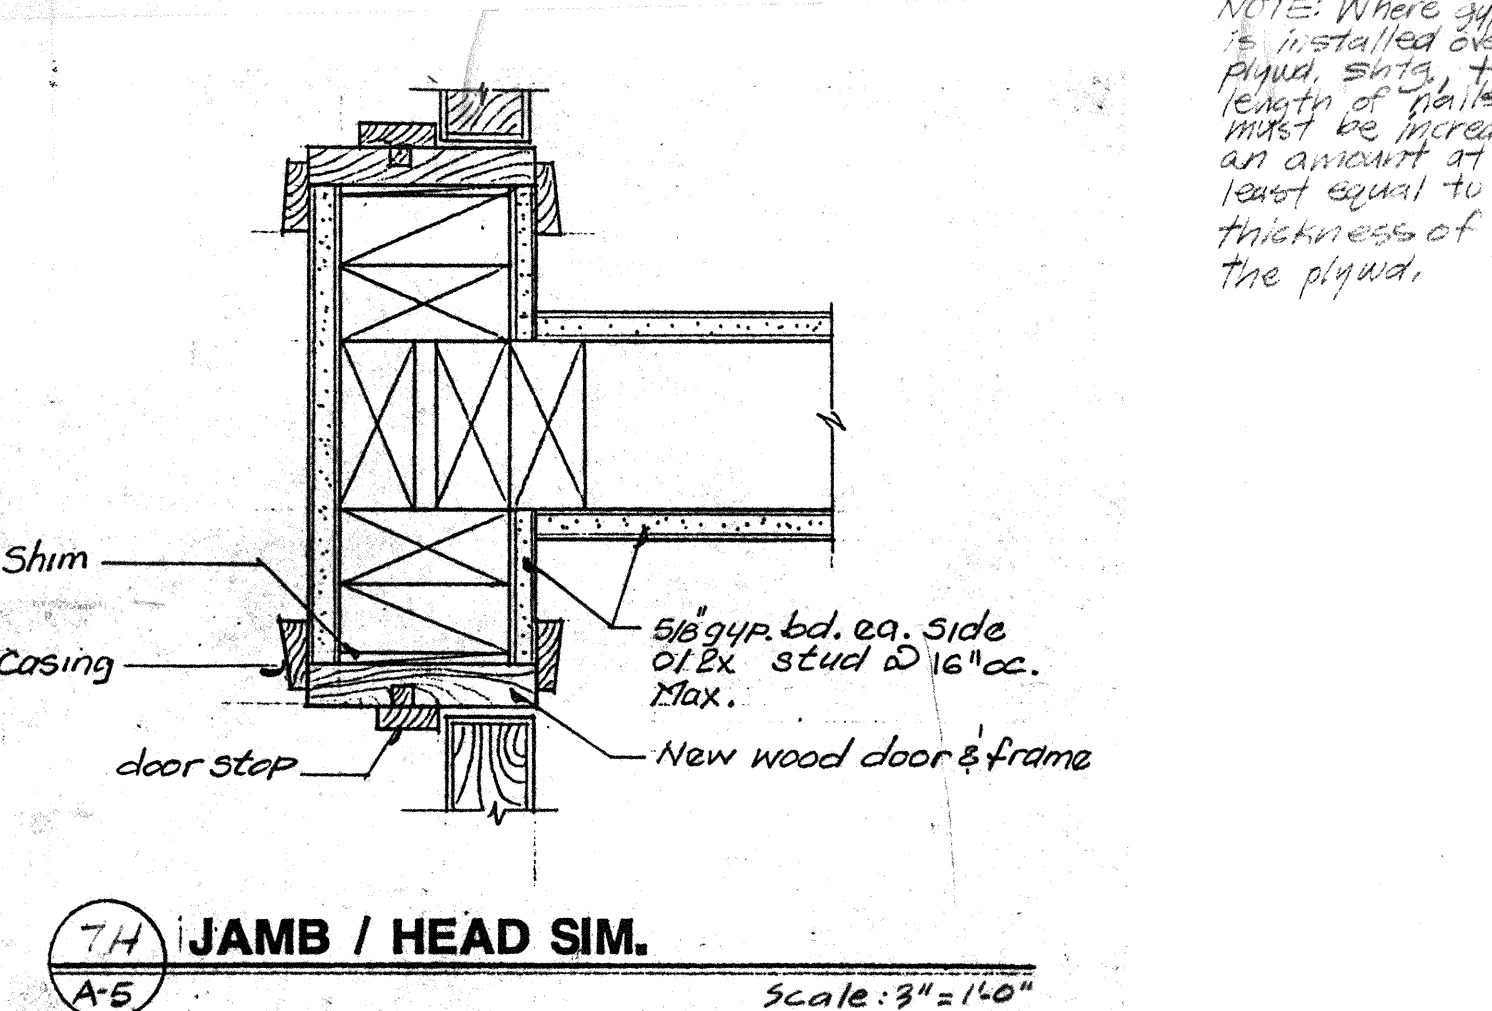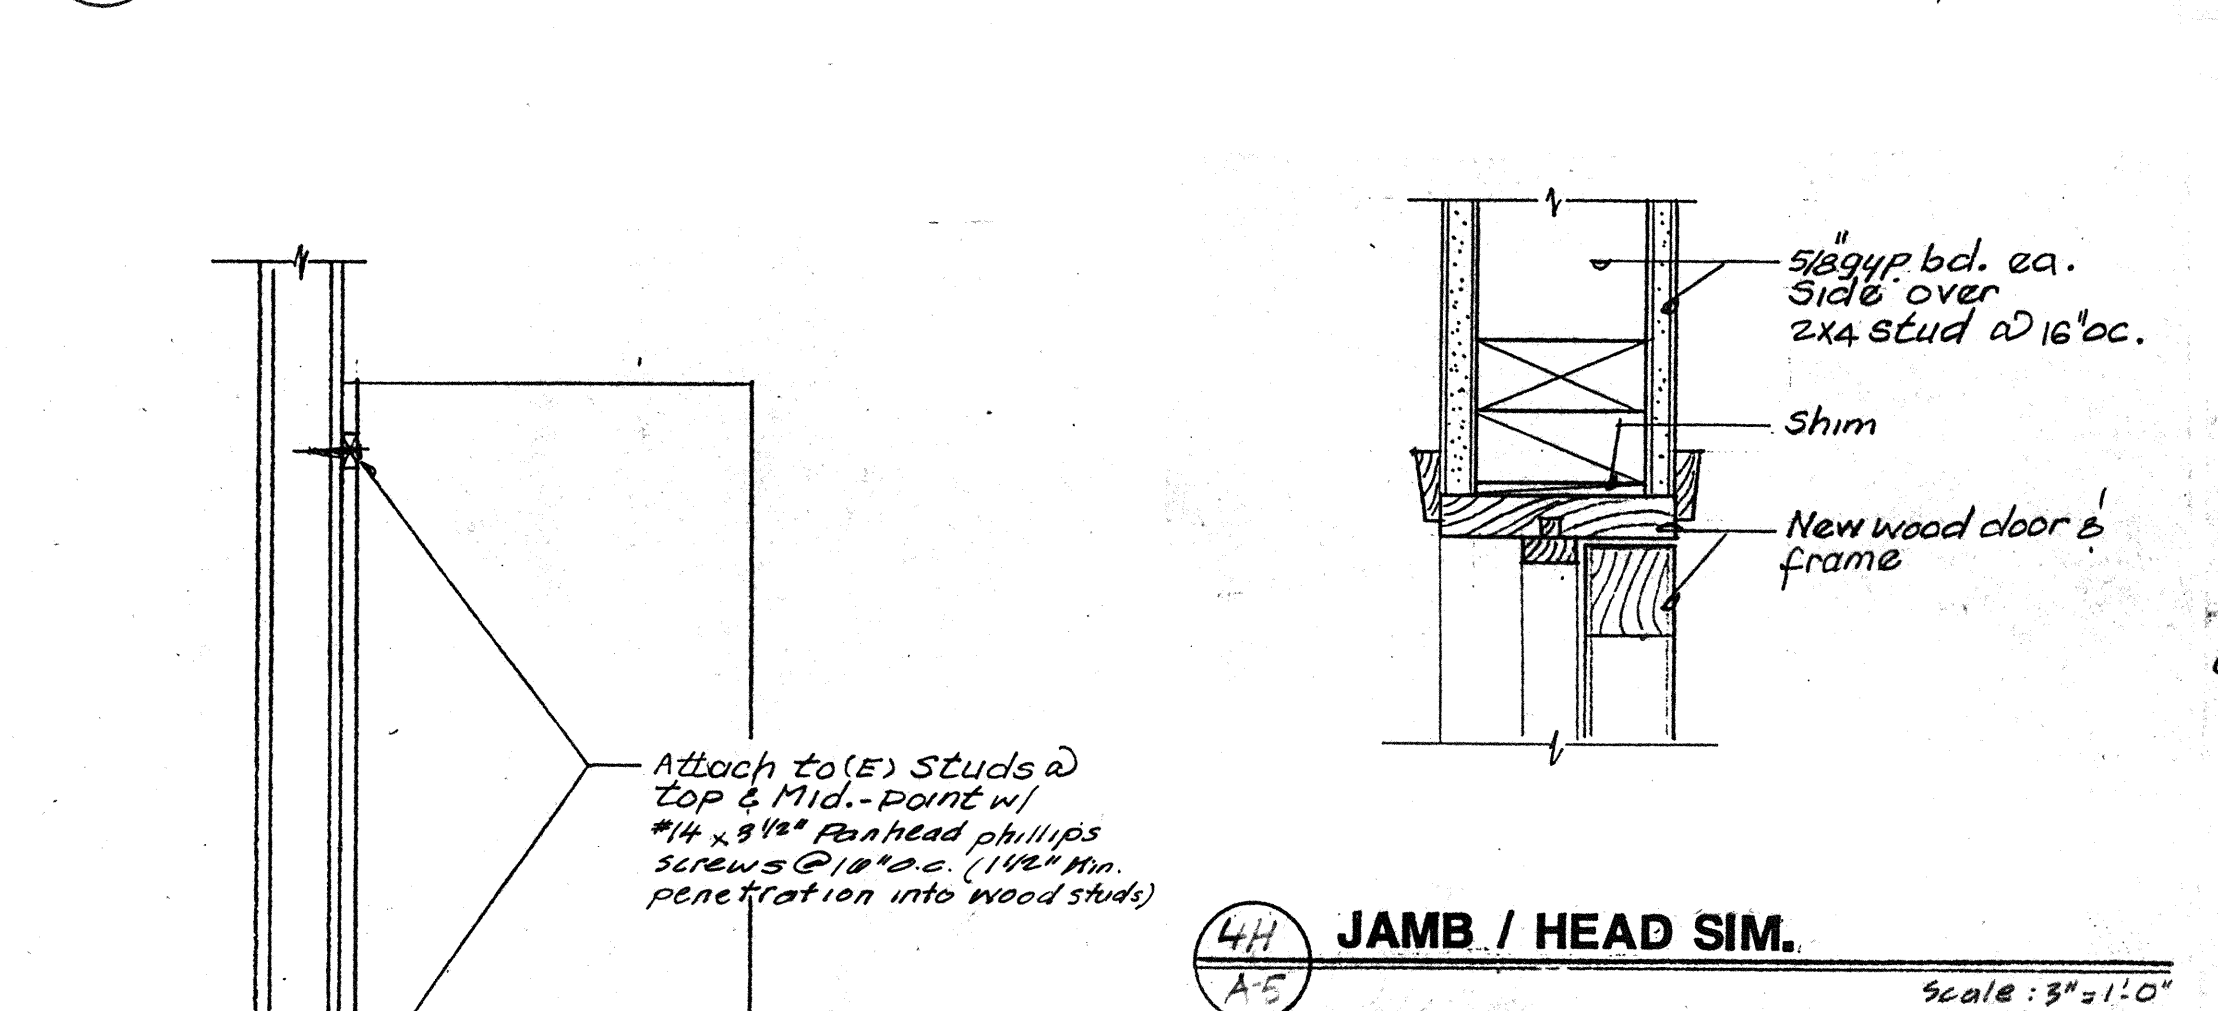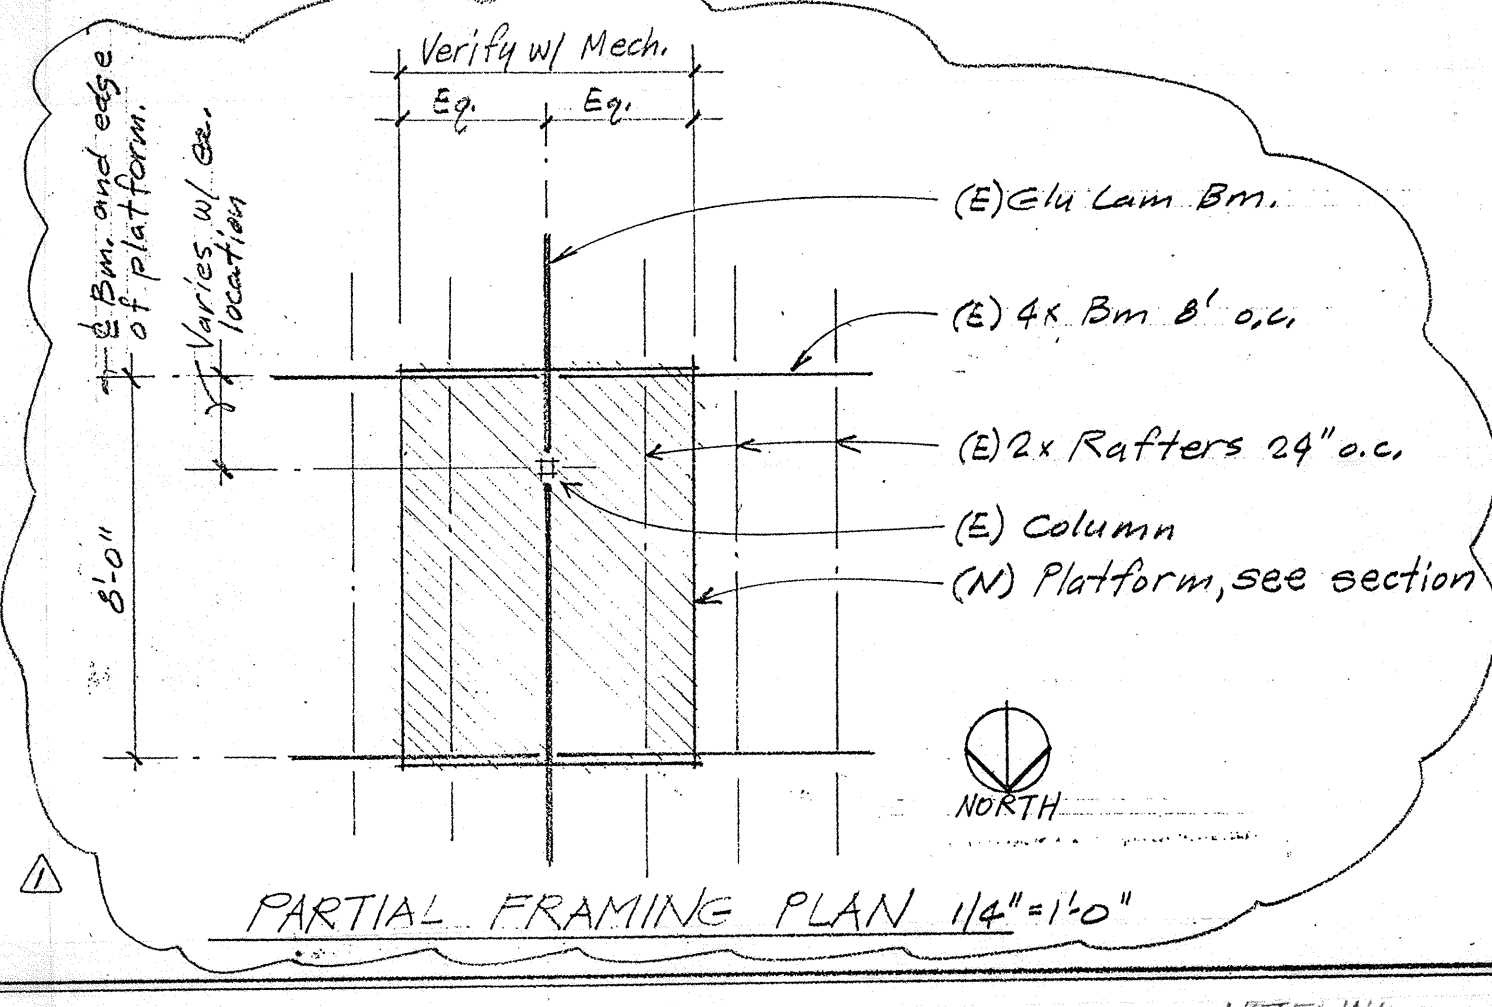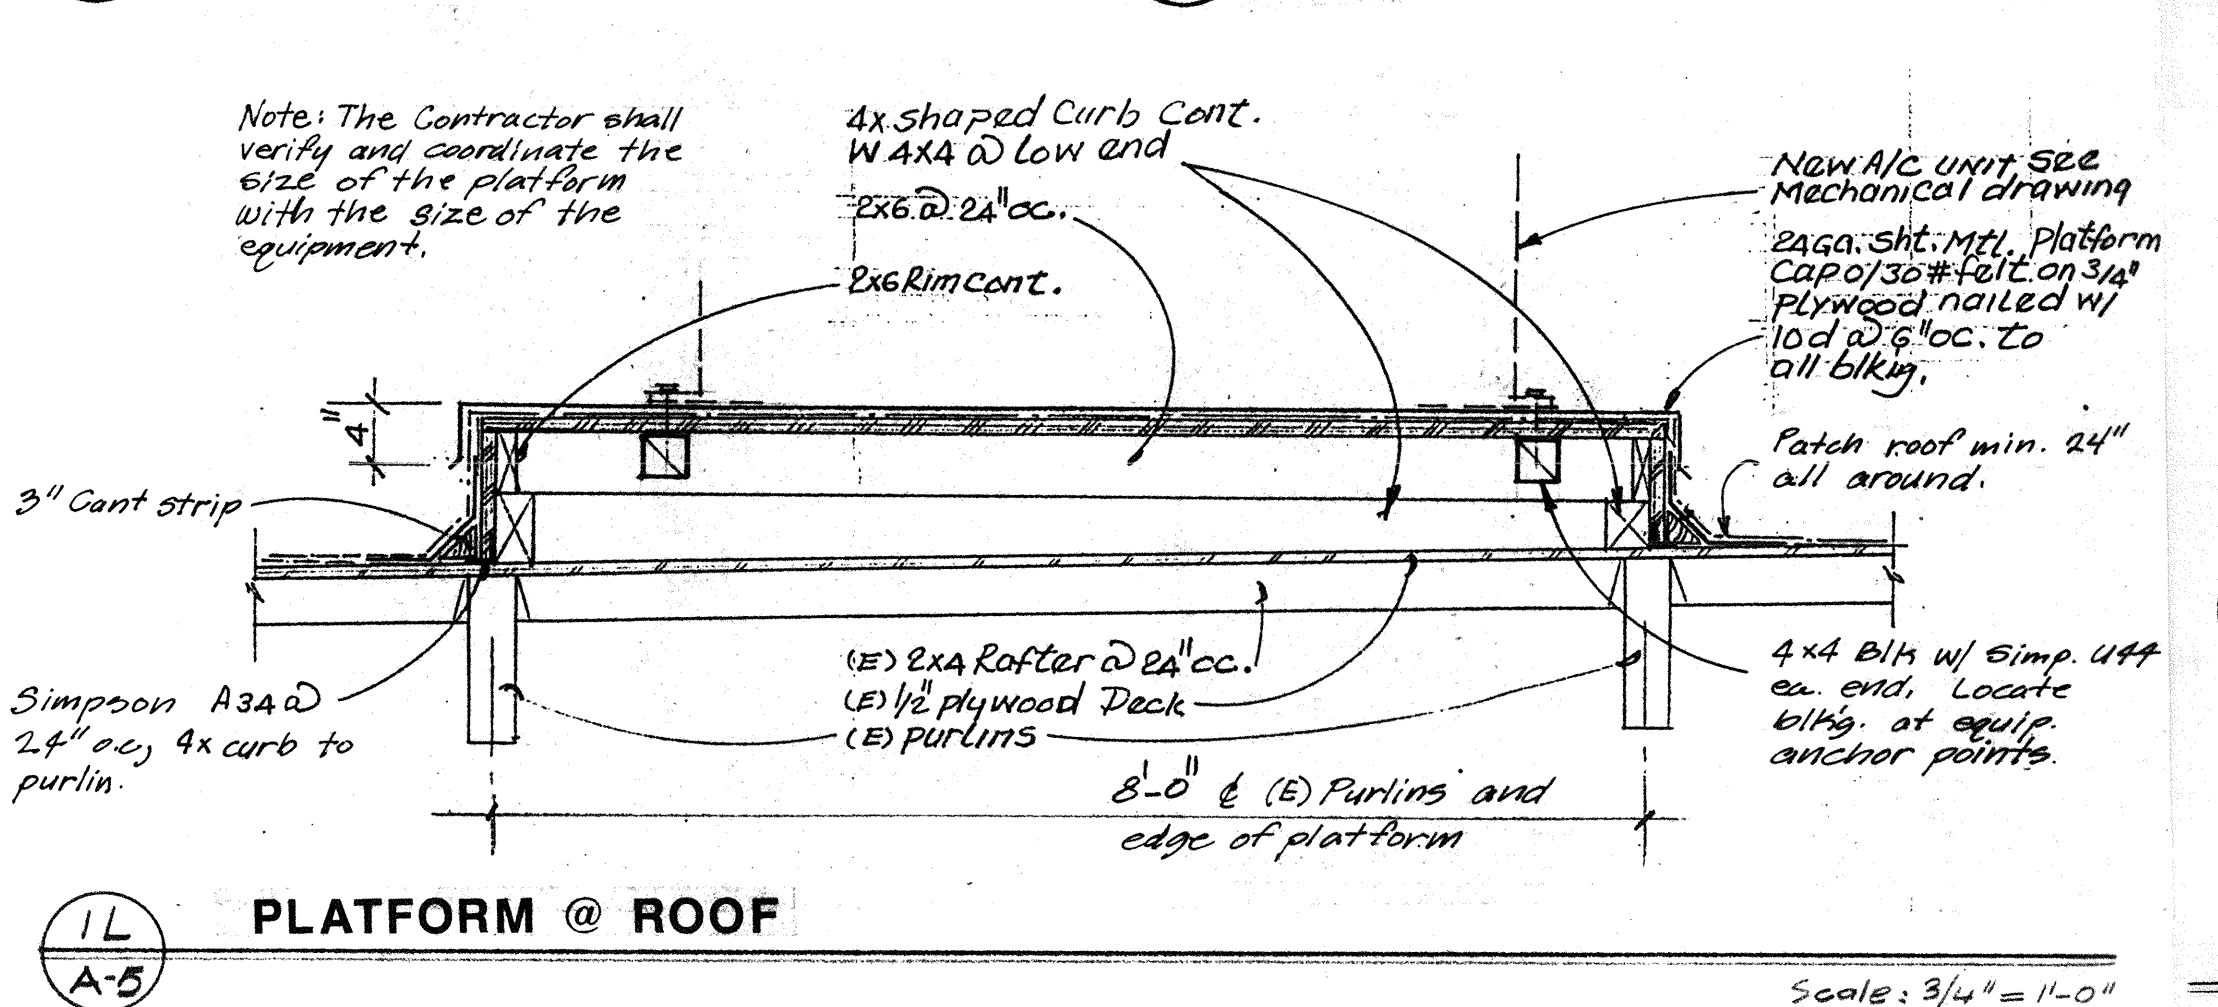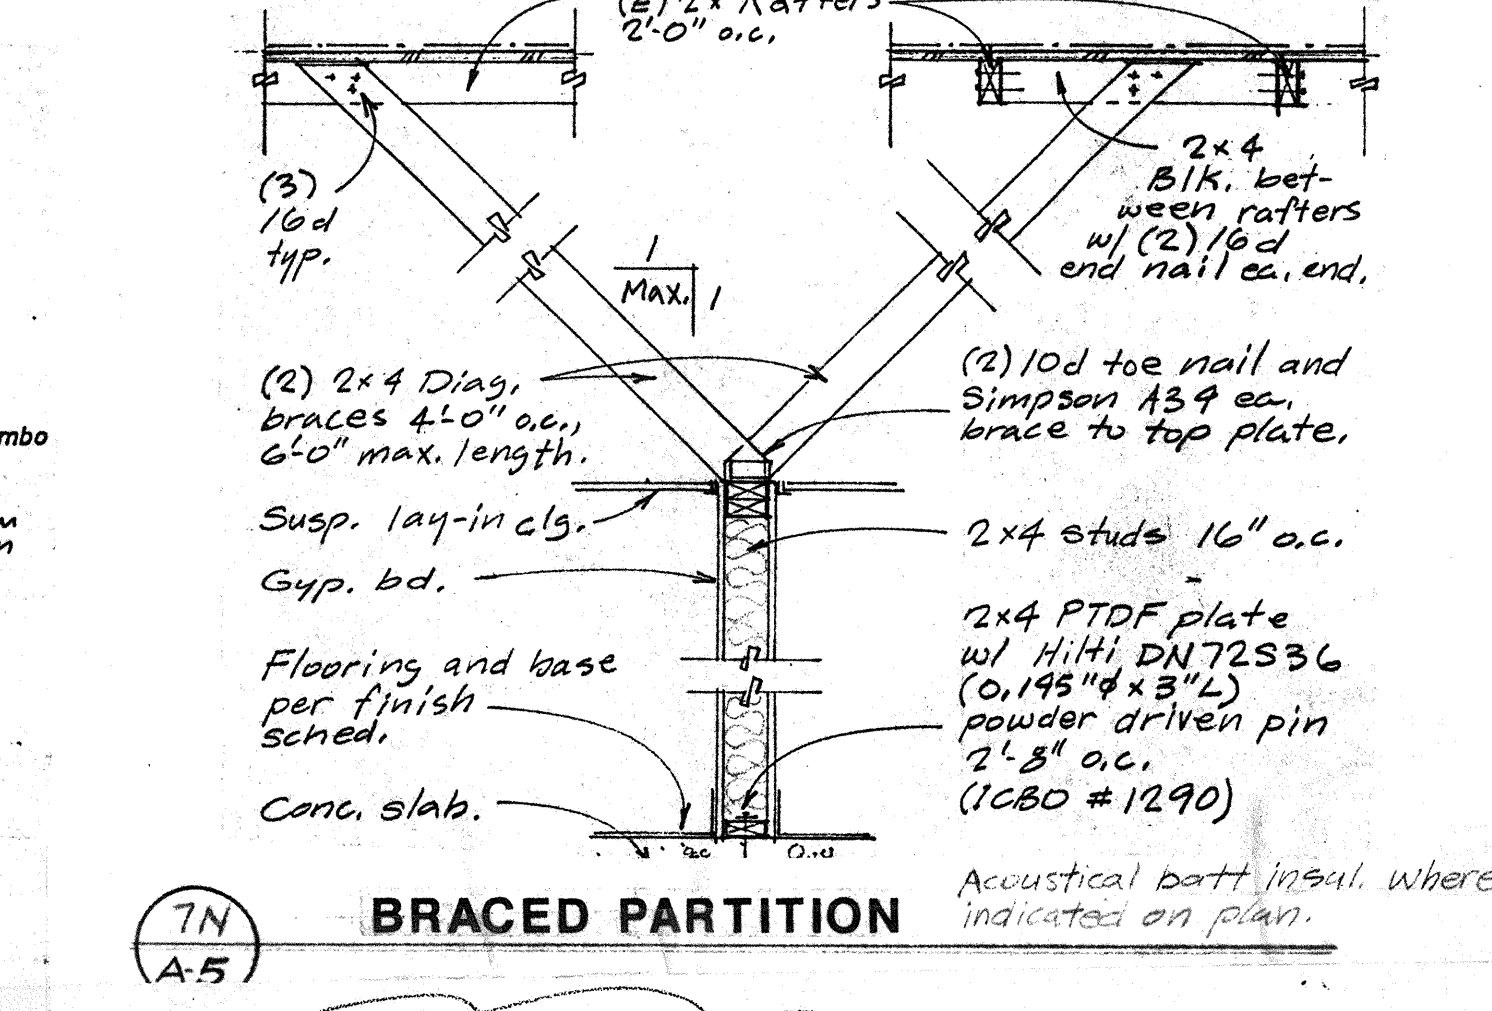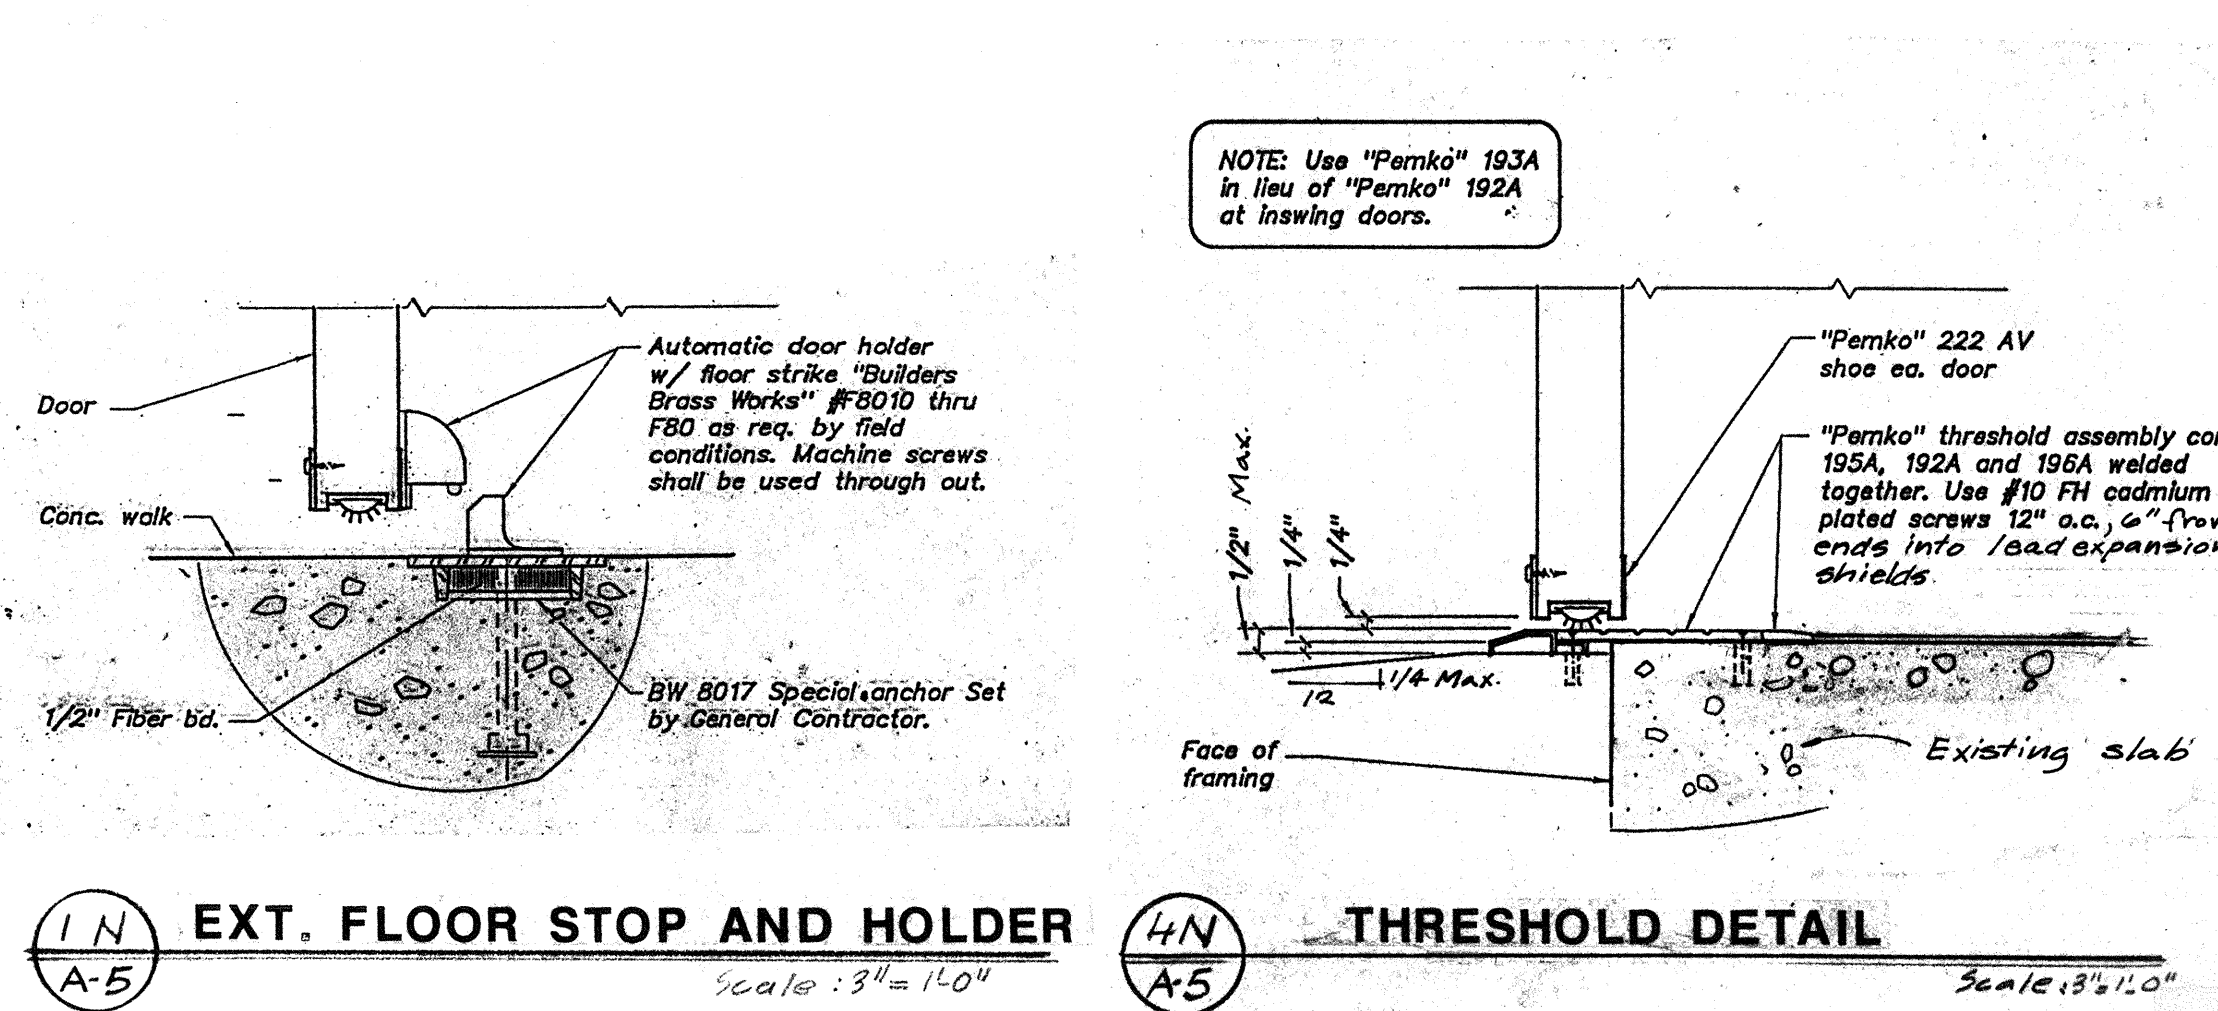

Materials Keying Legend

CITY OF FRESNO
DEVELOPMENT DEPARTMENT
JUL 02 1991

Any changes to these plans must be approved by the
Development Department. The signature of a permit
holder for any project is the right to use the City of
Fresno's name.

Edwin S. Darden Associates, Inc.
ARCHITECTURE AND PLANNING
Edwin S. Darden FAIA, Edwin S. Darden Jr. AIA
Martin E. Dietz AIA CCS, Edwin C. Goodwin AIA
1177 W. Shaw Avenue / Fresno, California 93711 / 209 222-7463
987 One Street / San Luis Obispo, California 93401 / 805 545-3965


Consultant
VALLEY CHILDREN'S HOSPITAL PROFESSIONAL CENTER
FOUNDATION OFFICE PROJECT
1990 EAST GETTYSBURG FRESNO CA, Project

DETAILS

Drawing


Designed By: Project No.: 9116
Drawn By: Scale:
Checked By:
Reviewed By:
Date: Sheet: of:

A.5

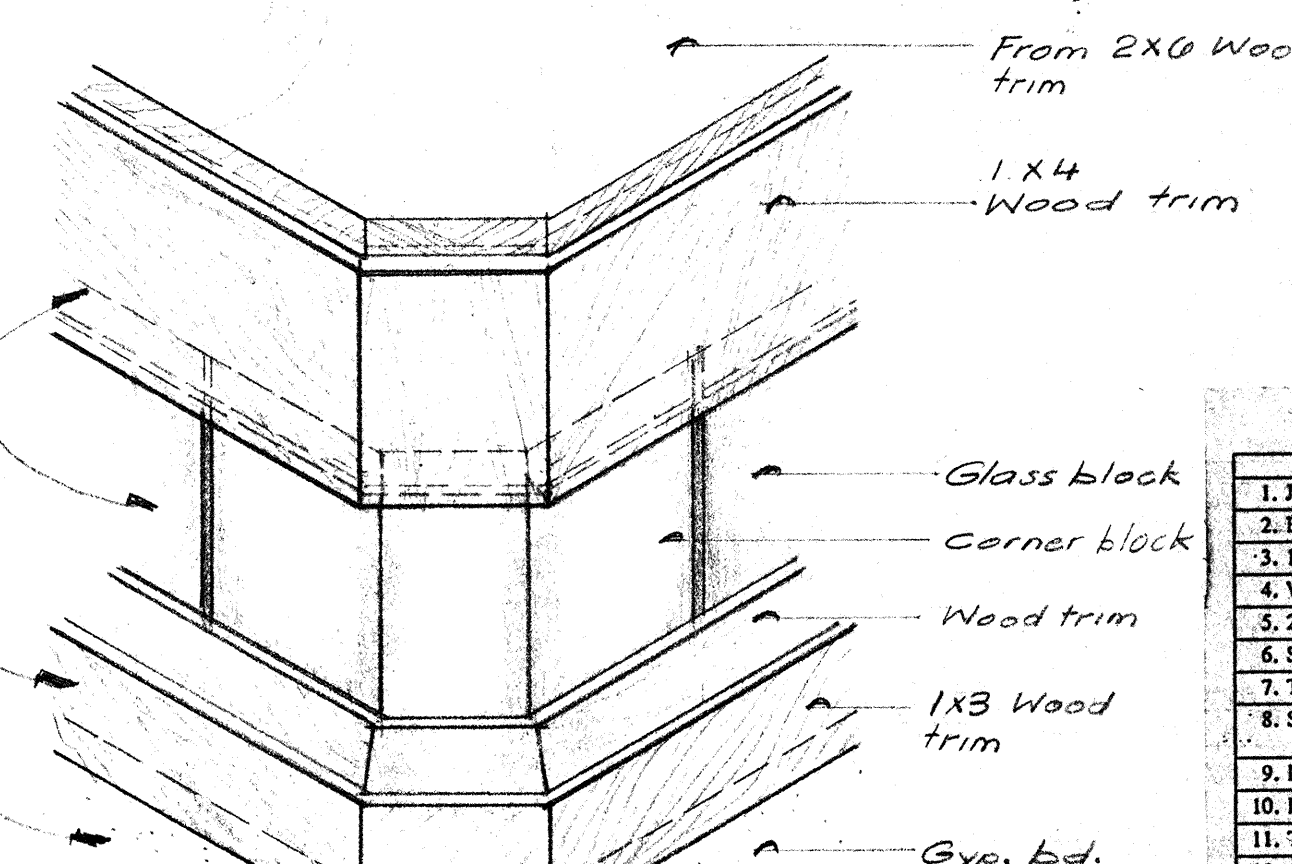


12N ISOMETRIC

- Common or box nails may be used except where otherwise specified.
- Spacing or deformed shank.
- Common shank.
- Wells spaced at 6 inches on center at edges, 12 inches at intermediate supports (10 inches at intermediate supports for floors), except 6 inches at all supports where spans are 48 inches or more. For maling of plywood and particleboard diaphragms and shear walls, refer to Section 05110.
- 6d. Nails for wall sheathing may be common, but not case.
- Corrosion-resistant siding or casing nails conforming to the requirement of Section 25100.
- Fasteners spaced 3 inches on center at exterior edges and 6 inches on center at intermediate supports.
- Corrosion-resistant roofing nails with 7/16-inch diameter head and 1/2-inch length for 1/2-inch sheathing and 1/2-inch length for 5/8-inch sheathing conforming to the requirement of Section 05110.
- Corrosion-resistant spikes with nominal 7/16-inch crowns and 1/4-inch length for 1/2-inch sheathing and 1/2-inch length for 5/8-inch sheathing conforming to the requirement of Section 05110.

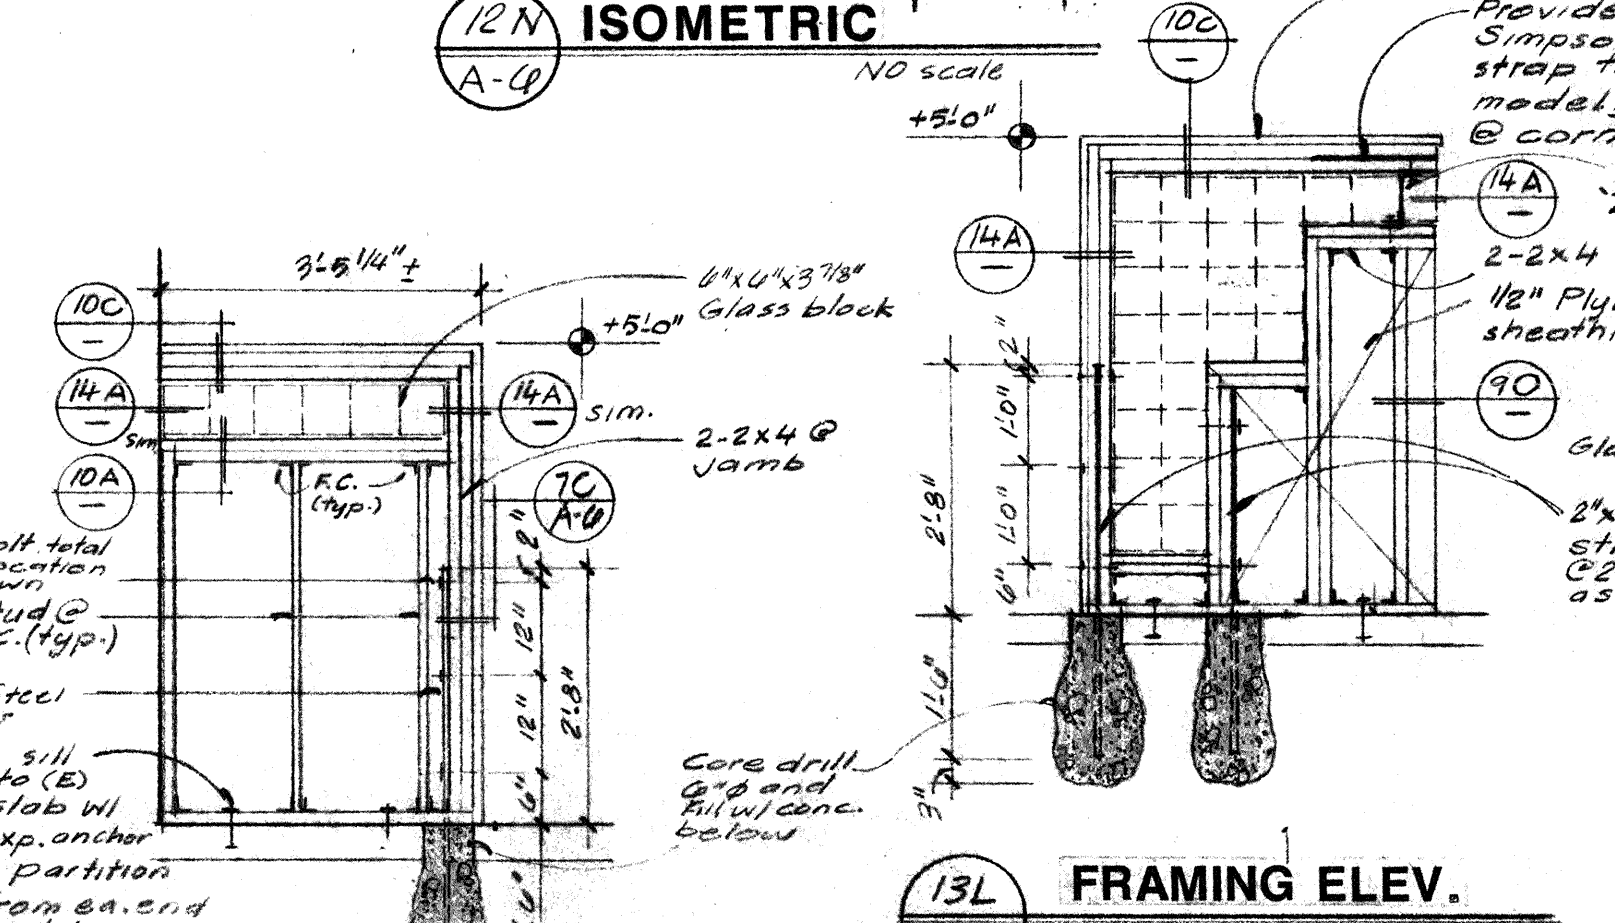


of partition


11k **FRAMING ELEV.**

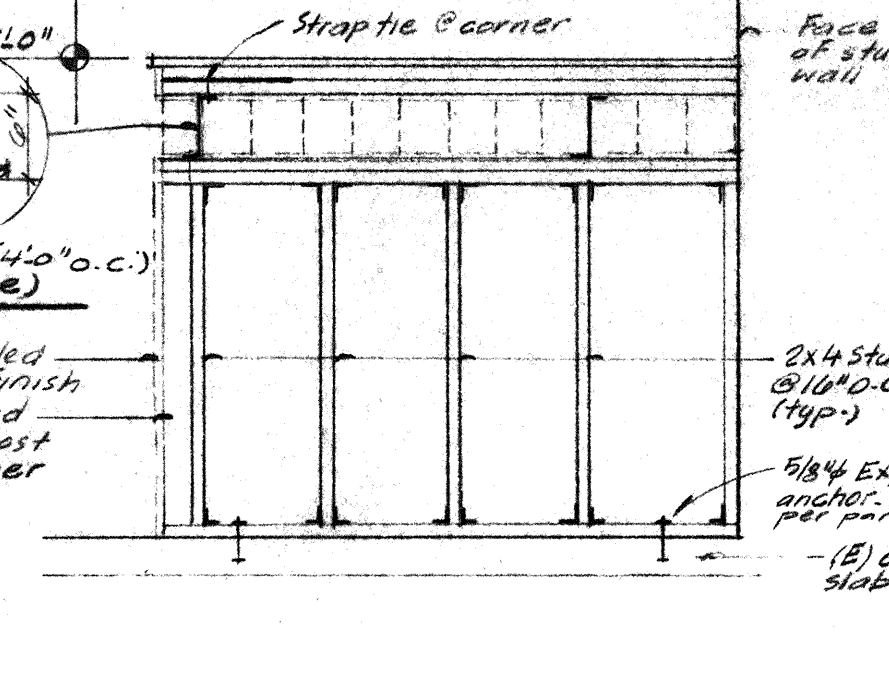

11H FRAMING ELEV

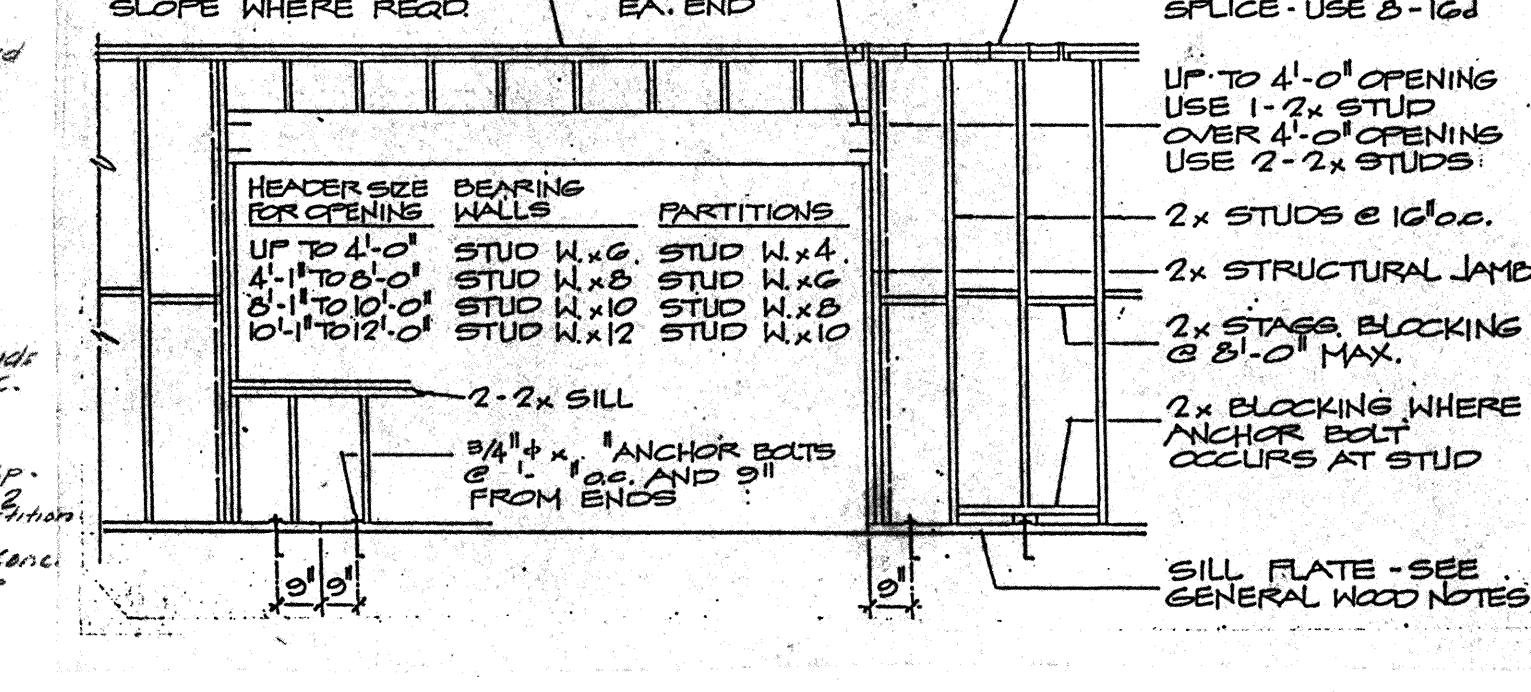

13H TYPICAL HEADER SCHEDULE

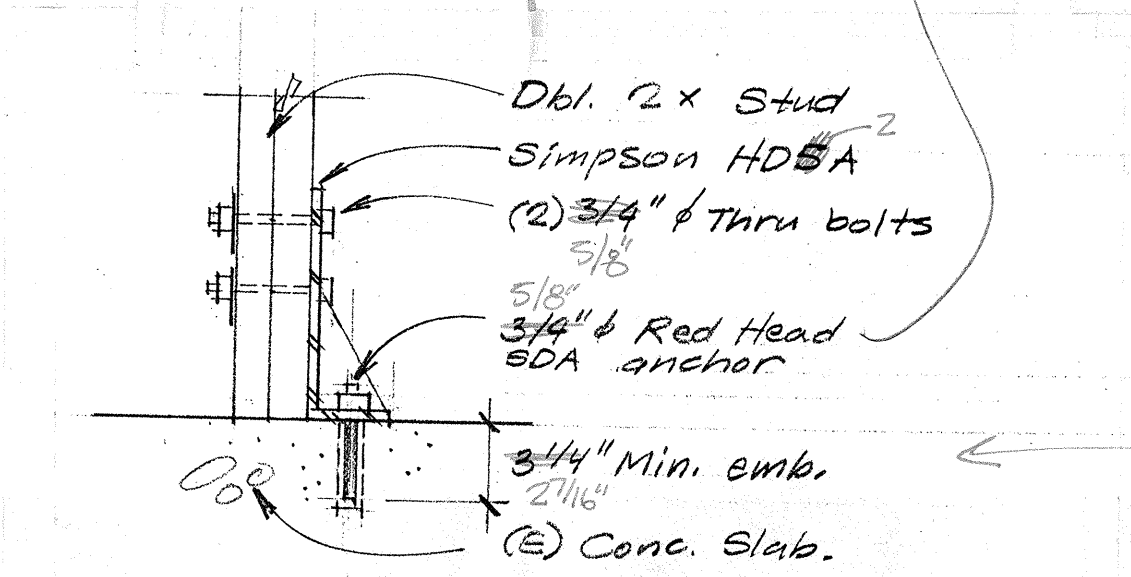


TYPICAL HOLD DOWN


Real head wedge
anchor

9/9/91
(5460212 HILT RED)
USED 5/8" & HILT
EPOXY SET ANCHOR


Note: Test conc. exp.
anchors to 2728# tension,
50% of the anchors
shall be tested

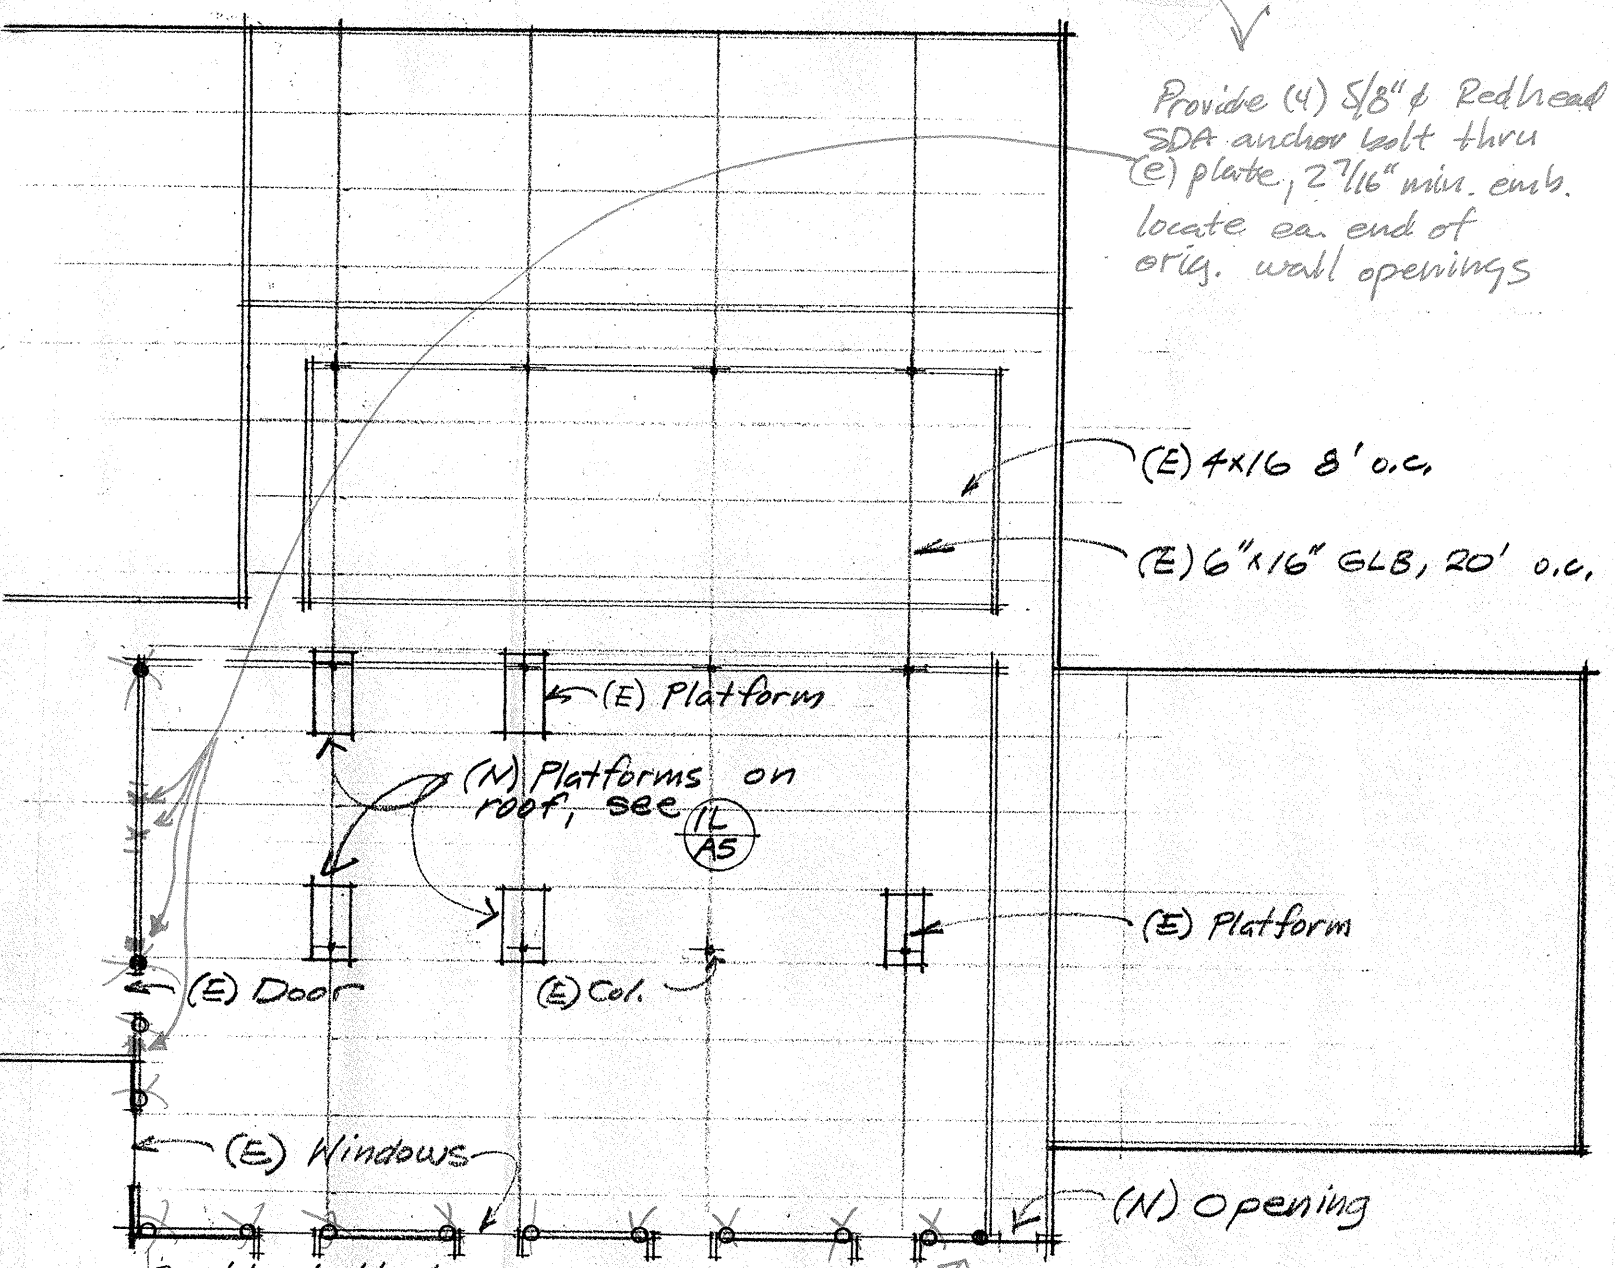


1A **STRUCTURAL MODIFICATIONS PLAN**

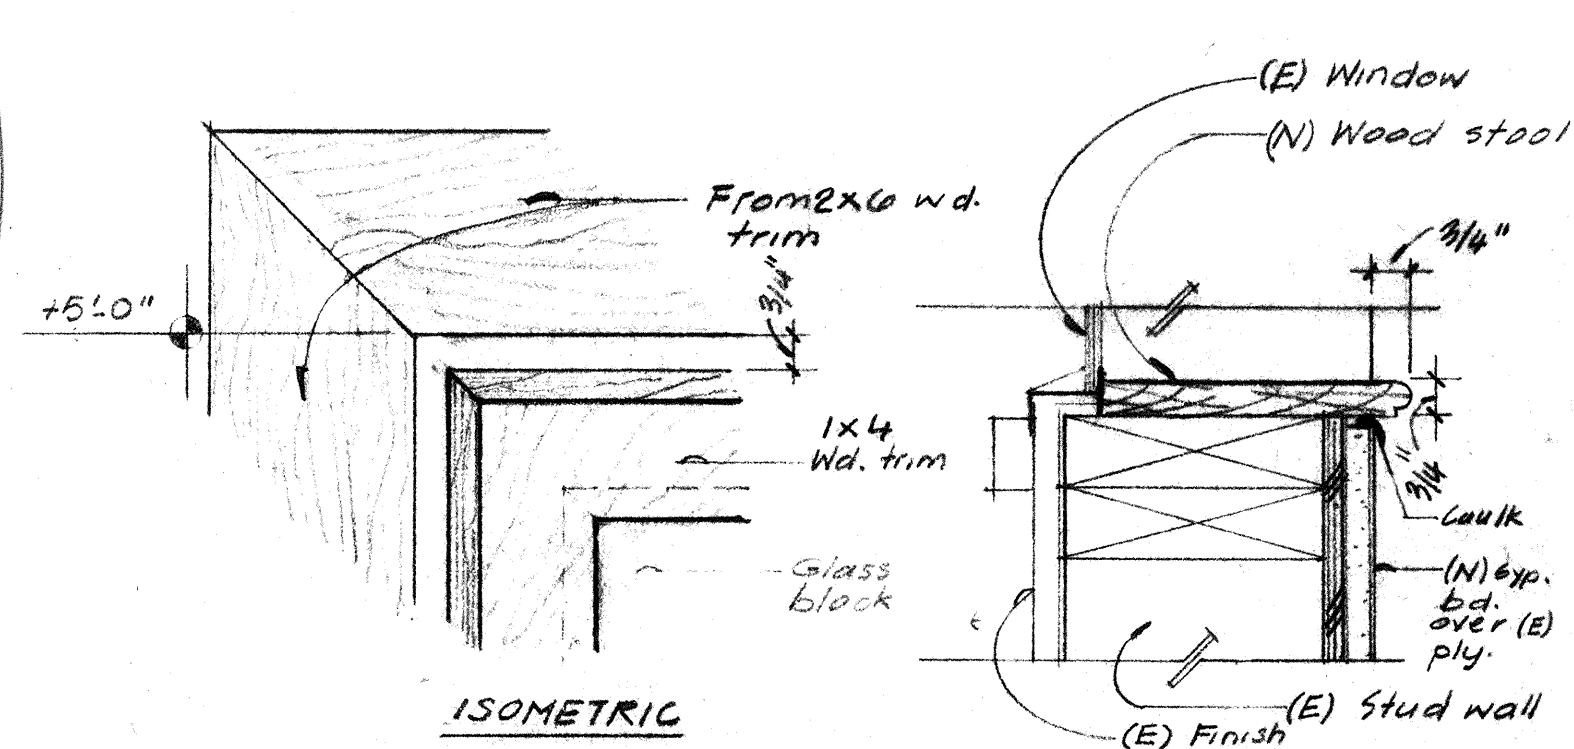


7E CORNER DETAIL 9E SILL DETAIL

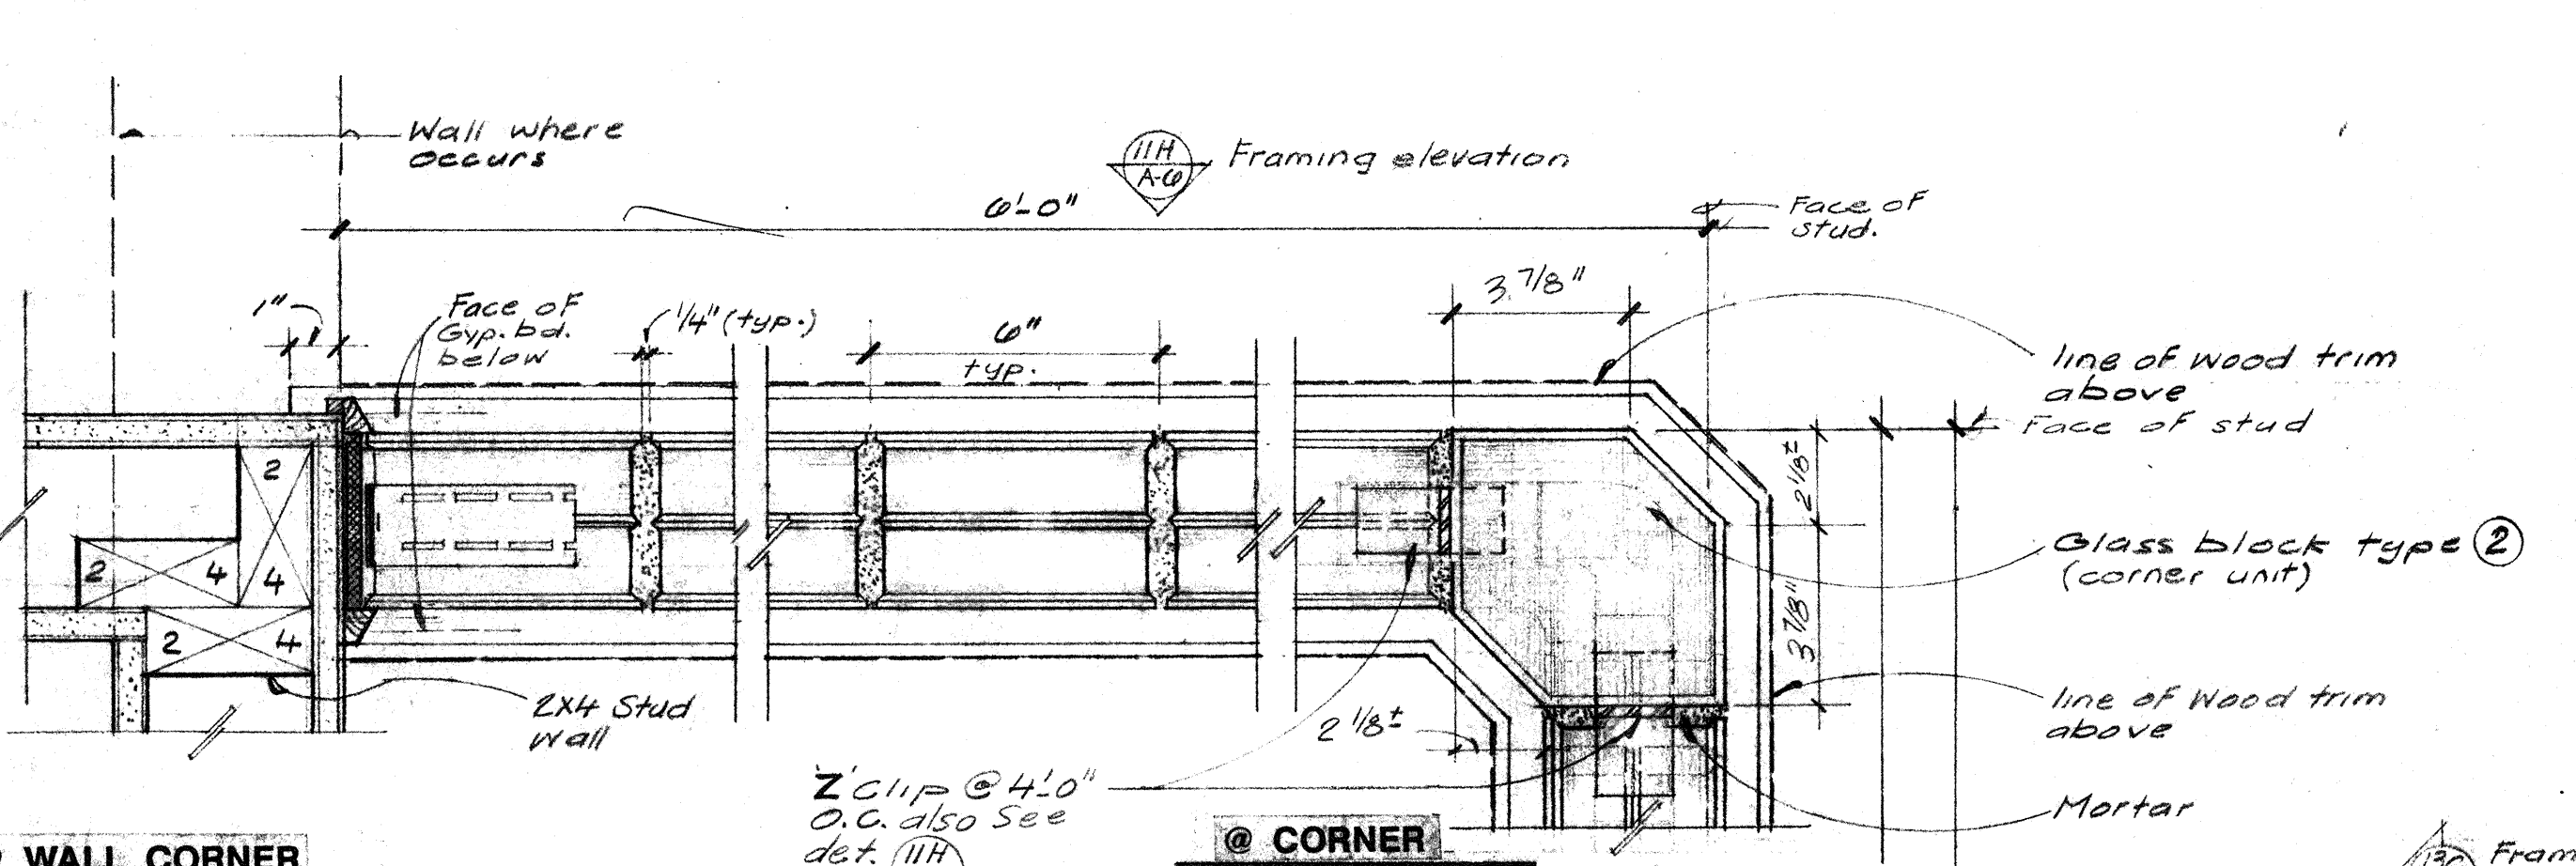


10D @ WALL CORNER
A-66

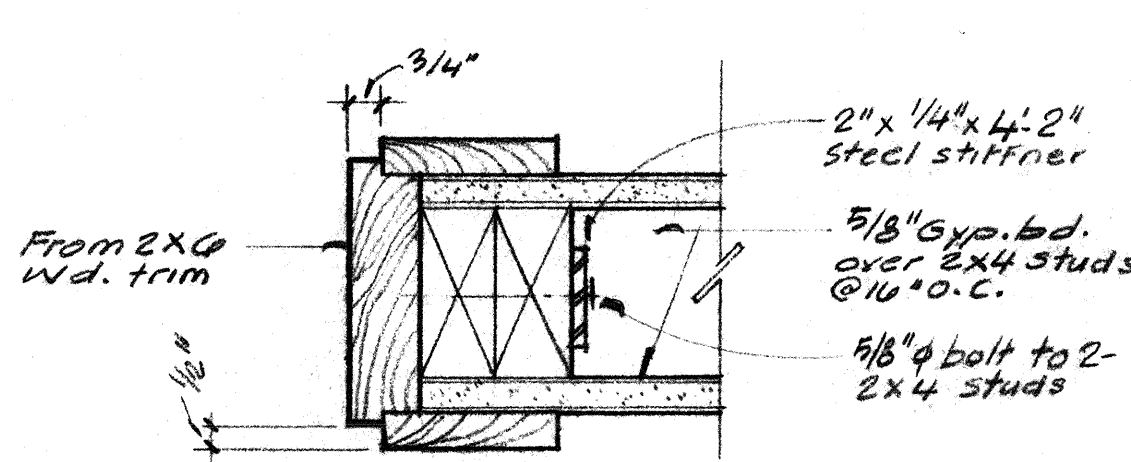


70 **END OF PARTITION** (Cap simi)

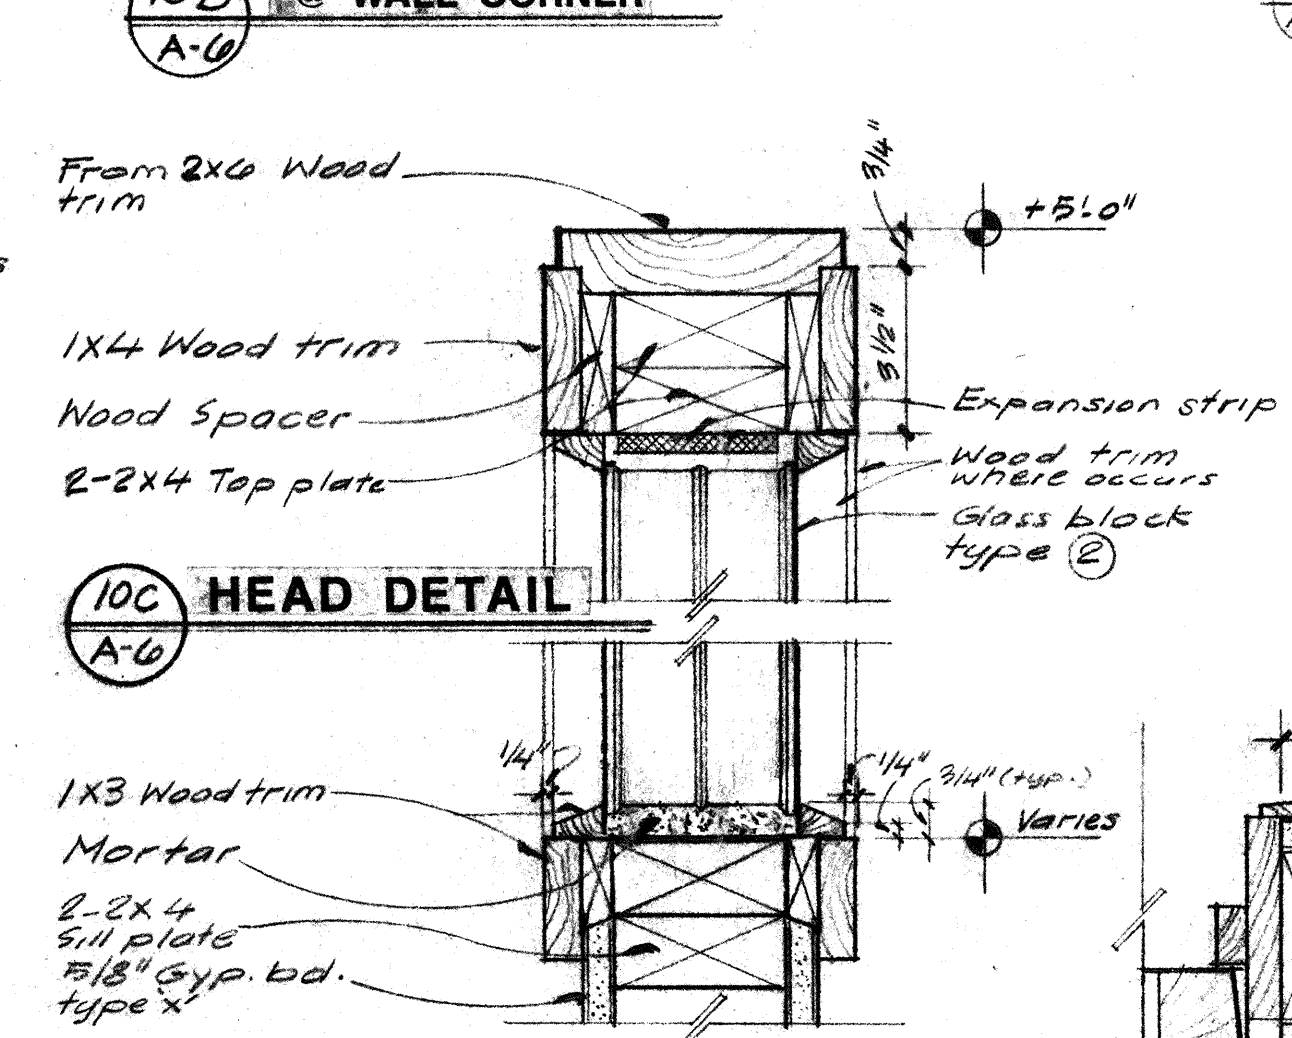

10C HEAD DETAIL

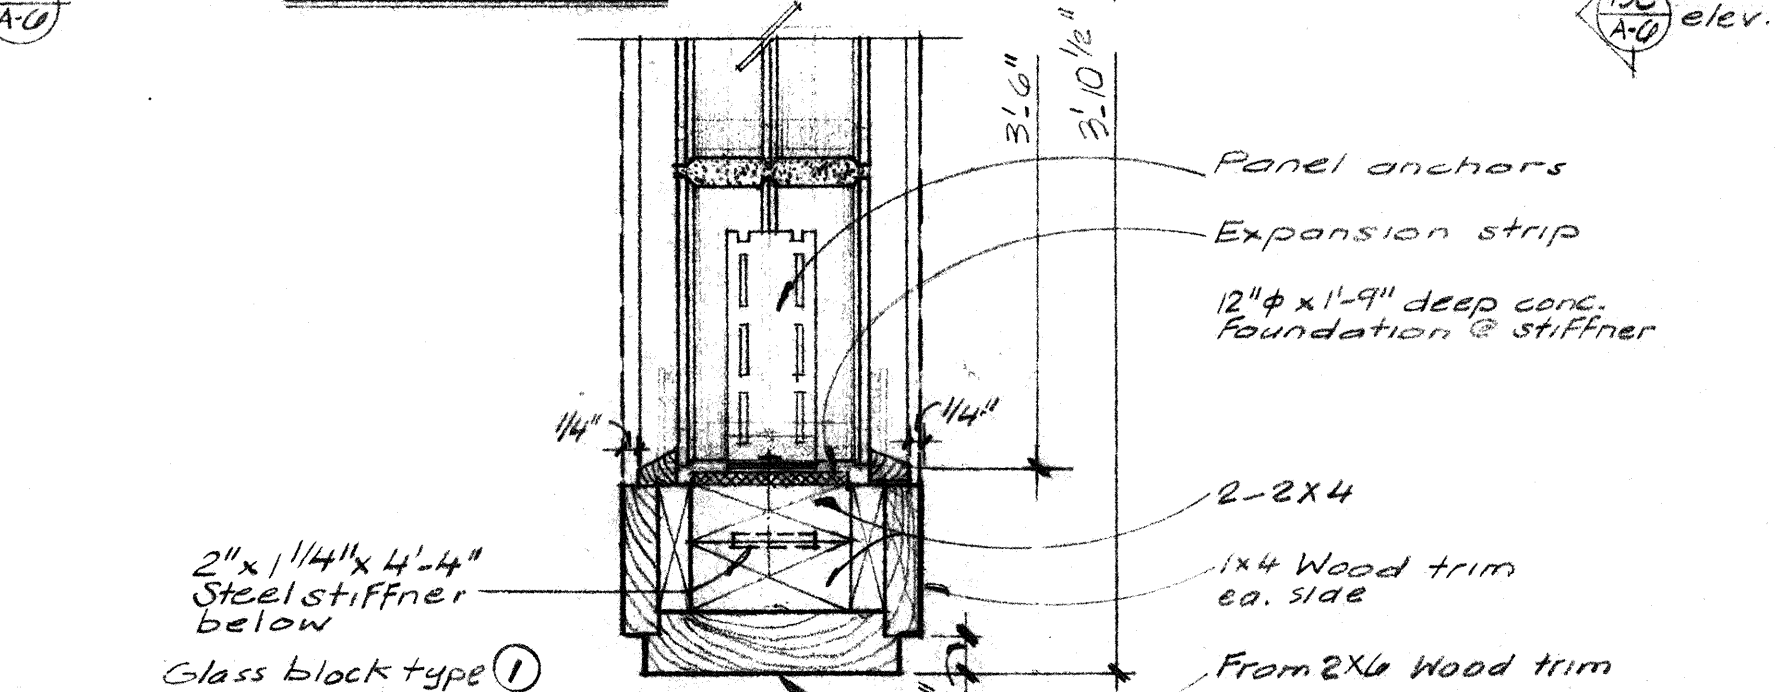


2" x 1 1/4" x 4
Steel stiff
below

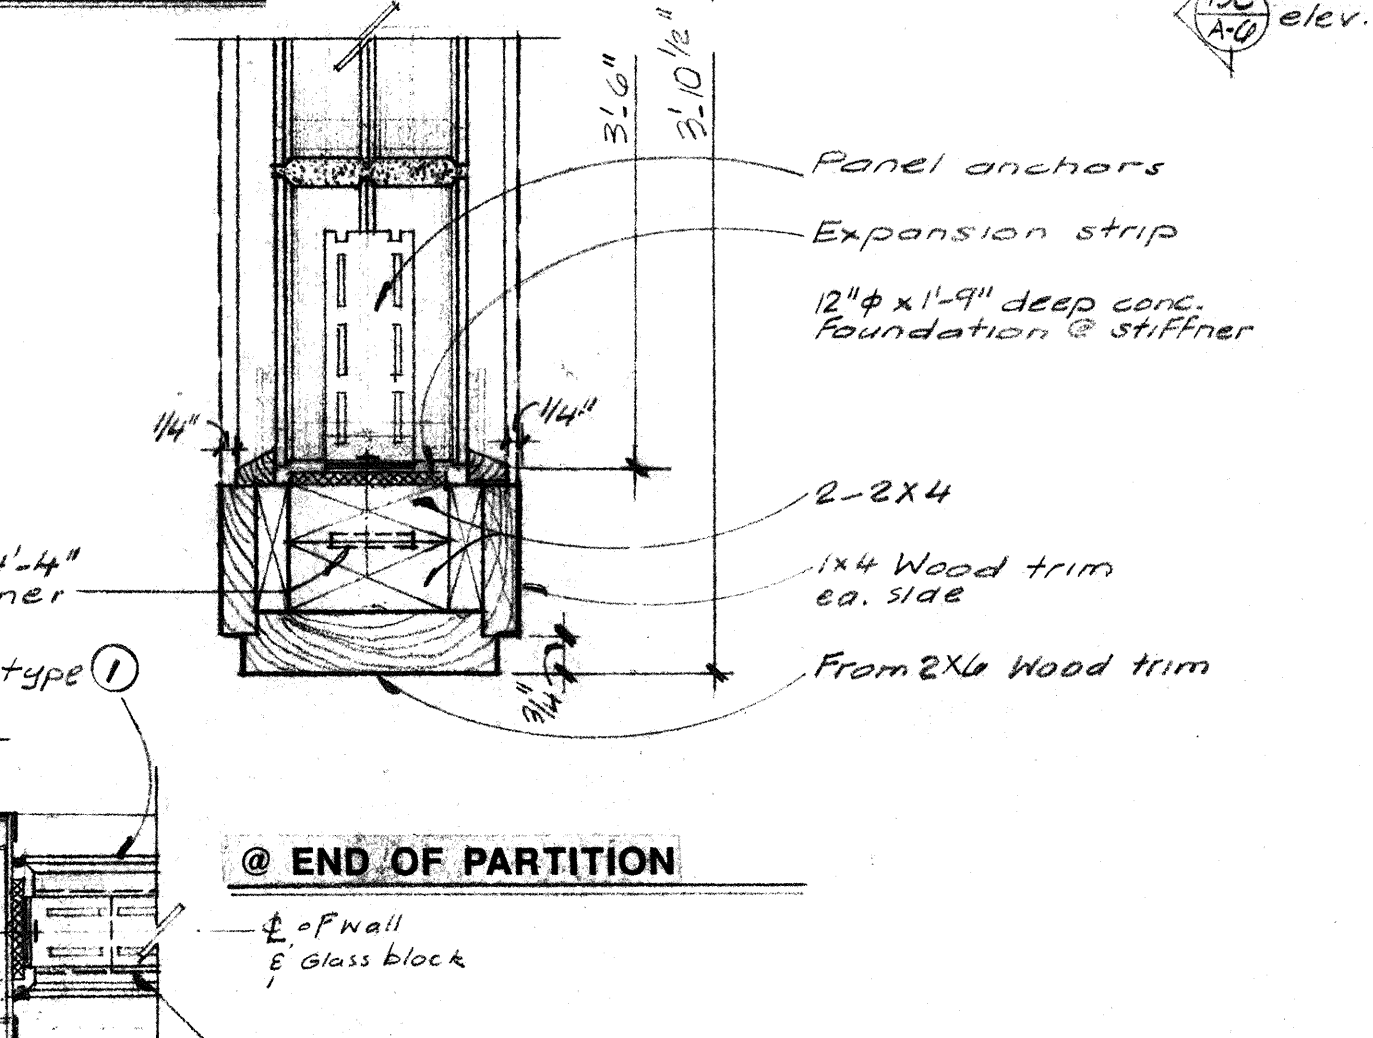

1 1/4" diameter

ner

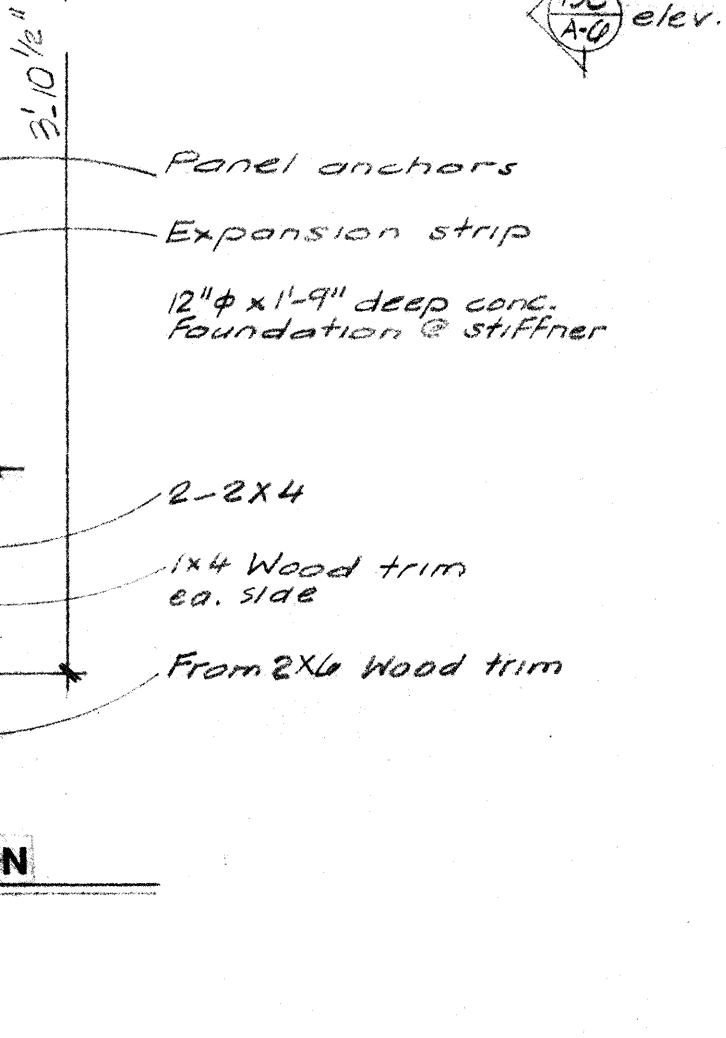

1x4 Wood trim
ea. side

JUL 02 1960

Any changes to these plans must be approved by the Development Department. The issuance of a permit does not grant to any person the right to violate City State Laws.

APPROVED _____
by _____

No.	Revisions/Submissions	Date:
-----	-----------------------	-------

Edwin S. Darden Associates, Inc.
 ARCHITECTURE AND PLANNING
 Edwin S. Darden FAIA / Edwin S. Darden Jr. AIA
 Martin E. Dietz AIA CCS / Edwin C. Goodwin AIA

1177 W. Shaw Avenue / Fresno, California 93711 / 209 222-7463
 987 Osos Street / San Luis Obispo, California 93401 / 805 543-3965

Consultant

**VALLEY CHILDREN'S HOSPITAL PROFESSIONAL CENTER
FOUNDATION OFFICE PROJECT**

1990 EAST GETTYSBURG FRESNO CA. Project

DETAILS

	Drawing
--	---------

DESIGNED BY: 9116	PROJECT NO.: 9116
--------------------------	--------------------------

	Drawn By:	Scale:

NO. C14168
193


Checked By:

STANDARD FORM NO. 64 (Rev. 5-22-64) A.6

STATE OF CALIFORNIA

Date: _____		Sheet: _____ of: _____	
-------------	--	------------------------	--

	18	19	20
--	----	----	----

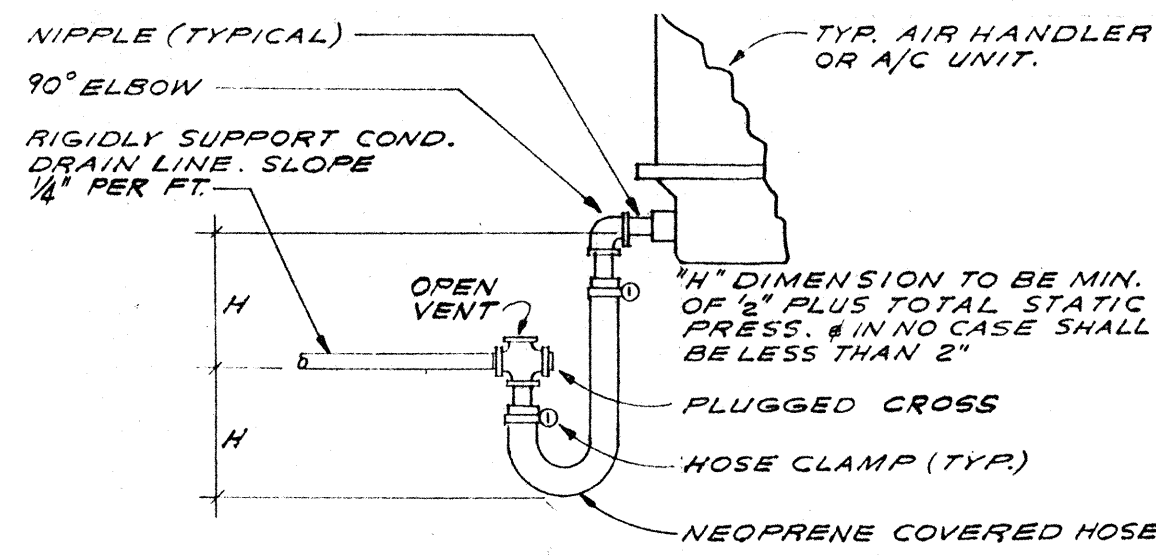

TYP. CONDENSATE DRAIN CONNECTION
PROVIDE PLUGGED TEE IN EACH CHANGE OF DIRECTION

DETAIL
NO SCALE

PLUMBING FIXTURE SCHEDULE						
MARK	ITEM	CONNECTIONS				DESCRIPTION
		CW	HW	SOIL	VENT	
(S) 1	SINK	1/2"	1/2"	2"	1-1/2"	JUST "STYLIST" MODEL #SL-1921-A-GR, SINGLE BOWL, 19" X 21", 18 GA. S.S., SELF-RIMMING, SINGLE HOLE, (1) AMERICAN STANDARD #4331.013 STRAINER, CHICAGO #50-229-388, SINGLE HOLE INLET, #6N2A SPOUT, #369 HANDLES, AND #29 "LAMAFLO" OUTLET.
(IM) 1	ICE MAKER S.O.V. BOX	1/2"	-	-	-	CP INDUSTRIES "WATERTITE ICE MAKER BOX" MODEL #9000, RECESSED WATER SUPPLY WITH S.O.V. TO ICE MAKER, 1/4" O.D. OUTLET.


PLUMBING EQUIPMENT SCHEDULE						
MARK	ITEM	ELECTRICAL				DESCRIPTION
		HP	VOLT	Ø		
(P) 1	WATER HEATER	3 (KW)	120	1		I.T.S. INSTANTANEOUS ELECTRIC WATER HEATER MODEL MDT 3000/120, 40° TEMP RISE AT .5 GPM DELIVER, U.L. LISTED. MOUNT BELOW SINK.

NOTES:

- CALCULATIONS FOR THE PLUMBING DESIGN OF THIS SYSTEM ARE PREDICATED ON THE UNIFORM PLUMBING CODE AS FOLLOWS:
 - WATER SUPPLY DESIGN IS BASED ON APPENDIX "A" - TABLE A-2 AND CHARTS A-2, A-3, A-5 AND A-6. CHART A-6 IS BASED ON 5 P.S.I. FRICTION LOSS PER 100 FEET LENGTH OF PIPE. UTILITY MAIN DESIGN PRESSURE 35 P.S.I.G.
 - DRAINAGE SYSTEM DESIGN IS BASED ON TABLES 4-1 AND 4-3.
 - GAS DISTRIBUTION SYSTEM DESIGN IS BASED ON TABLE 12-2 WITH A TOTAL LENGTH OF 400 FEET.
- CONTRACT DRAWINGS FOR THE EXISTING FACILITY ARE ON FILE AT THE OFFICE OF THE ARCHITECT, EDWIN S. DARDEN & ASSOCIATES, INC., FOR THE PURPOSE OF MANDATORY REFERENCE BEFORE SUBMITTING BID. CONTRACTOR SHALL VISIT THE JOBSITE AND INSPECT THE EXISTING CONDITIONS, AND BASED ON THE REVIEWED SITE CONDITIONS AND REFERENCED DRAWINGS MAKE, THE MODIFICATIONS AND EXTENSIONS TO THE EXISTING SYSTEMS AS GENERALLY DELINEATED. NO CLAIM FOR EXTRA SUMS WILL BE ALLOWED DUE TO THE CONTRACTOR'S FAILURE TO PROPERLY EXAMINE THE SITE AND REFERENCED DRAWINGS.
- SPECIFICATION SECTION 15400 SHALL COORDINATE WITH ALL OTHER TRADES (HVAC, STRUCTURAL, ETC.) AT THE START OF THE PROJECT AND REROUTE AS REQUIRED, ANY AND ALL EXISTING PIPING IN CONFLICT WITH THE INSTALLATION OF NEW SYSTEMS OR PORTION THEREOF IN ANY AREA UNDER THIS CONTRACT.
- SPECIFICALLY OMITTED FROM THE SERVICES OF JOHN FRANK MITCHELL, INC., ARE ALL DESIGN AND CONSTRUCTION REVIEW SERVICES RELATING TO THE CONTRACTOR'S SAFETY PRECAUTIONS OR TO MEANS, METHODS, TECHNIQUES, SEQUENCES, OR PROCEDURES REQUIRED FOR THE CONTRACTOR TO PERFORM HIS WORK, BUT NOT RELATING TO THE FINAL OR COMPLETED STRUCTURE. OMITTED SERVICES INCLUDE BUT ARE NOT LIMITED TO SHORING, SCAFFOLDING, UNDERPINNING, TEMPORARY RETAINMENT OF EXCAVATIONS, ANY ERECTION METHODS AND BRACING.

GAS LOAD ANALYSIS

EXISTING SPACE HEATING.....	2320 CFH
EXISTING WATER HEATING.....	31 CFH
NEW SPACE HEATING.....	195 CFH
TOTAL GAS LOAD.....	2546 CFH
DEVELOPED LENGTH.....	400 FT.

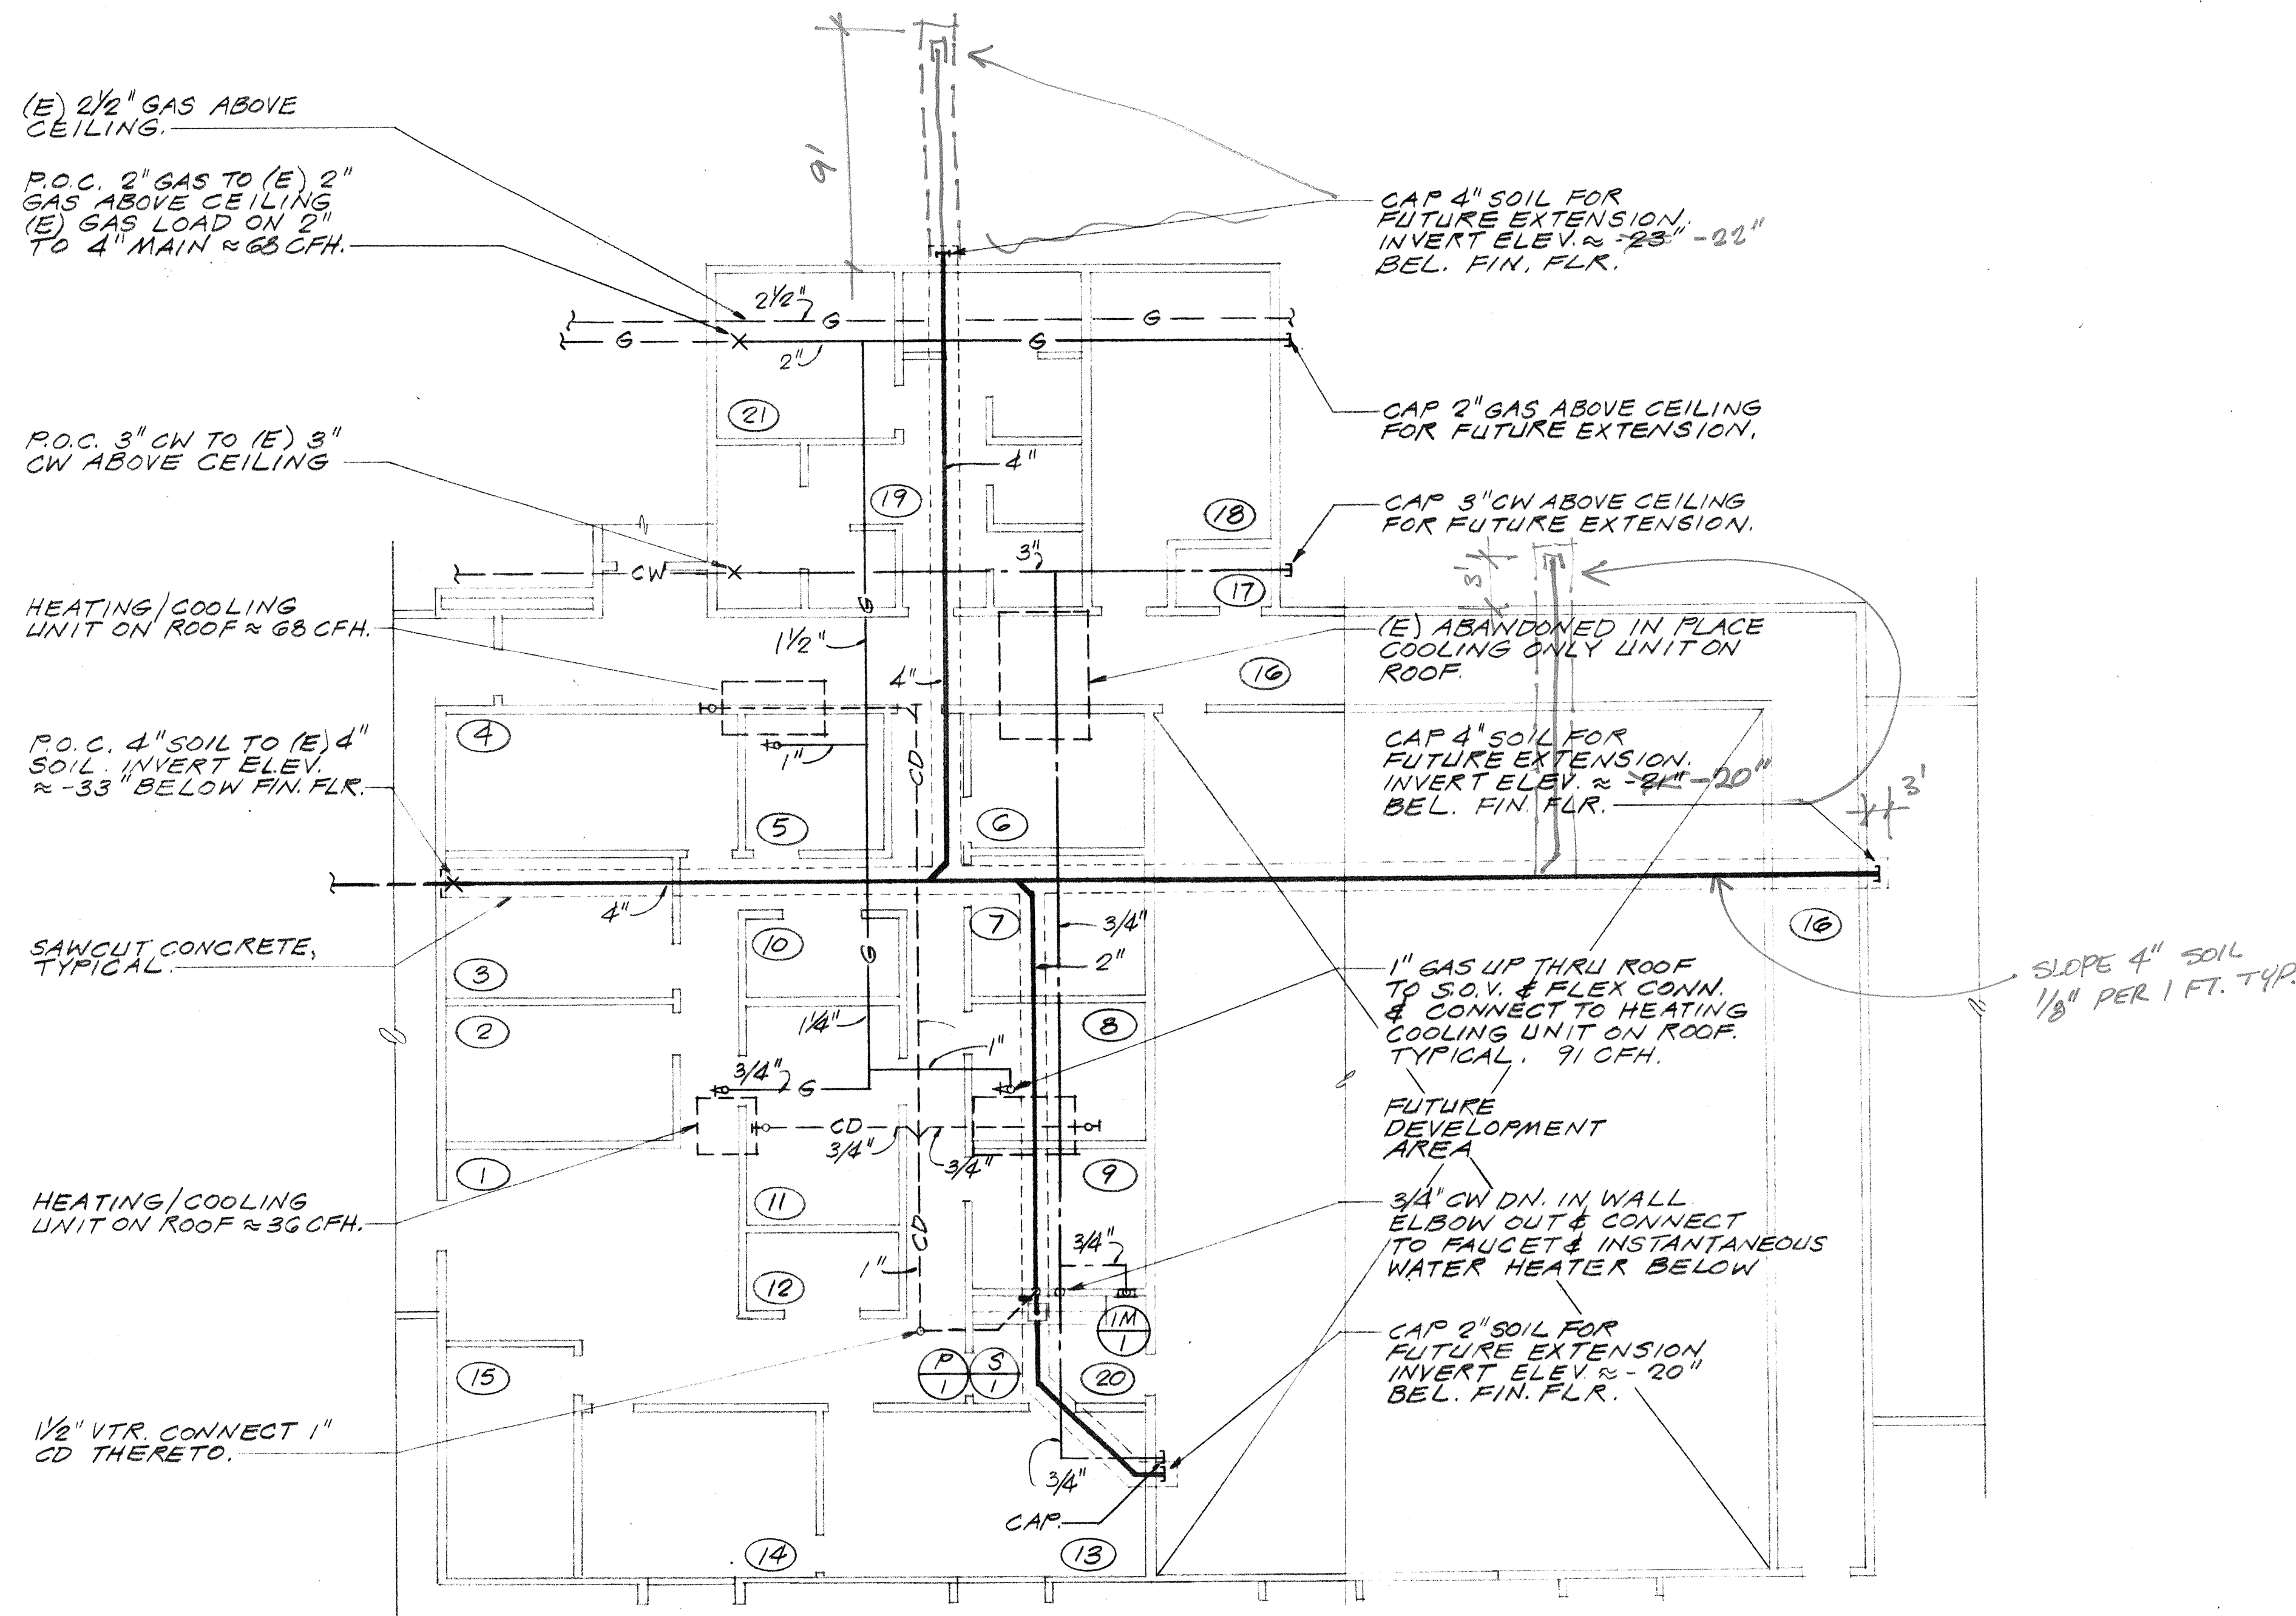

PLUMBING PLAN

SCALE: 1/8"=1'-0"

NOTES:

- FIRE SPRINKLERS ARE REQUIRED FOR THE AREA SHOWN ABOVE AND SHALL BE PROVIDED AS AN EXTENSION TO THE EXISTING SYSTEM. REFER TO SPECIFICATION SECTION 15500 FOR SCOPE AND REQUIREMENTS.
- COORDINATE PIPE ROUTING AND ELEVATIONS WITH PLUMBING, AIR CONDITIONING TRADES. ANY FIRE SPRINKLER PIPING INTERFERING WITH PLUMBING OR AIR CONDITIONING PIPING AND DUCTS SHALL BE RELOCATED AT CONTRACTOR'S EXPENSE. THIS INCLUDES MAINS, CROSS-MAINS, AND DROPS TO HEADS.

Materials Keying Legend

PLUMBING LEGEND

SYMBOL	ITEM	ASSR.
---	SOIL, WASTE OR DRAIN	S.W.D.
---	VENT	V
---	COLD WATER	CW
---	HOT WATER	HW
---	HOT WATER RETURN	HW-R
---	FIRE SPRINKLER	FS
---	CONDENSATE DRAIN	CD
---	GAS FUEL (LOW PRESS)	G
---	EXISTING PIPING	---
---	POINT OF CONNECTION	POC
---	CLEANOUT TO GRADE	CGTG
---	CLEANOUT TO FLOOR	CGTF
---	CLEANOUT TO WALL	CGTW
---	SHUT-OFF VALVE	SOV
---	GATE VALVE	GV
---	CHECK VALVE	CV
---	UNION	---
---	TEE UP	---
---	TEE DOWN	---
---	ELBOW UP	---
---	ELBOW DOWN	---

CITY OF FRESNO DEVELOPMENT DEPARTMENT

JUL 02 1991

Any changes to these plans must be approved by the Development Department. The absence of a permit does not grant to any person the right to violate City or State laws.


No. Revisions/Submissions Date:

Edwin S. Darden Associates, Inc.
ARCHITECTURE AND PLANNING
Edwin S. Darden FAIA / Edwin S. Darden Jr. AIA
Martin E. Dietz AIA CCS / Edwin C. Goodwin AIA
1177 W. Shaw Avenue / Fresno, California 93711 / 209 222-7483
987 Ocho Street / San Luis Obispo, California 93401 / 805 543-3965

JOHN FRANK MITCHELL, INC.
MECHANICAL ENGINEERS
PLUMBING, HEATING, AND AIR CONDITIONING
9/23/91 Consultant

VALLEY CHILDREN HOSPITAL PROFESSIONAL CENTER
FOUNDATION OFFICE PROJECT
1990 EAST GETTYSBURG FRESNO CA Project

Drawing
Designed By: RMM Project No.: 9116
Drawn By: RMM Scale: AS NOTED
Checked By: JFM
Reviewed By: JFM
Date: 5-9-91 Sheet: 1 of 1

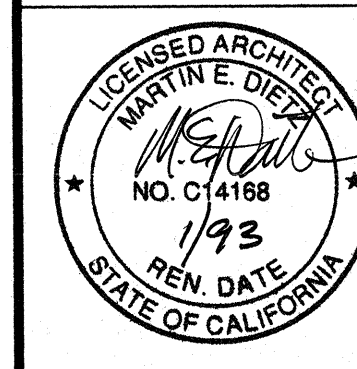

MECHANICAL EQUIPMENT SCHEDULE		
MK.	DUTY	DESCRIPTION
①	HEATING-COOLING UNIT	YORK MODEL DCG060, 1950 CFM @ .4" ESP. 1 HP MOTOR DIRECT DRIVE. 51,000 BTUH TOTAL COOLING, 49,500 BTUH SENSIBLE COOLING CAPACITY @ 80/63 E.A.T. AND 105 DEGREES AMBIENT. 100,000 BTUH HEATING INPUT, 92,000 BTUH OUTPUT NATURAL GAS COMPLETE WITH CRANKCASE HEATER, SPRING ISOLATORS WITH SEISMIC RESTRAINTS, THERMOSTAT WITH LOCKING COVER, INTEGRATED ECONOMIZER OPTION WITH FACTORY BAROMETRIC RELIEF RAINHOOD MOUNTED IN RETURN AIR DUCTWORK, AND (2) 14" X 20" X 2" DEEP FARR 30/30 FILTERS LOCATED IN UNIT FILTER RACK. 8.6 MINIMUM EER. HORIZONTAL DISCHARGE. ELECTRICAL: 19.7 FLA 480 VOLT 3 PHASE WT: 750#
②	HEATING-COOLING UNIT	YORK MODEL DCG048, 1600 CFM @ .4" ESP. 3/4 HP MOTOR DIRECT DRIVE. 43,000 BTUH TOTAL COOLING, 41,500 BTUH SENSIBLE COOLING CAPACITY @ 80/63 E.A.T. AND 105 DEGREES AMBIENT. 75,000 BTUH HEATING INPUT, 62,000 BTUH OUTPUT NATURAL GAS COMPLETE WITH CRANKCASE HEATER, SPRING ISOLATORS WITH SEISMIC RESTRAINTS, THERMOSTAT WITH LOCKING COVER, INTEGRATED ECONOMIZER OPTION WITH FACTORY BAROMETRIC RELIEF RAINHOOD MOUNTED IN RETURN AIR DUCTWORK, AND (2) 14" X 20" X 2" DEEP FARR 30/30 FILTERS LOCATED IN UNIT FILTER RACK. 8.6 MINIMUM EER. HORIZONTAL DISCHARGE. ELECTRICAL: 11.9 FLA 480 VOLT 3 PHASE WT: 700#
③	HEATING-COOLING UNIT	YORK MODEL DYS024, 800 CFM @ .4" ESP. 1/3 HP MOTOR DIRECT DRIVE. 21,000 BTUH TOTAL COOLING, 20,000 BTUH SENSIBLE COOLING CAPACITY @ 80/63 E.A.T. AND 105 DEGREES AMBIENT. 40,000 BTUH HEATING INPUT, 30,000 BTUH OUTPUT NATURAL GAS. COMPLETE WITH CRANKCASE HEATER, LOW AMBIENT CONTROL TO 40 DEGREES, SPRING ISOLATORS WITH SEISMIC RESTRAINTS, THERMOSTAT WITH LOCKING COVER, AND (1) 23" 16" X 2" DEEP FARR 30/30 FILTER LOCATED ON UNIT RETURN DUCTWORK. 9.10 MINIMUM SEER. HORIZONTAL DISCHARGE. ELECTRICAL: 13.4 FLA 208 VOLT 1 PHASE WT: 400#
④	EXHAUST FAN	GREENHECK MODEL SP-25, 215 CFM @ .125" S.P., 2.5 SONES, 1050 RPM, DIRECT DRIVE. COMPLETE WITH BACKDRAFT DAMPER AND FULL SIZE DISCHARGE TO MODEL RDSP ROOF JACK. INTERLOCK WITH WALL SPEED CONTROLLER. ELECTRICAL: 70 WATTS 115 VOLT 1 PHASE WT: 20#
⑤	CEILING EXHAUST FAN	GREENHECK MODEL SP-15, 92 CFM @ .125" S.P., 1.4 SONES, 1050 RPM, DIRECT DRIVE. COMPLETE WITH BACKDRAFT DAMPER AND FULL SIZE DISCHARGE TO MODEL RDSP ROOF JACK. CONTINUOUS OPERATION. ELECTRICAL: 34 WATTS 115 VOLT 1 PHASE WT: 18#

DIFFUSER SIZING CHART (CFM VS. NECK/SHELL SIZE AND THROW PATTERN)				
NECK/SHELL SIZE OF DIFFUSER	DIFFUSER THROW PATTERN			
	4-WAY	3-WAY	2-WAY	1-WAY
612	100	100	75	50
1020	200	150	150	125
1024	275	200	175	150
1224	400	300	200	200
1424	425	375	350	250
1624	450	450	400	300

APPLICATION NOTES:

- ALL BARBER-COLMAN PERFORATED FACE CEILING SUPPLY DIFFUSERS SHOWN WITHOUT "NECK/SHELL" SHALL BE SIZED ACCORDING TO THE ABOVE CHART.
- THE CFM VALUES SHOWN ARE MAXIMUMS FOR THE "NECK/SHELL" SIZE SHOWN.
- IF THE ACTUAL DIFFUSER CFM IS BETWEEN TABULAR VALUES, USE THE LARGER "NECK/SHELL" SIZE.


GRILLE SCHEDULE		
MARK	DUTY	DESCRIPTION
A	CEILING SUPPLY	BARB-AIRE PBLV PERFORATED FACE LAY-IN DIFFUSER. BLACK INTERIOR, QSD, #7 FINISH. 24" X 24" NOMINAL FACE. SEE DIFFUSER SIZING CHART FOR NECK AND SHELL SIZES.
B	CEILING RETURN	BARB-AIRE TKOV ALUMINUM EGGRATE LAY-IN RETURN. BLACK INTERIOR, QSD, #7 FINISH. 12" X 24" OR 24" X 24" NOMINAL FACE AS SHOWN ON PLANS.
C	CEILING SUPPLY	BARB-AIRE 6MAV SURFACE MOUNT SUPPLY BLACK INTERIOR, #7 FINISH.

AIR CONDITIONING LEGEND



SYMBOL	ITEM	ABBR
---	DUCT	---
---	DUCT WITH ACOUSTICAL LINING	---
---	SUPPLY AIR DUCT DROP	---
---	RETURN AIR DUCT DROP	---
---	SUPPLY AIR DUCT RISE	---
---	RETURN AIR DUCT RISE	---
---	TURNING VANES	---
---	EXTRACTOR	---
---	VOLUME CONTROL DAMPER	V.C.D.
---	FIRE DAMPER WITH ACCESS PANEL	F.D.
---	THERMOSTAT, 4" X 4"	---
---	PRESSURE RELIEF VALVE	PRV.
---	DIRECTION OF FLOW	---
---	SUPPLY AIR	S.A.
---	RETURN AIR	R.A.
---	EXHAUST AIR	E.A.
---	OUTSIDE AIR	O.A.
---	EFC EXHAUST FAN CONTROL	---

HVAC NOTES:

- SPECIFICALLY OMITTED FROM THE SERVICES OF JOHN FRANK MITCHELL, INC., ARE ALL DESIGN AND CONSTRUCTION REVIEW SERVICES RELATING TO THE CONTRACTOR'S SAFETY PRECAUTIONS OR TO MEANS, METHODS, TECHNIQUES, SEQUENCES, OR PROCEDURES REQUIRED FOR THE CONTRACTOR TO PERFORM HIS WORK, BUT NOT RELATING TO THE FINAL OR EXISTING STRUCTURE. OMITTED SERVICES INCLUDE BUT ARE NOT LIMITED TO SHORING, SCAFFOLDING, UNDERPINNING, TEMPORARY RETAINMENT OF EXCAVATIONS, ANY ERECTION METHODS AND BRACING.

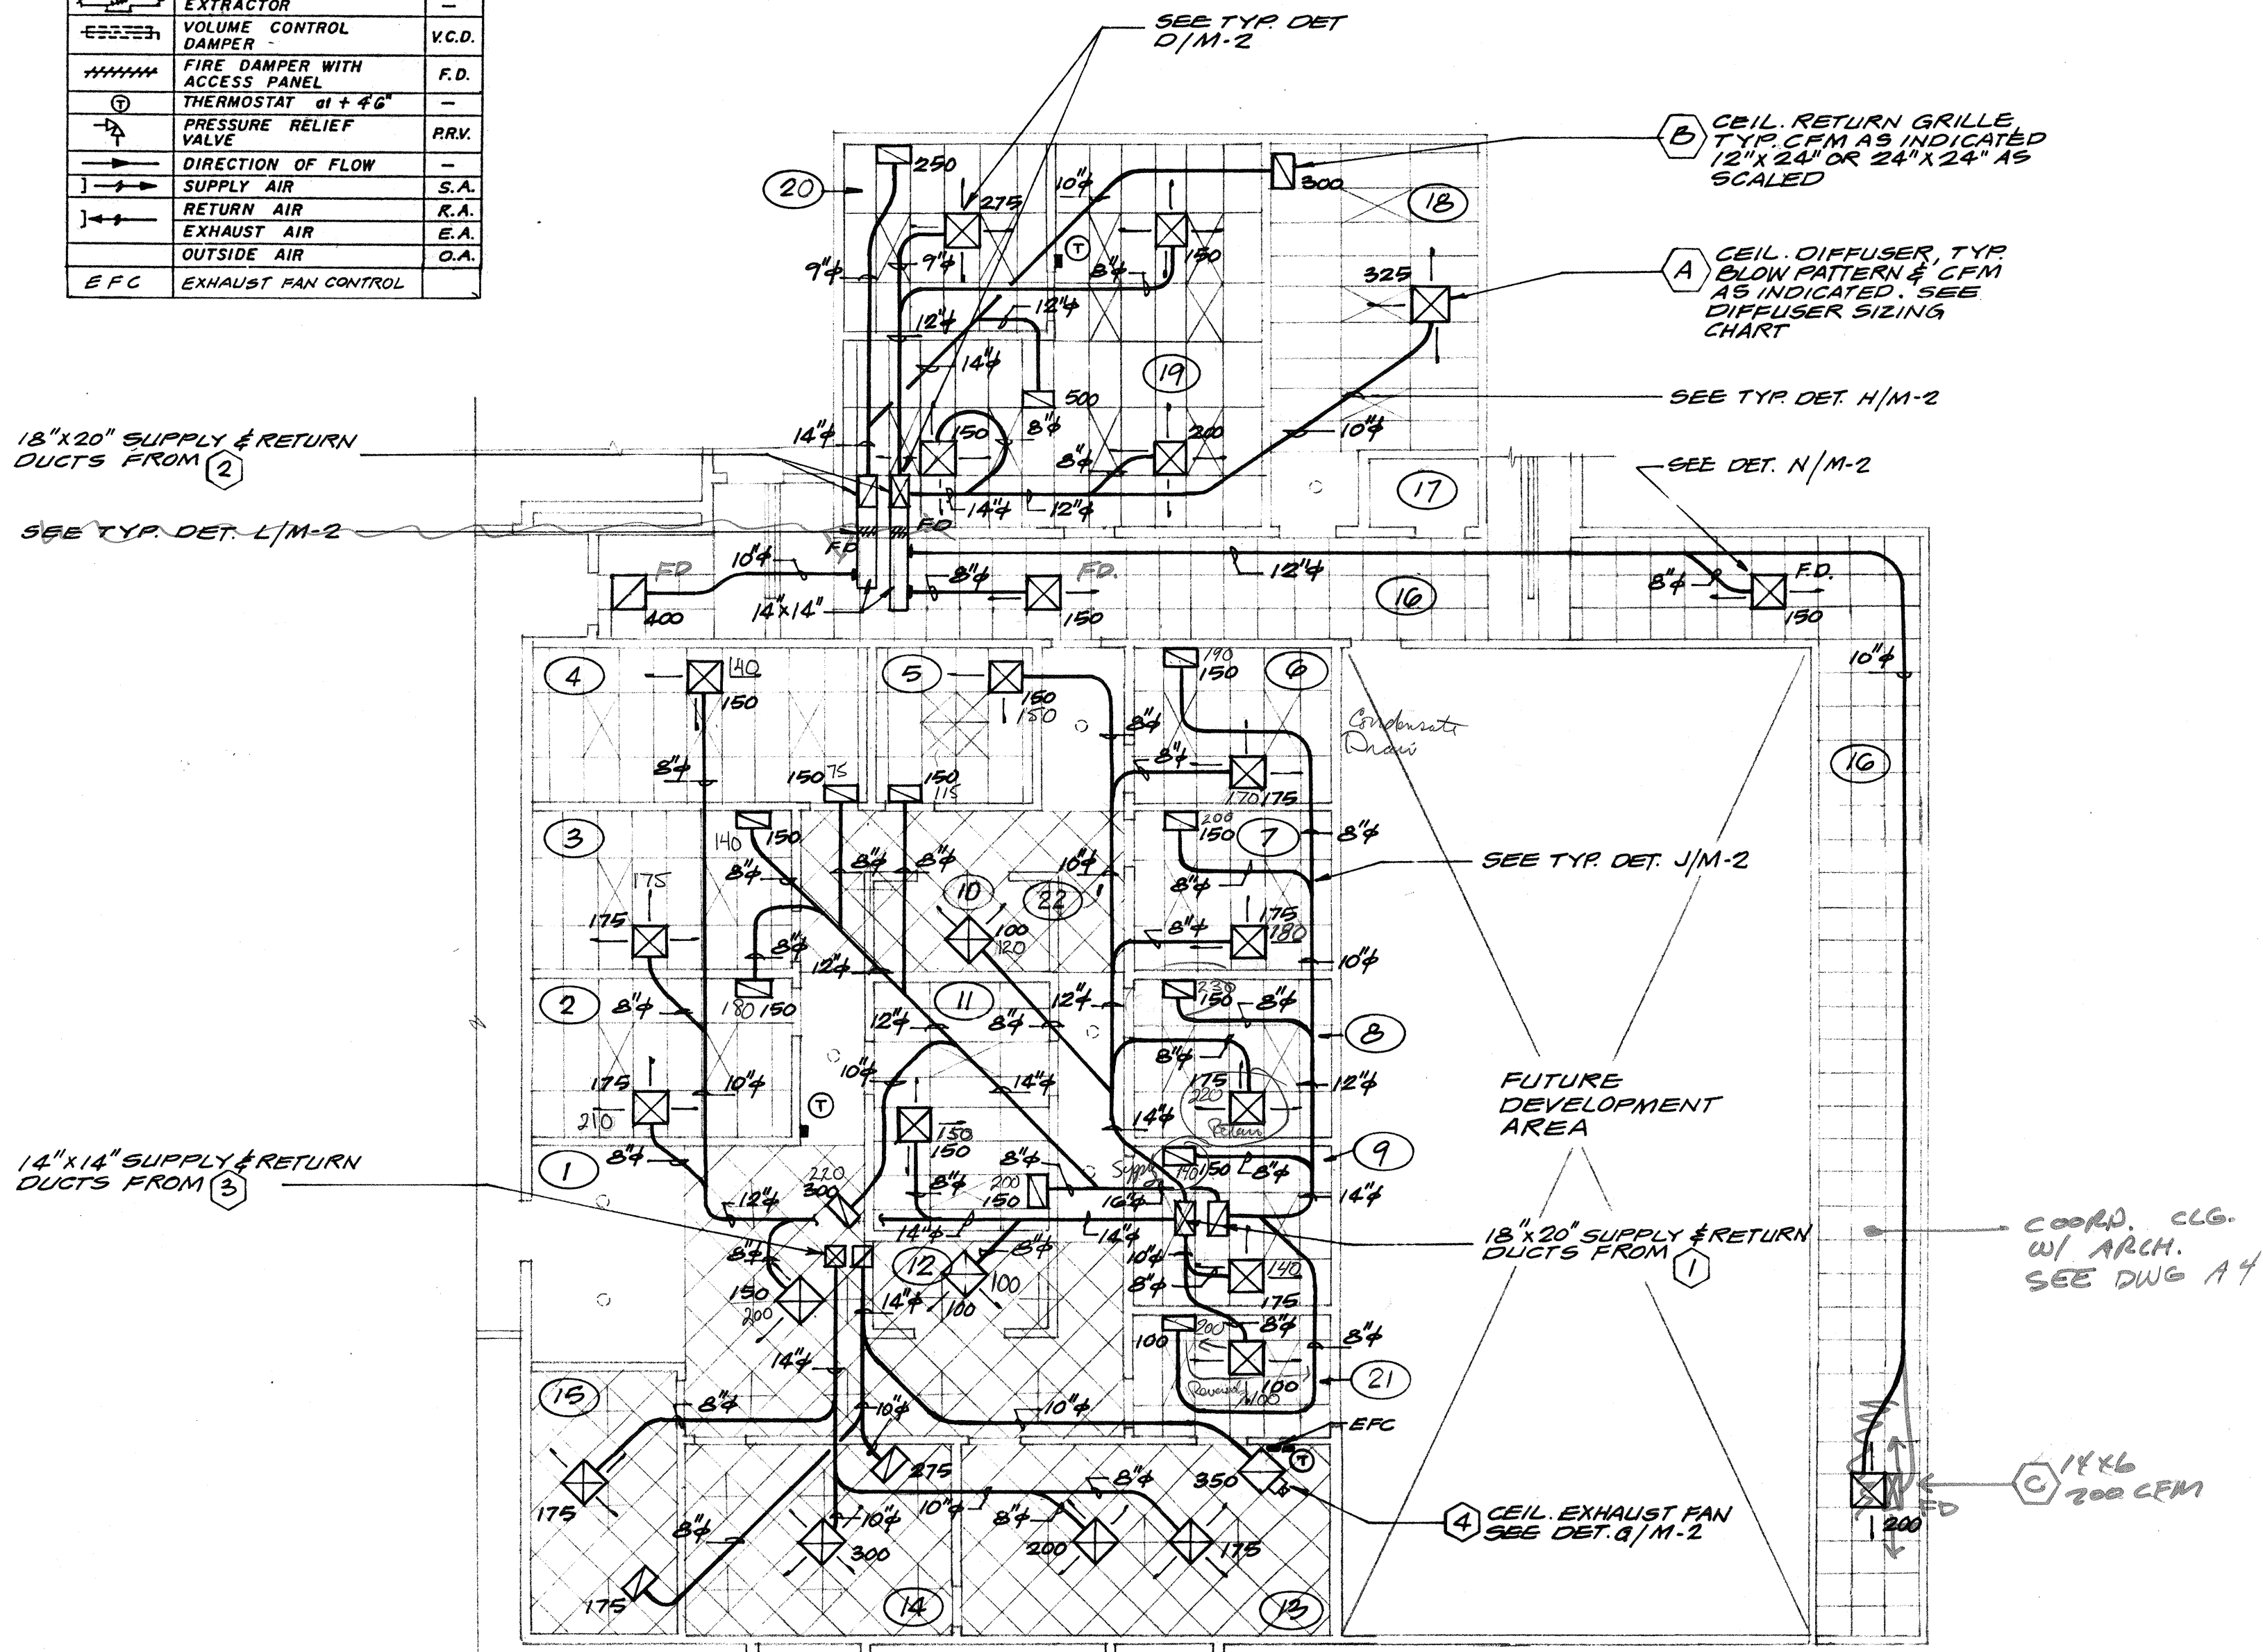

AIR CONDITIONING PLAN
SCALE 1/8"=1'-0"

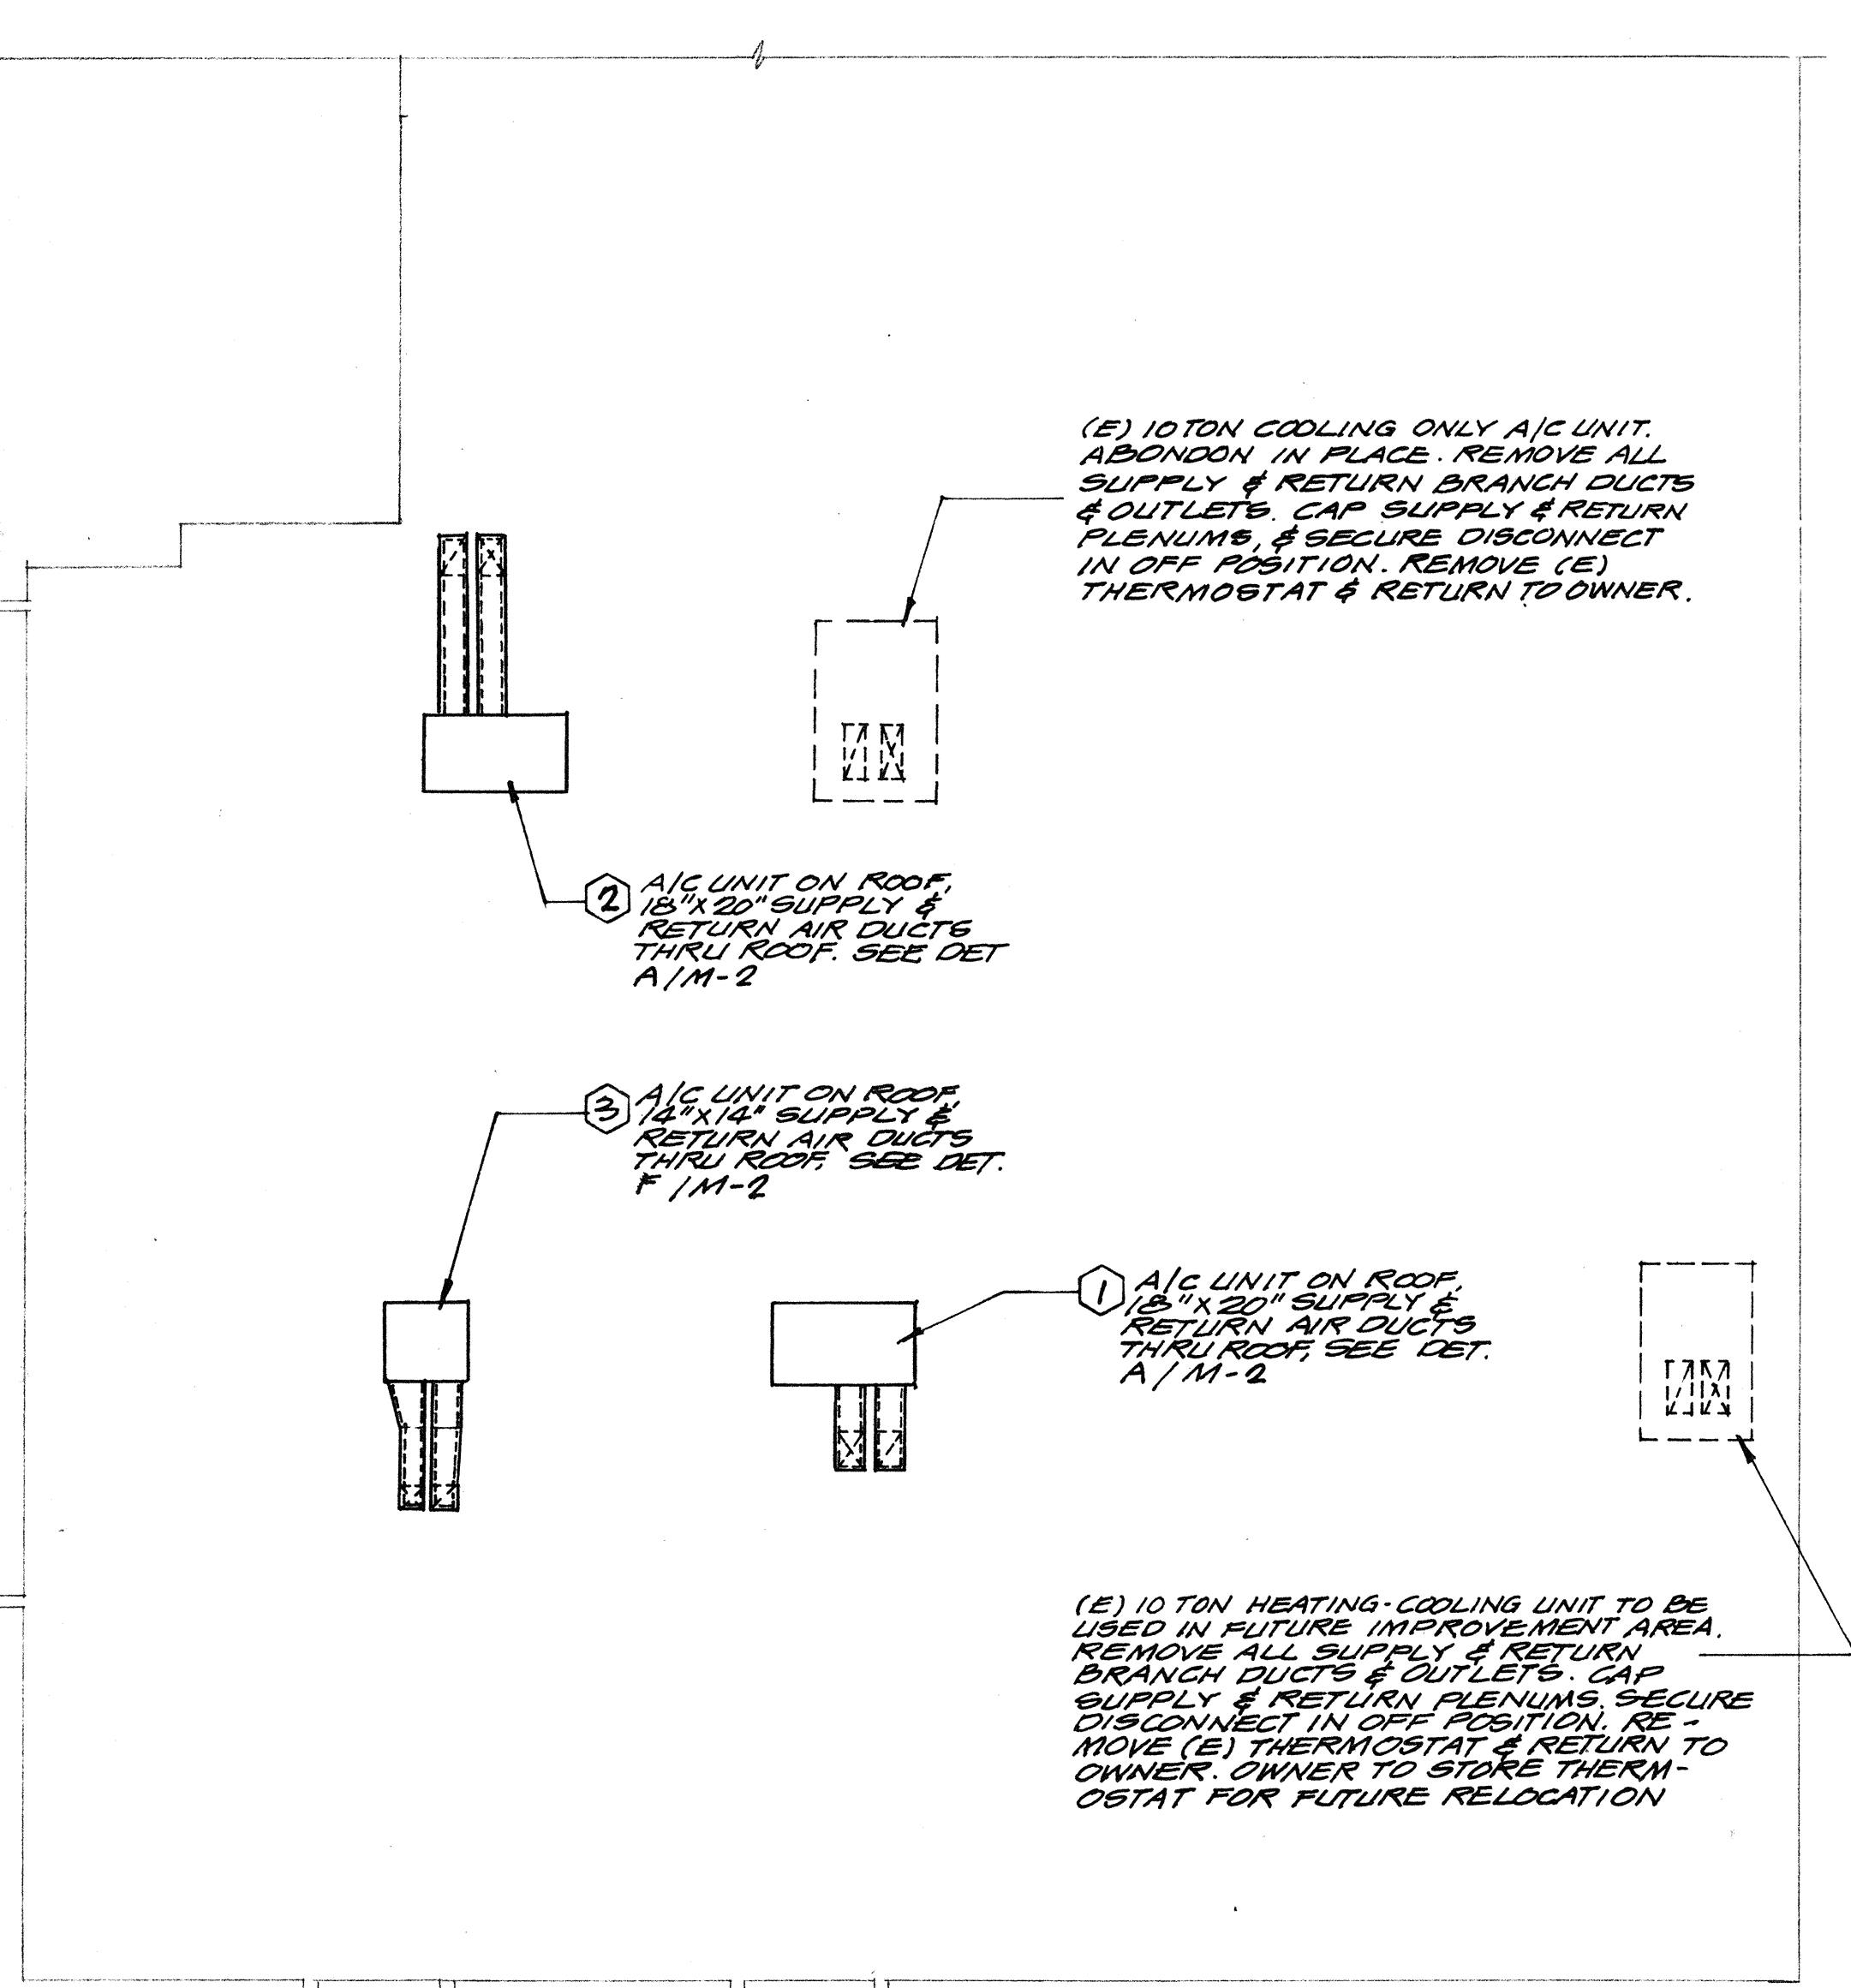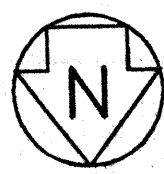

ROOF PLAN
SCALE 1/8"=1'-0"

NOTE: LABEL ALL EQUIPMENT AS TO THE AREA THAT IT SERVES



Materials Keying Legend



CITY OF FRESNO
DEVELOPMENT DEPARTMENT
JUL 02 2001
Any change to these plans must be approved by the Development Department. The absence of a permit does not mean that any person has the right to locate City or State property.

Edwin S. Darden Associates, Inc.
ARCHITECTURE AND PLANNING
Edwin S. Darden FAIA / Edwin S. Darden Jr. AIA
Martin E. Dietz AIA CCS / Edwin C. Goodwin AIA
1177 W. Shaw Avenue / Fresno, California 93711 / 209 222-7463
987 Oso Street / San Luis Obispo, California 93401 / 805 543-3965

JOHN FRANK MITCHELL, INC.
CONSULTING MECHANICAL ENGINEERS
1725-3348
FRESNO, CALIFORNIA 93703
9/23/22 Consultant



VALLEY CHILDREN HOSPITAL PROFESSIONAL CENTER
FOUNDATION OFFICE PROJECT
1990 EAST GETTYSBURG FRESNO CA. Project

Drawing
Designed By: MB Project No.: 9116
Drawn By: AB Scale: AS NOTED
Checked By: JFM
Reviewed By: 1/93
Date: 5-9-91 Sheet: 1 of 2
M-1

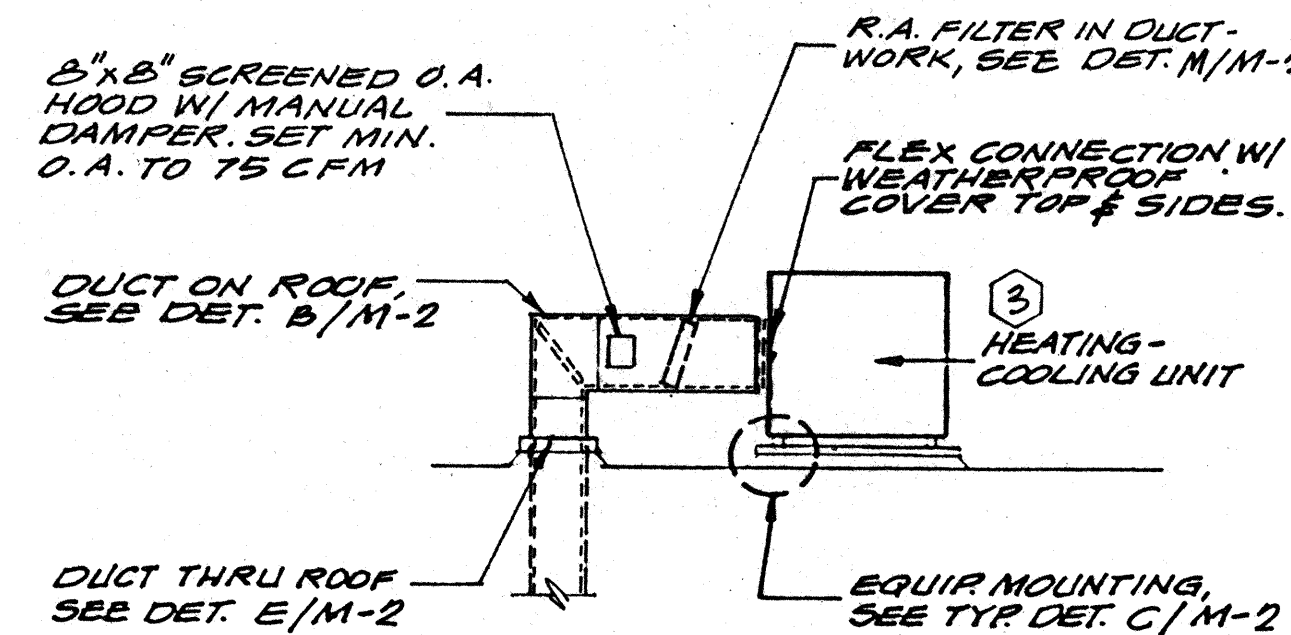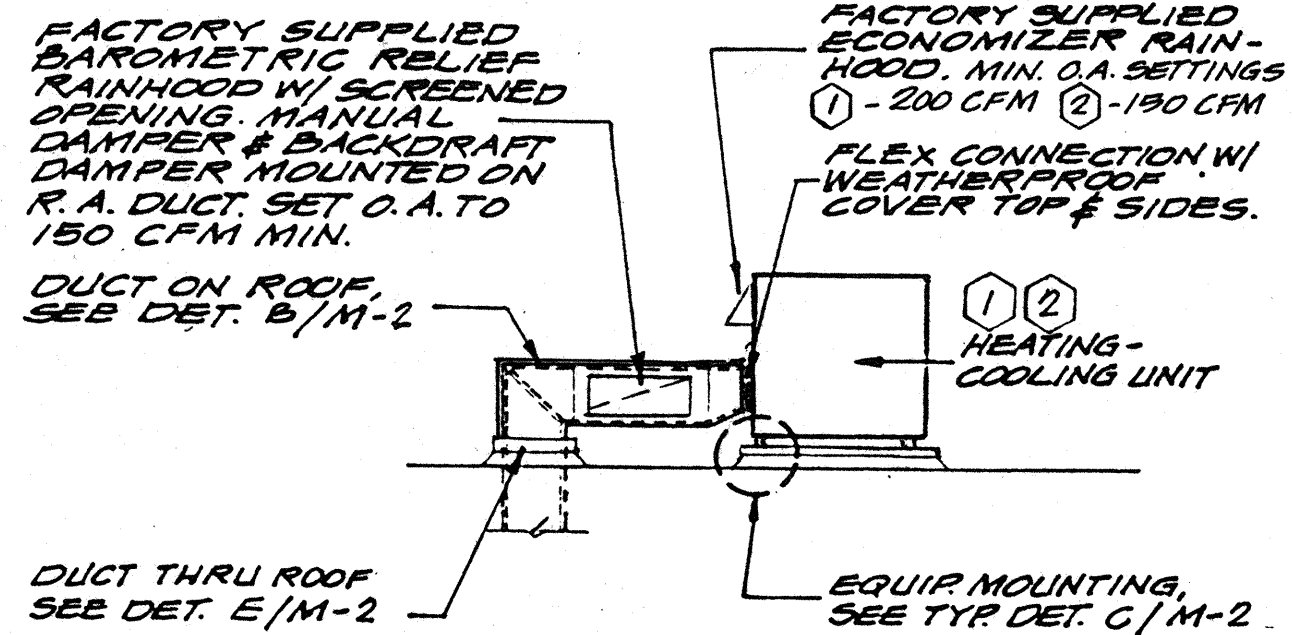



DETAIL NO SCALE (A) M-2

DETAIL NO SCALE (F) M-2

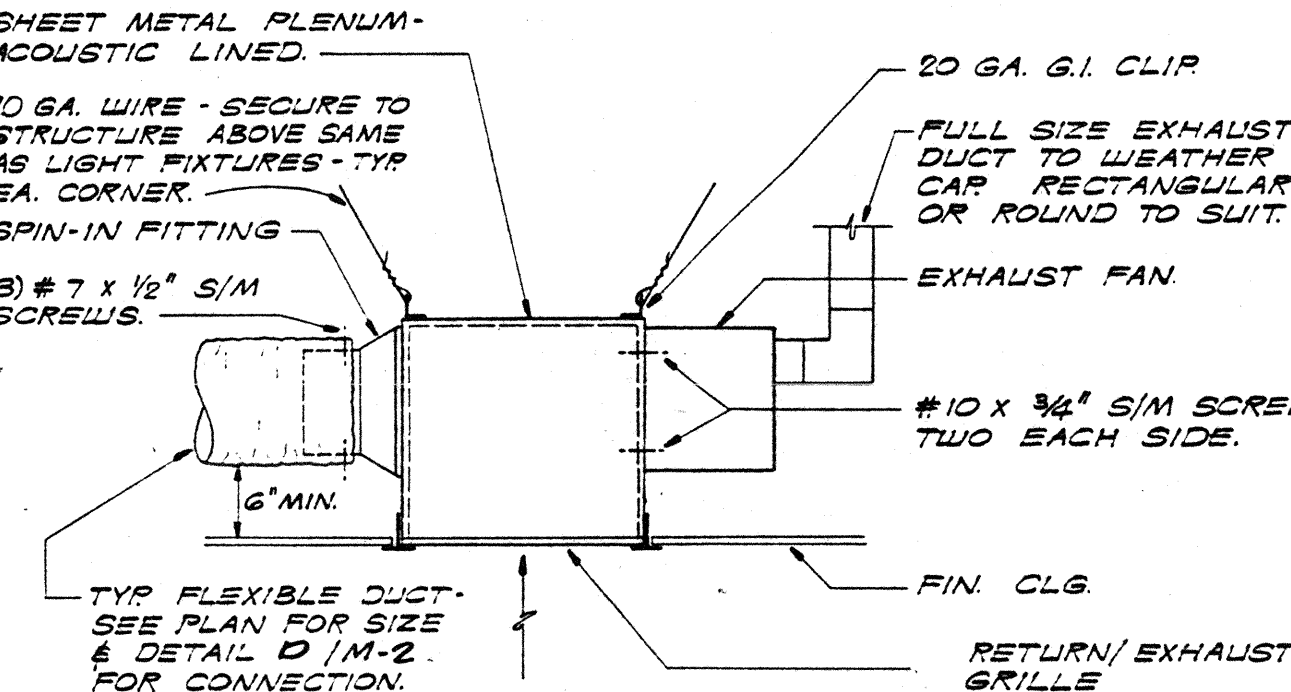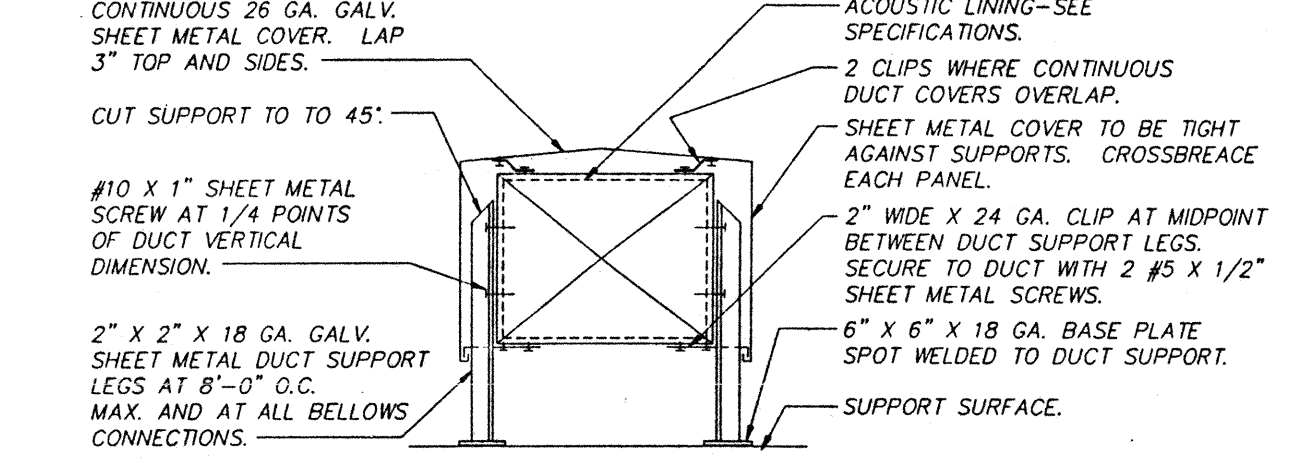



TYPICAL DUCT ON ROOF
DETAIL NO SCALE (B) M-2

RETURN/EXHAUST AIR PLENUM
DETAIL NO SCALE (G) M-2

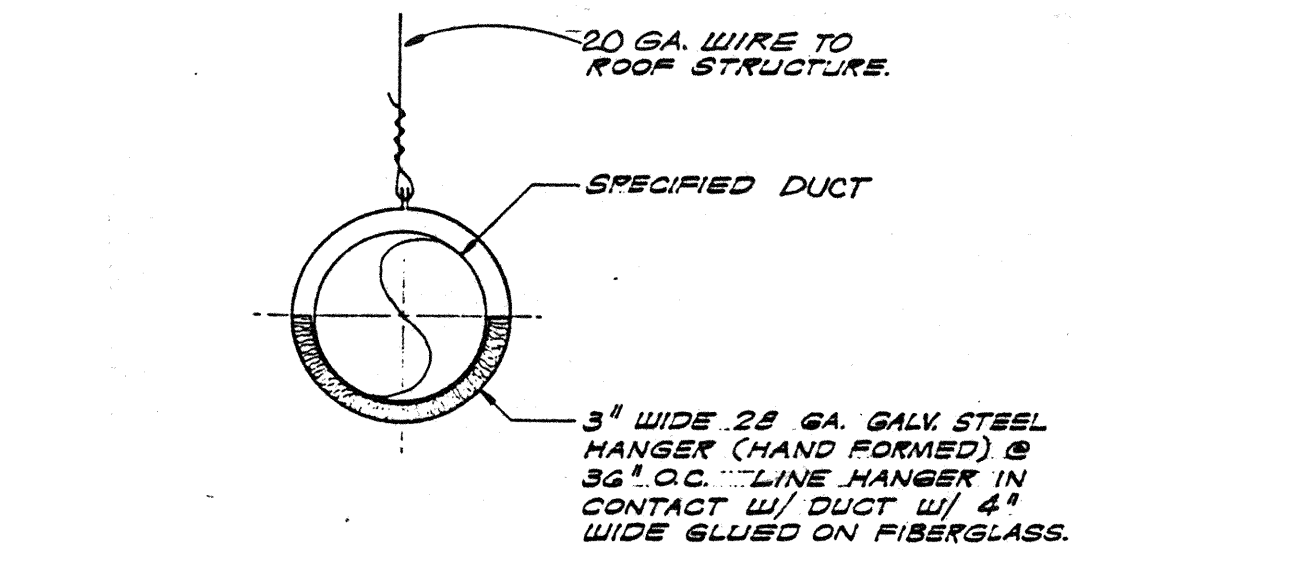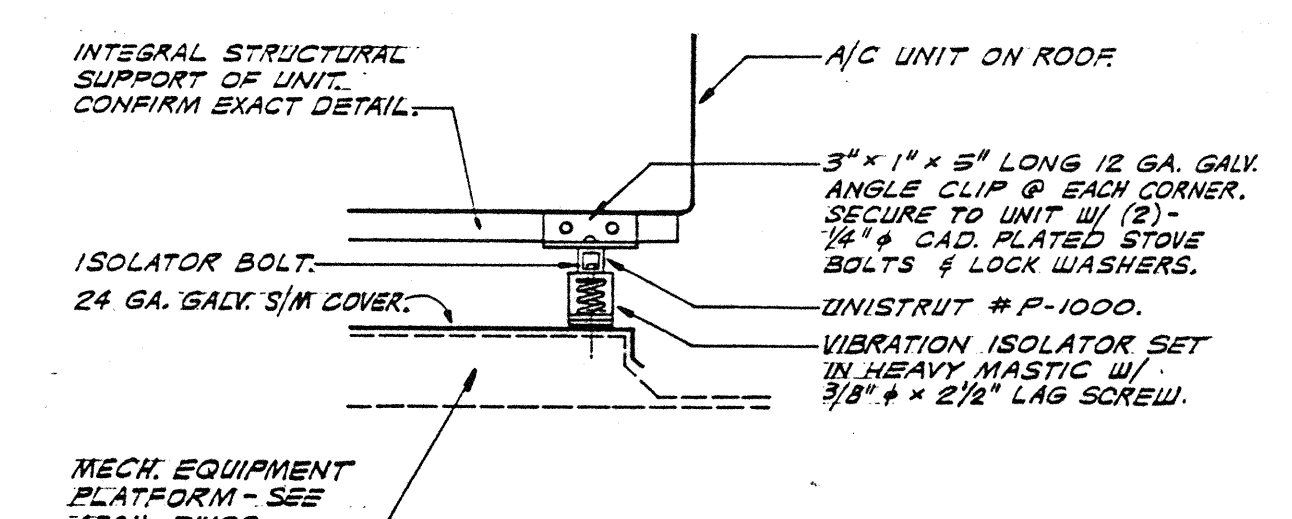



DETAIL NO SCALE (C) M-2

TYPICAL DUCT HANGER
DETAIL NO SCALE (H) M-2

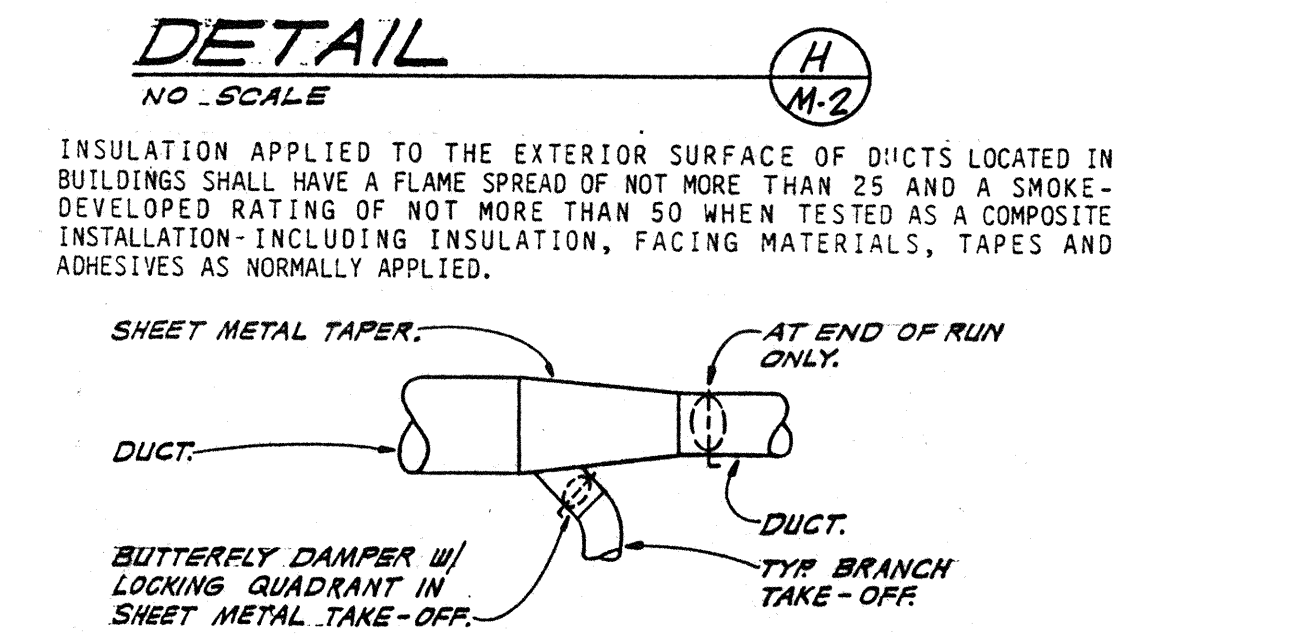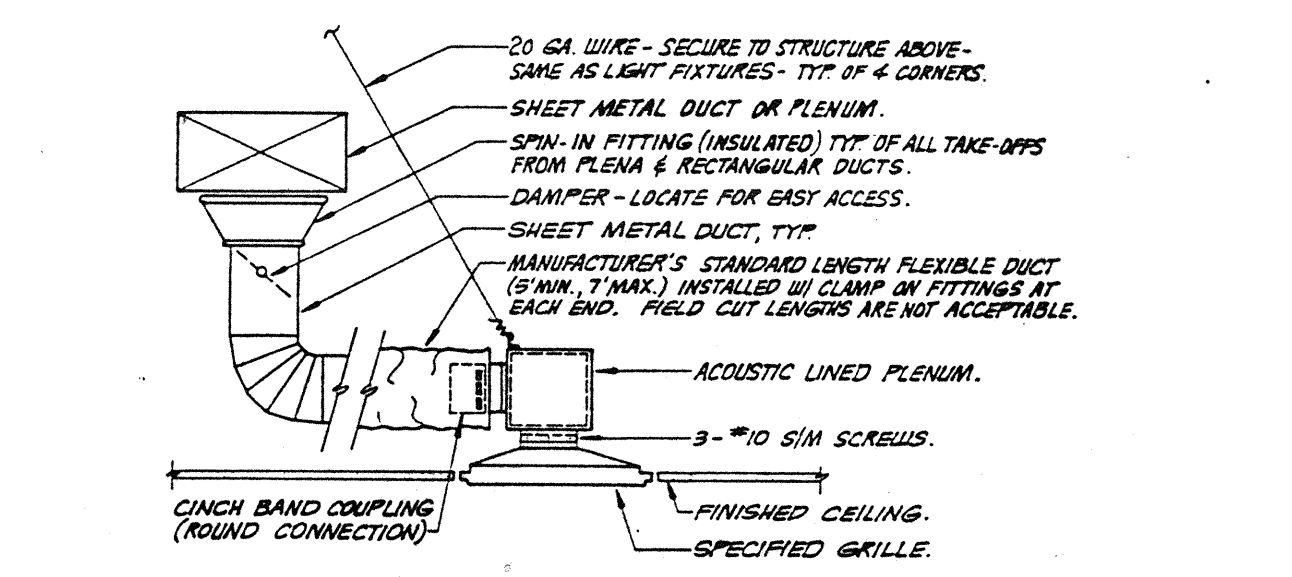

DETAIL NO SCALE (D) M-2


DETAIL NO SCALE (J) M-2

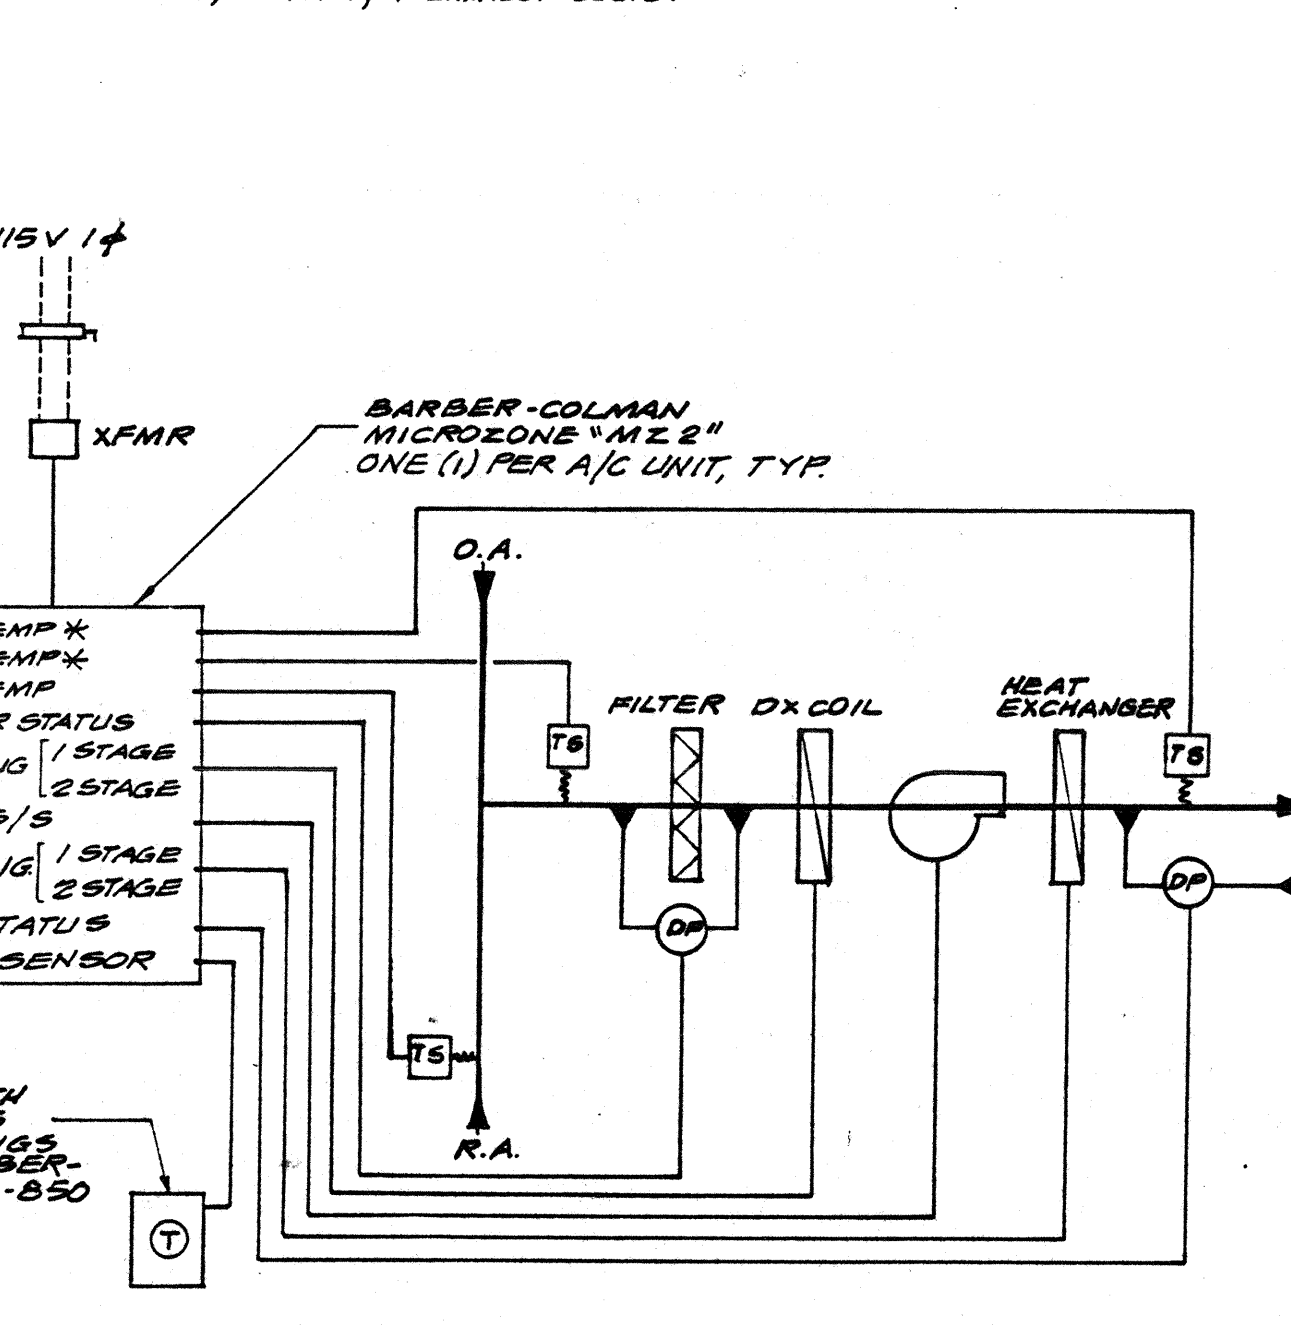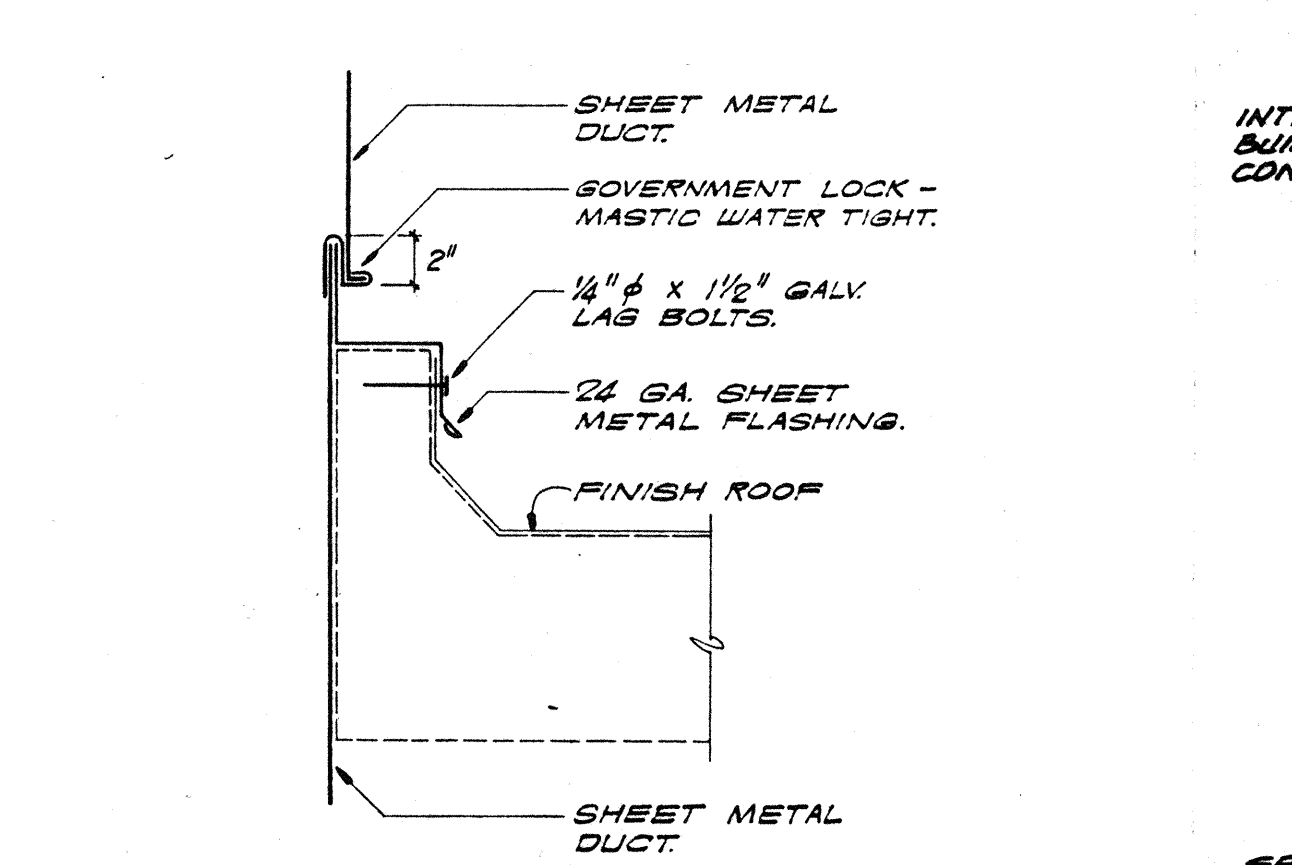


DETAIL NO SCALE (E) M-2

DETAIL NO SCALE (K) M-2
* APPLIES TO 1 2 A/C SYSTEMS W/ ECONOMIZER CONTROLS

WALL FIRE DAMPER

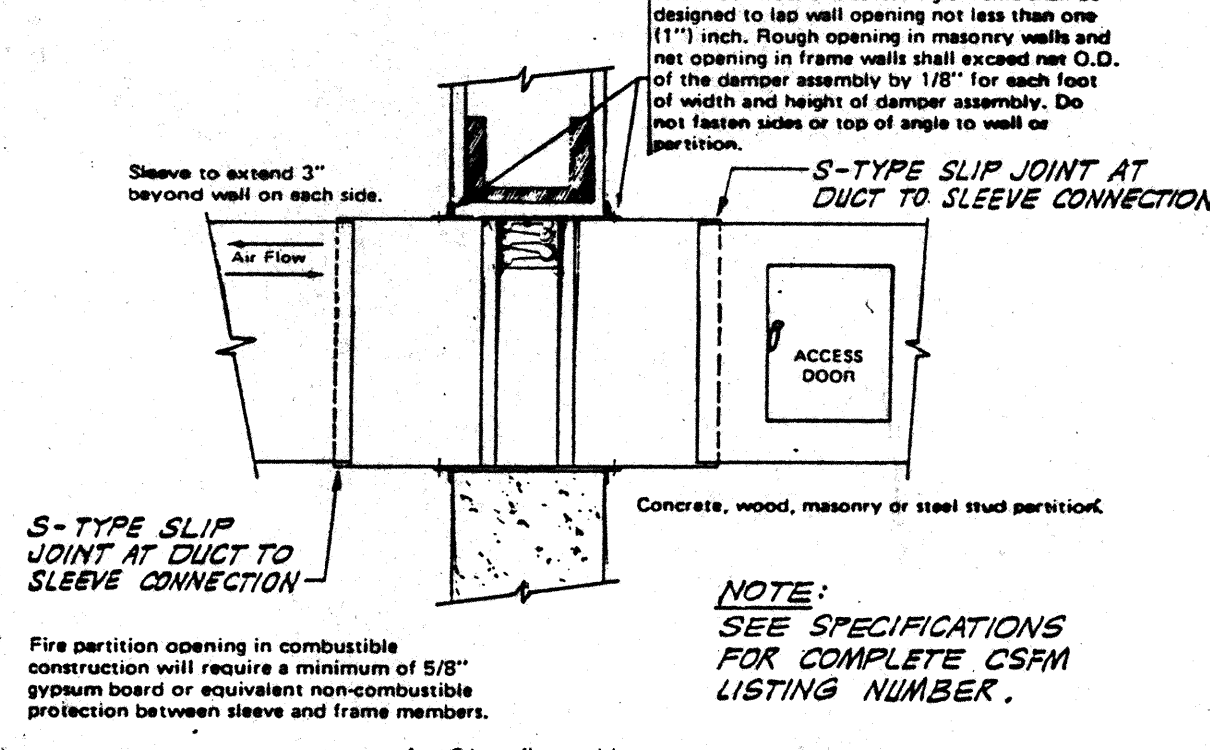

DETAIL NO SCALE (L) M-2

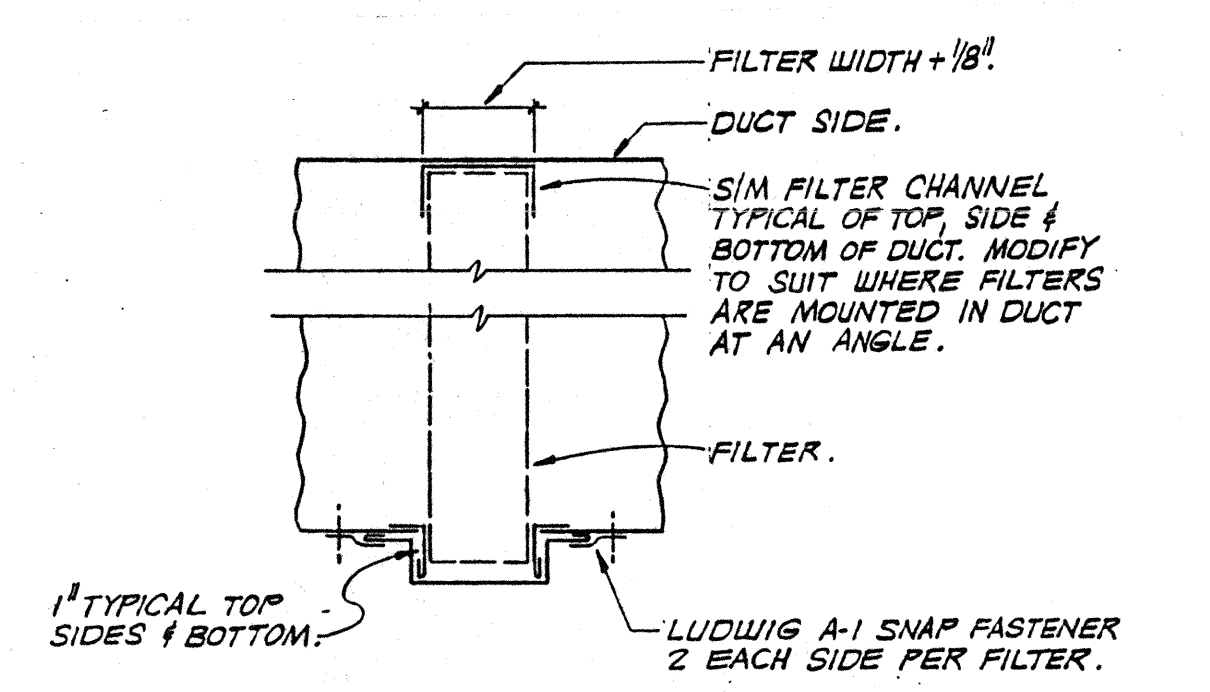

DETAIL NO SCALE (M) M-2

Certificate of Compliance (Part 1 of 2) Prescriptive Requirements CF-1A

VCH-P.C. FOUNDATION 4-25-91		For Enforcement Agency Use Only	
Project Title	DAVIDSON ASSOC	Building Permit Number	
Project Architect/Engineer	DAVIDSON ASSOC	Plan Checked By	Date
Project Location	1510 E. GETTYSBURG	Field Checked By	Date
City/Town	FRESNO	Approved By	Date
Documentation Author/Firm	JEM INC. (291) 275-3311		

Principal Designer: The proposed building will be in substantial compliance with the California Building Energy Efficiency Standards provided it is built according to the plans and specifications and provided future improvements are completed according to the requirements indicated on the Certificate of Compliance. The plans and specifications have been prepared to include all sign the plans and specifications features required for compliance with the standards. Building areas that are unconditioned and/or not subject to the standards are indicated on the plans.

General

- Unconditioned or Multi-tenant shall? ☒ N
- GEC Occupancy Type ☒ L-R OFFICE
- UBC Occupancy Group/Division ☒ B-2
- Edition of Standards ☒ 1995 date
- Conditioned Floor Area ☒ 3722 sf
- Unconditioned Floor Area ☒ N/A sf
- 1st Generation Occupancy Types
- Location Code Number
- Occupancy Code Number
- Maximum Allowable Use/area
- Standard OTTV
- 2nd Generation Occupancy Types
- Climate Zone ☒ 13
- Package Selected
- HVAC Power Criteria Set (if applicable) ☒ IV

Note: List other options and requirements significant for compliance below or on an attached supplement. For example, include intent detailed in the energy compliance documentation. Attachment becomes part of Certificate of Compliance.

14 Supplement Attached? ☒ N (Y/N)

Signature _____ Date _____

Name/Title _____

Company _____

Address _____

City/State/Zip _____

Telephone _____ Cal. License No. _____

Enforcement Agency _____

Signature _____ Date _____

Name/Title _____

Company _____

Address _____

City/State/Zip _____

Telephone _____ Cal. License No. _____

Enforcement Agency _____

Certificate of Compliance (Part 2 of 2) Prescriptive Compliance CF-1A

VCH-P.C. FOUNDATION 4-25-91		For Enforcement Agency Use Only	
Project Title	DAVIDSON ASSOC	Building Permit Number	
Project Architect/Engineer	DAVIDSON ASSOC	Plan Checked By	Date
Project Location	1510 E. GETTYSBURG	Field Checked By	Date
City/Town	FRESNO	Approved By	Date
Documentation Author/Firm	JEM INC. (291) 275-3311		

Note: More than one Part 2 may be submitted, but all must reference the same Part 1. The person responsible for the design compliance for each major building system acknowledges the following compliance statement by signing the appropriate space below.

Compliance Statement: The proposed building improvements substantially comply with the requirements indicated on the Certificate of Compliance for the building, dated 4/25/91. The plans and specifications include the significant energy conservation features and the compliance documentation is consistent with the plans and specifications.

Envelope

	Allowed	Proposed	Interior Partitioning
1 Root/Ceiling R _i		h-F-s/Btu	NO ENVELOPE CHANGES
2 Exterior Floor R _e		h-F-s/Btu	Extent of Improvements
3 Opaque Wall R _w		h-F-s/Btu	Plans dated _____
4 Exterior Wall Area		sf	Signature _____
5 Wall Glazing Area		sf	Name/Title _____
6 Average SC (Wall)		sf	Company _____
7 Total Wall % Glazing		sf	Address _____
8 West Exterior Wall Area (if applicable)		sf	City/State/Zip _____
9 Glazing Area (West Wall) (if applicable)		sf	Telephone _____
10 Average SC (West Wall) (if applicable)		sf	Cal. License No. _____
11 West Wall % Glazing		sf	Enforcement Agency _____
12 Roof Glazing? (attach CF-6)		(Y/N)	Date _____

* License office Pgs. D, E, F and all higher office Pgs.

Lighting

	Allowed	Proposed	Extent of Improvements
13 Base of Allowed LPD		Allowed	Plans dated _____
14 LPD		watts/sf	Signature _____
15 Package Lighting Reduction		watts/sf	Name/Title _____
16 Adjusted LPD		watts/sf	Company _____
17 Lighting Control Credits?		(Y/N)	Address _____

Other requirements:

Mechanical

	Allowed	Proposed	Extent of Improvements
18 Whole Building HVAC Set? (WS-4A)		(Y/N)	Plans dated _____
a. Fan Wattage Index		watts/sf	Signature _____
b. Cooling Power Index		Btus/sf	Name/Title _____
c. Heating Power Index		Btus/sf	Company _____
19 Tailored HVAC Approach? (WS-4B)		(Y/N)	Address _____
a. Heating Capacity		44.5 (units)	City/State/Zip _____
b. Cooling Capacity		27.6 (units)	Telephone _____
c. Fan Performance Index		1.00 (units)	Cal. License No. _____
20 Simultaneous Heatload? (WS-4C)		N (Y/N)	Enforcement Agency _____

Other requirements:

Materials Keying Legend

CITY OF FRESNO
DEVELOPMENT DEPARTMENT
JUL 02 1991
Any changes to these plans must be approved by the Development Department. The services of a permit State Laws.

 
 
 
Edwin S. Darden Associates, Inc.
ARCHITECTURE AND PLANNING
Edwin S. Darden FNAI / Edwin S. Darden J: AA
Martin E. Dardas AA CCS / Edwin C. Goodwin AA
1177 W. Shaw Avenue / Fresno, California 93711 / 209-222-7463
987 Oros Street / San Luis Obispo, California 94601 / 805-543-3965

JOHN FRANK MITCHELL, INC.
CONSULTING MECHANICAL ENGINEER
9133-1
1177 W. Shaw Avenue / Fresno, California 93711 / 209-222-7463
987 Oros Street / San Luis Obispo, California 94601 / 805-543-3965

VALLEY CHILDREN HOSPITAL PROFESSIONAL CENTER
FOUNDATION OFFICE PROJECT
1990 EAST GETTYSBURG FRESNO CA, Project

Drawing
Designed By: MJD Project No.: 9116
Drawn By: AW Scale: AS NOTED
Checked By: JFM
Reviewed By: JEM
Date: 5-9-91 Sheet: 2 of 2

STATE OF CALIFORNIA
JUL 1993
RENEWED



EQUIPMENT SCHEDULE									
JOB: VALLEY CHILDRENS HOSPITAL FOUNDATION									
DESIG.	DESCRIPTION	FLA/HP/KW	VOLT	Ø	OVERLOAD FUSES	CONDUIT	WIRE #	SIZE	GND
AC-1	HEATING-COOLING UNIT	16.00 FLA	480	3	30/3	3/4"	3 # 10	10	
AC-2	HEATING-COOLING UNIT	14.30 FLA	480	3	30/3	3/4"	3 # 10	10	
AC-3	HEATING-COOLING UNIT	2.60 FLA	208	1	30/2	3/4"	2 # 10	10	
EF-4	EXHAUST FAN	0.58 FLA	120	1	--	1/2"	2 # 12	12	

PANEL BOARD SCHEDULE									
PANEL 'C' (E) 150 AMP [X]120/208 3Ø 4W NEHB MIN AIC									
MOUNTING [X]FLUSH [X]SURFACE [X]LUGS ONLY [X]MAIN BREAKER									
CKT	DESCRIPTION/LOCATION	BRKR	PLS	Aph	Bph	Cph	LTS	RCP	AC MSC KIT
1	EXISTING	20	1	1.00					
3	EXISTING	20	1	1.00	1.00				
7	EXISTING	20	1	1.00					
9	EXISTING	20	1	1.00	1.00				
11	EXISTING	20	1	1.00					
13	EXISTING	20	1	1.00	1.00				
15	EXISTING	20	1	1.00					
17	EXISTING	20	1	1.00	1.00				
19	EXISTING	20	1	1.00					
21	RECP., RM. 17	20	1	0.36	0.43			1	
23	RECP., EX. FAN, RM. 13	20	1	0.90				1	
25	RECP., RM. 11 & 12	20	1	0.90				1	
27	COPIER, RM. 11	20	2	1.20	1.20				1
29		20	1						
31	RECP., RM. 1 & 2	20	1	0.90	0.90			1	
33	RECP., RM. 2 & 3	20	1	0.90	0.72			1	
35	RECP., RM. 10 & 11	20	1	0.90	0.90			1	
37	RECP., RM. 20	20	1	0.72	0.54	0.50		1	
39	RECP., RM. 20	20	1	0.90	0.90			1	
41	COMPUTER SPLITTERS	20	1	0.90	0.90			1	
42	WATER HEATER, RM. 1	20	3	1.00	1.00			1	
4		20	1	1.00	1.00				
6		20	1	1.00	1.00				
8	EXISTING	20	1	1.00	1.00				
10	EXISTING	20	1	1.00	1.00				
12	EXISTING	20	1	1.00	1.00				
14	EXISTING	20	1	1.00	0.72	0.90		1	
16	RECP., RM. 13 & 14	20	1	0.90	0.90			1	
18	RECP., RM. 14 & 15	20	1	0.90	0.90			1	
20	RECP., RM. 1 & 15	20	1	0.90	0.90			1	
22	RECP., RM. 5, 9, 21	20	1	0.90	0.90			1	
24	RECP., RM. 9	20	1	0.90	0.90			1	
26	RECP., RM. 7 & 8	20	1	0.90	0.90			1	
28	RECP., RM. 6 & 7	20	1	0.90	0.90			1	
30	RECP., RM. 5 & 6	20	1	0.90	0.90			1	
32	RECP., RM. 8 & 4	20	1	0.90	0.90			1	
34	RECP., RM. 8	20	1	0.90	0.90			1	
36	RECP., RM. 19	20	1	0.90	0.90			1	
38	RECP., RM. 18 & 19	20	1	0.90	1.60			1	
40	AC-3	20	1	1.60	1.60			1	
42		20	1						
TOTAL LOADS / PHASE				13.1	13.0	13.1	HIGH LEG AMPS = 47.4		
TOTAL LOAD				39.2 KW	47.2 AMP	0.0	16.1	6.2	2.9 0.0

PANEL BOARD SCHEDULE									
PANEL 'FAC' 175 AMP [X]1480V 3Ø 3W NEHB 10000 MIN AIC									
MOUNTING [X]FLUSH [X]SURFACE [X]LUGS ONLY [X]MAIN BREAKER									
CKT	DESCRIPTION/LOCATION	BRKR	PLS	Aph	Bph	Cph	LTS	RCP	AC MSC KIT
1	AC UNIT 1	30	3	4.43					1
3		-	-	4.43	4.43				1
7	AC UNIT 2	30	3	3.96					1
9		-	-	3.96	3.96				1
11		-	-						
13	SPACE	-	-						
15	SPACE	-	-						
17	SPACE	-	-						
19	SPACE	-	-						
21	SPACE	-	-						
23	SPACE	-	-						
25	SPACE	-	-						
27	SPACE	-	-						
29	SPACE	-	-						
31	SPACE	-	-						
33	SPACE	-	-						
35	SPACE	-	-						
37	SPACE	-	-						
39	SPACE	-	-						
41	SPACE	-	-						
42	SPACE	-	-						
4		-	-						
6		-	-						
8		-	-						
10		-	-						
12		-	-						
14		-	-						
16		-	-						
18		-	-						
20		-	-						
22		-	-						
24		-	-						
26		-	-						
28		-	-						
30		-	-						
32		-	-						
34		-	-						
36		-	-						
38		-	-						
40		-	-						
42		-	-						
TOTAL LOADS / PHASE				8.4	8.4	8.4	HIGH LEG AMPS = 30.3		
TOTAL LOAD				25.2 KW	30.3 AMP	0.0	0.0	25.2	0.0 0.0


Materials Keying Legend

SHEET NOTES:


- 1 5' WIDE TELEPHONE BACK BOARD.
- 2 3KW 120V INSTANTANEOUS WATER HEATER, BELOW COUNTER.
- 3 EXHAUST FAN CONTROLLER, FURNISHED WITH EXHAUST FAN.
- 4 UNIT TO BE ABANDONED IN PLACE. SEE CORRESPONDING NOTE ON SHEET M-1.
- 5 INTERCEPT EXISTING 1 1/2" C FEEDING AC UNIT AND EXTEND TO NEW PANEL 'FL'. REFER TO SINGLE LINE DIAGRAM.
- 6 INTERCEPT EXISTING 1 1/2" C FEEDING AC UNIT AND EXTEND TO NEW PANEL 'FAC'. REFER TO SINGLE LINE DIAGRAM FOR DETAIL.

ROOM SCHEDULE - FOUNDATION OFFICE

ROOM NUMBER	ROOM DESCRIPTION	ROOM NUMBER	ROOM DESCRIPTION
1	RECEPTION	12	SECRETARY
2	ANNUAL GIVING	13	CONFERENCE
3	PLANNED GIVING	14	DIRECTOR
4	STORAGE	15	DIRECTOR SECRETARY
5	GRANTS	16	CORRIDOR
6	DATA PROCESSOR	17	TELEPHONE EQUIPMENT
7	ACCOUNTANT	18	CAPITOL CAMPAIGN
8	DEVELOPMENT COORD.	19	TRANSCRIPTION
9	DONOR RELATIONS COORD.	20	OFFICE
10	SECRETARY	21	COFFEE
11	SUPPLY ROOM	22	HALL
		23	CORRIDOR

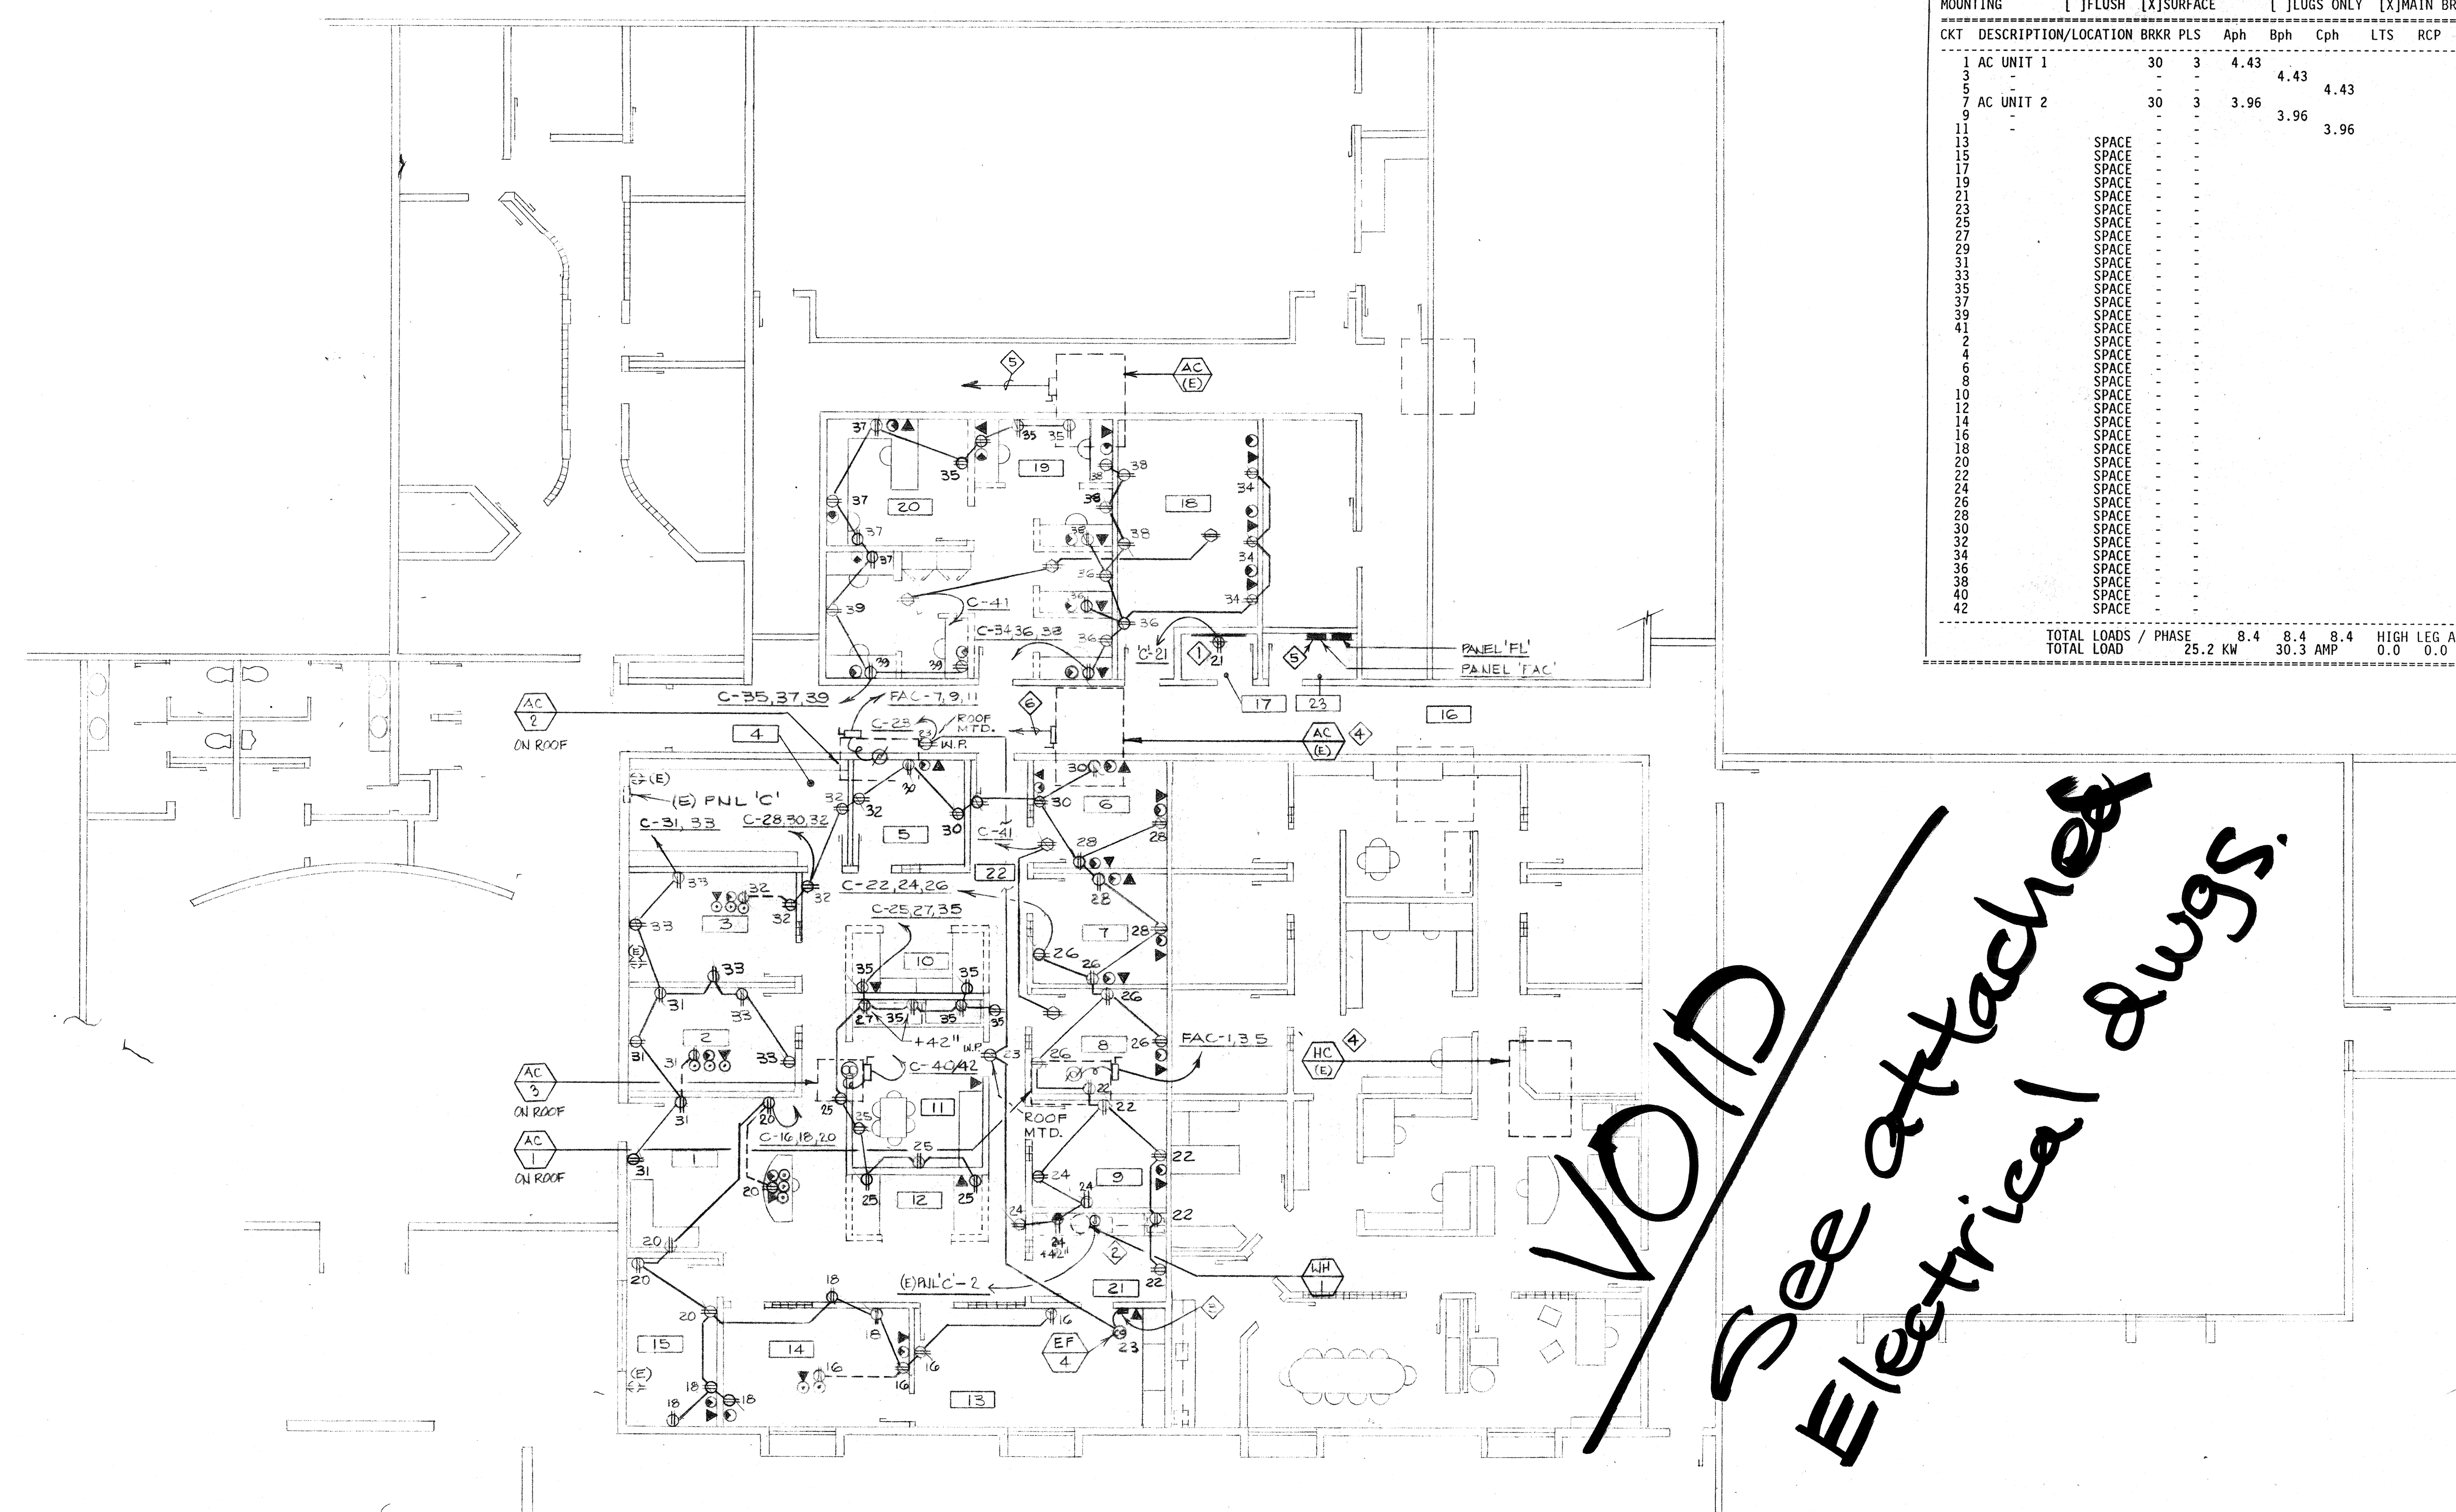


VOID
See attached
Electrical Drawings.

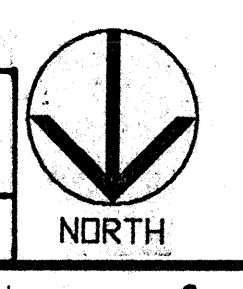

No. _____

Revisions/Submissions _____


Date: _____

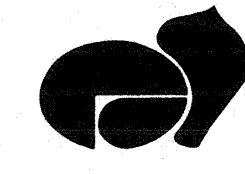**Edwin S. Darden Associates, Inc.**
ARCHITECTURE AND PLANNING
Edwin S. Darden FAIA / Edwin S. Darden Jr. AIA
Martin E. Dier AIA CCS Edwin C. Goodwin AIA
1177 W. Shaw Avenue / Fresno, California 93711 / 209.222.7463
987 Ocas Street / San Luis Obispo, California 93401 / 805.543.9965

EPS & Associates, Inc.
Professional Engineers
4049 N. Fresno St. Fresno, CA 93726
(209) 221-7230
Consultant

VCH PROFESSIONAL CENTER
FOUNDATION OFFICE
Project _____

POWER & SIGNAL PLAN
Drawing _____

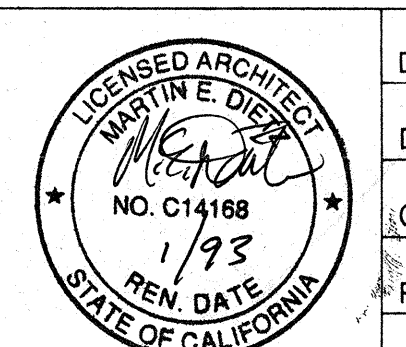

Designed By: _____ Project No.: _____
Drawn By: _____ Scale: 1/8"=1'-0"
Checked By: _____
Reviewed By: _____
Date: _____

E100


Sheet: _____ of _____

R
P
O
N
M
L
K
J
H
G
F
E
D
C
B
A

PANEL BOARD SCHEDULE									
NEHB 10,000 MW AIC									
PANEL "FL"	150 AMP	[X]480/277 3ph 4w	NEMA 1[X] 12/3R[]						
MOUNTING	[X]FLUSH []SURFACE	[]LUGS ONLY	[X]MAIN BREAKER						
CKT DESCRIPTION/LOCATION	BRKR	PLS	APh	Bph	Cph	LTS	RCP	AC	MSC KIT
1 LIGHTS, RM. 6-9,13-15	20	1			2.61	2.92		1	
3 LIGHTS, RM. 1-5,10,11	20	1							
5 SPARE	20	1							
7 SPARE	20	1			0.50				
9 SPARE	20	1							
11 SPARE	20	1			0.50	0.50			
13 SPARE	20	1							
15 SPARE	20	1			0.50				
17 SPARE	20	1							
19 SPARE	20	1			0.50	0.50			
21 SPARE	20	1							
23 SPARE	20	1							
25 SPARE	20	1							
27 SPARE	20	1							
29 SPARE	20	1							
31 SPARE	20	1							
33 SPARE	20	1							
35 SPARE	20	1							
37 SPARE	20	1							
39 SPARE	20	1							
41 SPARE	20	1							
2 LIGHTS, CORRIDOR	20	1			0.59	1.81		1	
4 LIGHTS, RM. 17-20, 23	20	1							
6 SPARE	20	1			0.50	0.50			
8 SPARE	20	1							
10 SPARE	20	1			0.50	0.50			
12 SPARE	20	1							
14 SPARE	20	1			0.50	0.50			
16 SPARE	20	1							
18 SPARE	20	1							
20 SPARE	20	1							
22 SPARE	20	1							
24 SPARE	20	1							
26 SPARE	20	1							
28 SPARE	20	1							
30 SPARE	20	1							
32 SPARE	20	1							
34 SPARE	20	1							
36 SPARE	20	1							
38 SPARE	20	1							
40 SPARE	20	1							
42 SPARE	20	1							
TOTAL LOADS / PHASE									
TOTAL LOAD				14.4 KW	5.2	6.7	2.5	HIGH LEG AMPS = 24.3	
					17.4 AMP	6.1	0.0	0.0	0.0

LIGHTING FIXTURE SCHEDULE					
FIXT DESIG	DESCRIPTION	LAMP # & TYPE	FIXTURE WATTS	FIXTURE MOUNT'G	MANUFACTURER
AA3	2x4 FLUORESCENT TROFFER	3-F40 T8RS	115	RECESSED T-BAR	LITHONIA #2SPG 340 A12.125
AA3	REGRESS ALUM. HINGED & SPRING				
AA3	LOADED LATCHED DOOR				
AA3	ACRYLIC #12.125 LENS				
AA3	W/O BALLAST INTERTIE				
AA4	2x4 FLUORESCENT TROFFER	4-F40 T8RS	150	RECESSED T-BAR	LITHONIA #2SPG 440 RW A12.125
AA4	REGRESS ALUM. HINGED & SPRING				
AA4	LOADED LATCHED DOOR				
AA4	ACRYLIC #12.125 LENS				
BA1	2x2 FLUORESCENT TROFFER	2-F40U T8RS	75	RECESSED T-BAR	LITHONIA #2SPG 2U40 RW A12.125
BA1	REGRESS ALUM. HINGED & SPRING				
BA1	LOADED LATCHED DOOR				
BA1	ACRYLIC #12.125 LENS				
BA2	2x2 FLUORESCENT TROFFER	3-F40U T8RS	115	RECESSED T-BAR	LITHONIA #2SPG 3U40 RW A12.125
BA2	REGRESS ALUM. HINGED & SPRING				
BA2	LOADED LATCHED DOOR				
BA2	ACRYLIC #12.125 LENS				
BA2	W/ BALLAST INTERTIE				
JB3	4' FLUORESCENT STRIP	2-F40 T8RS	75	SURFACE	LITHONIA #C240
JB3	STANDARD CHANNEL				
MB1	6" DIA. DOWN LIGHT	2-PL9	18	RECESSED	LITHONIA #LF 2/9TT-FB3
MB1	SPECULAR CLEAR ALZAK REFLECTOR W/ BLACK BAFFLE				
MB5	6" DIA. DOWN LIGHT	1-R40	100	RECESSED T-BAR	LITHONIA #RB3LICS-LSMC-LBH
MB5	MATTE BLACK STEPPED BAFFLE				
MB6	4 3/4" DIA. DOWN LIGHT	1-MR16	50	RECESSED T-BAR & PLASTER	HALO #H-1499RT-1421MB
MB6	SPECULAR REFLECTOR W/ BLACK BAFFLE				
RC2	METAL HALIDE SCENCE	150 MH	150	WALL	ELLIPTIPAR #T427 SERIES
RC2	ASYMMETRIC DISTRIBUTION SPECIAL DESIGN				
TH2	9"x4 3/4" V SHAPED LINEAR	2-F40 T8RS	75	PENDANT	COLUMBIA #BSK-V9PM-240RS-4-WHT
TH2	INDIRECT, 20 GA. COLD ROLLED STEEL HOUSING				
TH4	9"x4 3/4" V SHAPED LINEAR	4-F40 T8RS	150	PENDANT	COLUMBIA #BSK-V9PM-440RS-8-WHT
TH4	INDIRECT, 20 GA. COLD ROLLED STEEL HOUSING, SPECIAL COLOR AS SELECTED BY ARCHITECT				
TH4	EXIT SIGN	2-FSTT	30	RECESSED WALL	SIGNATURE #F2RE-S-BLANK-1-G-HDEE N-277-ELN
YAI	EMERGENCY, BATTERY OPERATED WALL MOUNTED POWER SYSTEM	2-PAR 36	30	WALL	LITHONIA #ELT LC 200

NOTE: PROVIDE ALL FLUORESCENT FIXTURES WITH SOLID STATE BALLASTS.

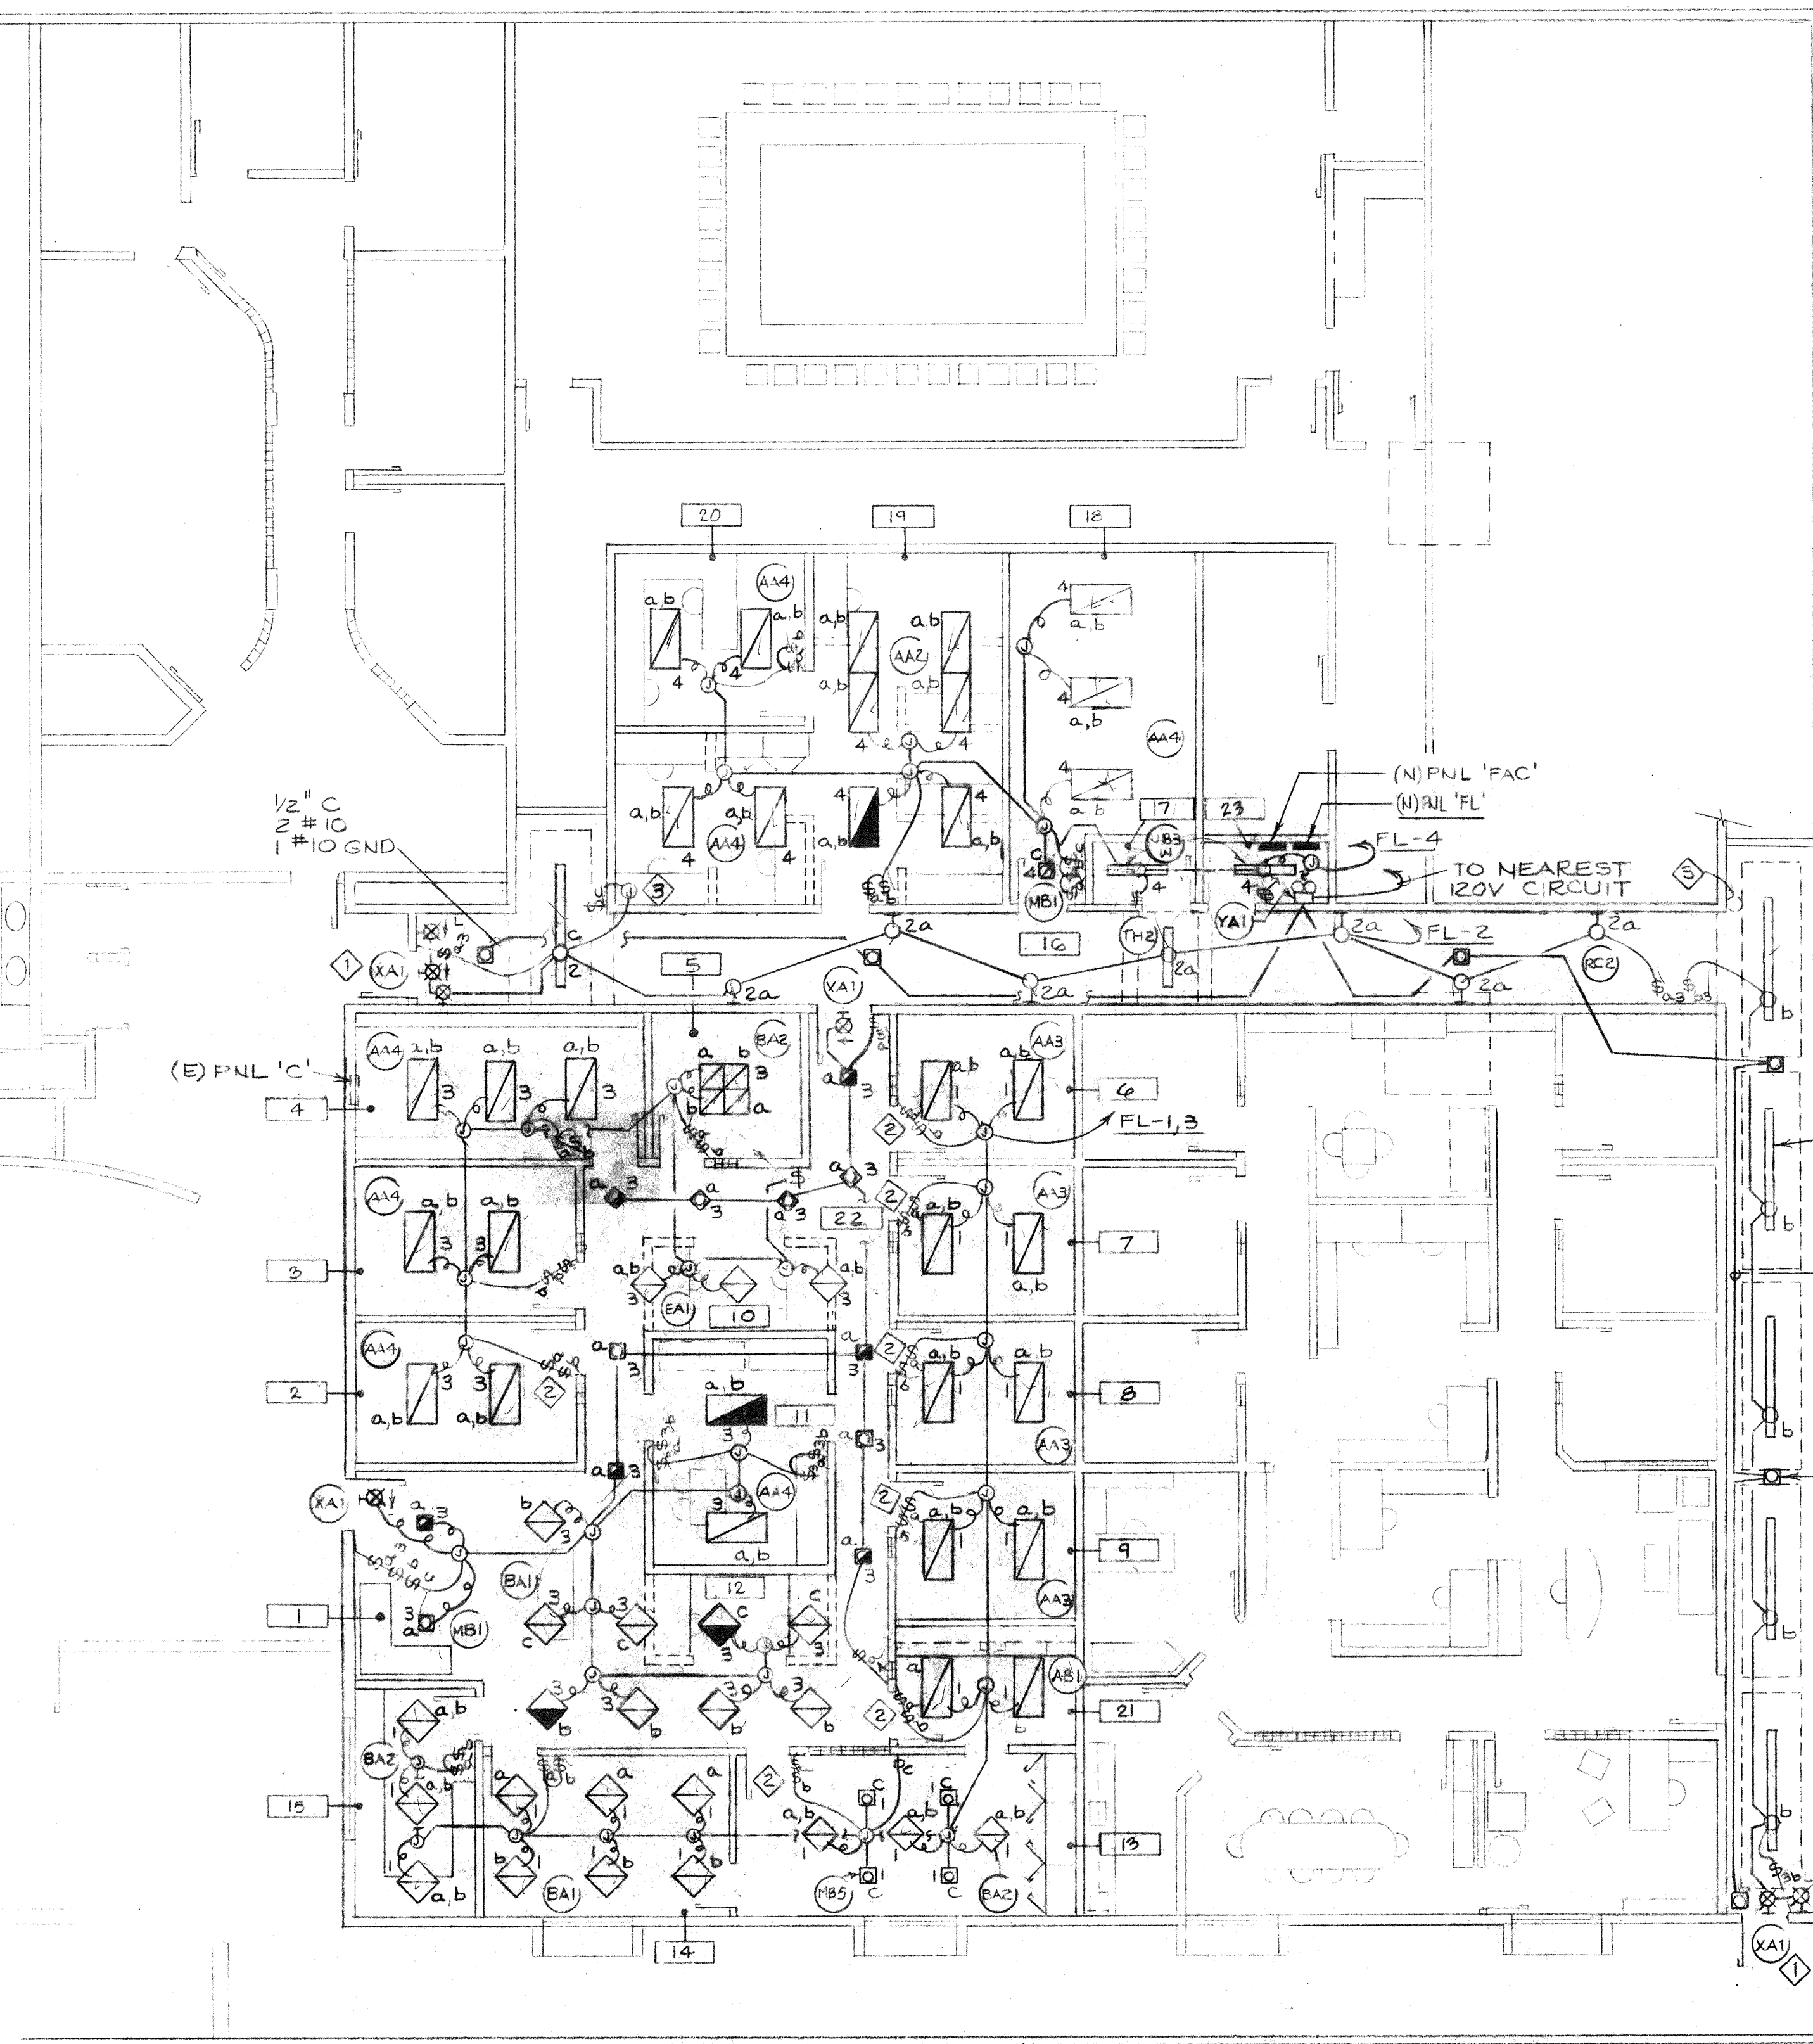

Materials Keying Legend			
NOTES:			
1	EXIT SIGN WITH COMPANION LOW LEVEL SIGN MOUNTED @ +12" A.F.F. MAX.		
2	SINGLE GANG SWITCH BOX, 1-STACK SWITCH WITH 2 SINGLE POLE SWITCHES. TYPICAL OF ALL STACKED SWITCH LOCATIONS.		
3	PROVIDE 4 SQUARE BOX WITH BLANK COVER PLATE, STUB CONDUIT ABOVE CEILING FOR FUTURE.		

ROOM SCHEDULE - FOUNDATION OFFICE			
ROOM NUMBER	ROOM DESCRIPTION	ROOM NUMBER	ROOM DESCRIPTION
1	RECEPTION	12	SECRETARY
2	ANNUAL GIVING	13	CONFERENCE
3	PLANNED GIVING	14	DIRECTOR
4	STORAGE	15	DIRECTOR SECRETARY
5	GRANTS	16	CORRIDOR
6	DATA PROCESSOR	17	TELEPHONE EQUIPMENT
7	ACCOUNTANT	18	CAPITOL CAMPAIGN
8	DEVELOPMENT COORD.	19	TRANSCRIPTION
9	DONOR RELATIONS COORD.	20	OFFICE
10	SECRETARY	21	COFFEE
11	SUPPLY ROOM	22	HALL
		23	ELECTRICAL

No. Revisions/Submissions Date:

Edwin S. Darden Associates, Inc.
ARCHITECTURE AND PLANNING
Edwin S. Darden FAIA / Edwin S. Darden Jr. AIA
Martin E. Dietz AIA CCS / Edwin C. Goodwin AIA
1177 W. Shaw Avenue / Fresno, California 93711 / 209 222-7463
987 Oaks Street / San Luis Obispo, California 93401 / 805 543-3965

EPS & Associates, Inc.
Professional Engineers
4049 N. Fresno St. Fresno, CA 93726
(209) 221-7230

Consultant

VCH PROFESSIONAL CENTER
FOUNDATION OFFICE

Project

LIGHTING PLAN


Drawing

Designed By: Project No.:
Drawn By: Scale: 1/8"-1'-0"
Checked By:
Reviewed By:
Date: Sheet: of:

E101

EQUIPMENT SCHEDULE									
JOB: VALLEY CHILDRENS HOSPITAL FOUNDATION									
DESIG.	DESCRIPTION	FLA/HP/KW	VOLT	Ø	OVERLOAD FUSES	CONDUIT	WIRE # SIZE	GND	
AC-1	HEATING-COOLING UNIT	16.00 FLA	480	3	30/3	3/4"	3 # 10	10	
AC-2	HEATING-COOLING UNIT	14.30 FLA	480	3	30/3	3/4"	3 # 10	10	
AC-3	HEATING-COOLING UNIT	2.60 FLA	208	1	30/2	3/4"	2 # 10	10	
EF-4	EXHAUST FAN	0.58 FLA	120	1	--	1/2"	2 # 12	12	

PANEL BOARD SCHEDULE							NQOD		MIN AIC		
PANEL "H" (N)		225 AMP		[X]208/120 3ph 4w		NEMA 1[X] 12/3R[]					
MOUNTING		[]FLUSH		[X]SURFACE		[]LUGS ONLY		[X]MAIN BREAKER			
CKT	DESCRIPTION/LOCATION	BRKR	PLS	Aph	Bph	Cph	LTS	RCP	AC	MSC	KIT
* 1											
* 3											
* 5											
* 7											
* 9											
* 11											
* 13											
* 15											
* 17											
* 19											
* 21											
* 23											
* 25											
* 27											
* 29											
31	RECP'T, RM 17	20	1	0.72					1		
33	COMPUTER SPLITTERS	20	1		0.30				1		
35	RECP'T, RM 19, 20	20	1			0.72			1		
37	RECP'T, RM 19, 20	20	1	0.72					1		
39	RECP'T, RM 19, 20	20	1		0.72				1		
41											
* 42											
* 4											
* 6											
* 8											
* 10											
* 12											
* 14											
* 16											
* 18											
* 20											
* 22											
* 24											
26	RECP'T, RM 18	20	1	0.54					1		
28	RECP'T, RM 18, 19	20	1		0.90				1		
30	RECP'T, RM 18, 19	20	1			0.90			1		
32											
34											
36											
38											
40											
42											
TOTAL LOADS / PHASE				2.0	1.9	1.6	HIGH LEG AMPS =		16.5		
TOTAL LOAD				5.5 KW	15.3 AMP		0.0 5.5 0.0		0.0	0.0	0.0

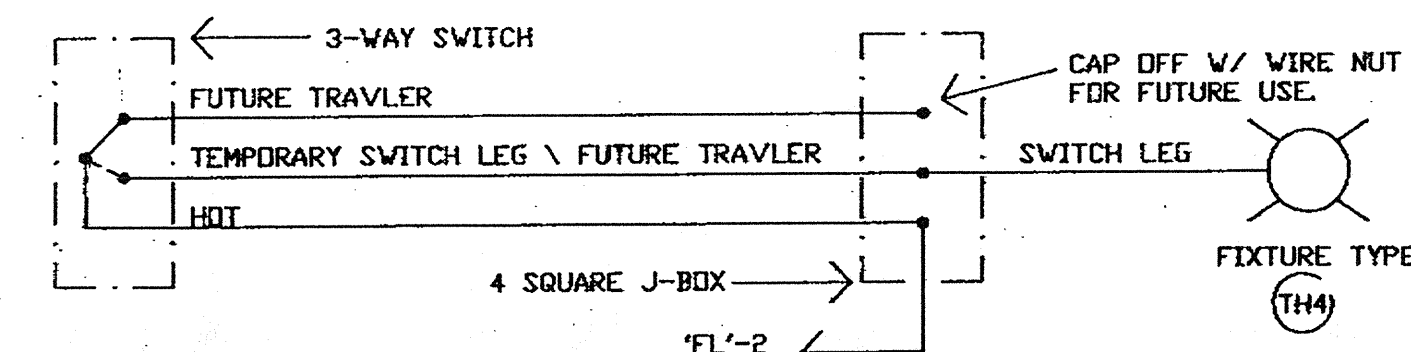

71 HALL LIGHTING CONTROL
NOT TO SCALE

PANEL BOARD SCHEDULE									
PANEL "FL"	150 AMP	NEHB	10,000 MIN AIC						
MOUNTING	[X] FLUSH	[] SURFACE	[X] 480/277 3ph 4w	[X] 12/3R	[X] MAIN BREAKER				
CKT DESCRIPTION/LOCATION	BRKR PLS	Aph	Bph	Cph	LTS	RCP	AC	MSC	KIT
1 LIGHTS, RM. 6-9,13-15	20	1	2.61	2.92	0.50	1			
2 LIGHTS, RM. 1-5,10,11	20	1							
3 SPARE	20	1	0.50						
4 SPARE	20	1							
5 SPARE	20	1	0.50						
6 SPARE	20	1							
7 SPARE	20	1	0.50						
8 SPARE	20	1							
9 SPARE	20	1	0.50						
10 SPARE	20	1							
11 SPARE	20	1							
12 SPARE	20	1							
13 SPARE	20	1							
14 SPARE	20	1							
15 SPARE	20	1							
16 SPARE	20	1							
17 SPARE	20	1							
18 SPARE	20	1							
19 SPARE	20	1							
20 SPARE	20	1							
21 SPARE	20	1							
22 SPARE	20	1							
23 SPARE	20	1							
24 SPARE	20	1							
25 SPARE	20	1							
26 SPARE	20	1							
27 SPARE	20	1							
28 SPARE	20	1							
29 SPARE	20	1							
30 SPARE	20	1							
31 SPARE	20	1							
32 SPARE	20	1							
33 SPARE	20	1							
34 SPARE	20	1							
35 SPARE	20	1							
36 SPARE	20	1							
37 SPARE	20	1							
38 SPARE	20	1							
39 SPARE	20	1							
40 SPARE	20	1							
41 SPARE	20	1							
42 SPARE	20	1							
43 CORRIDOR	20	1	0.59	1.81	0.50	1			
44 LIGHTS, RM. 17-20, 23	20	1							
45 SPARE	20	1	0.50						
46 SPARE	20	1							
47 SPARE	20	1	0.50						
48 SPARE	20	1							
49 SPARE	20	1	0.50						
50 SPARE	20	1							
51 SPARE	20	1							
52 SPARE	20	1							
100 SPARE	20	1							
TOTAL LOADS / PHASE	5.2	6.7	2.5	HIGH LEG AMPS = 24.3					
TOTAL LOAD	14.4 KW	17.4 AMP	6.1	0.0	0.0	0.0	0.0	0.0	0.0

LIGHTING FIXTURE SCHEDULE						
FIXT DESIG	DESCRIPTION	LAMP # & TYPE	FIXTURE WATTS	FIXTURE MOUNT'G	MANUFACTURER	
AA3	2x4 FLUORESCENT TROFFER	3-F032/31K	115	RECESSED T-BAR	LITHONIA #2SPG 340 A12.125	
AA3	REGRESS ALUM. HINGED & SPRING LOADED LATCHED DOOR	31K T8RS				
AA3	ACRYLIC #12.125 LENS W/O BALLAST INTERTIE					
AA4	2x4 FLUORESCENT TROFFER	4-F032/31K	150	RECESSED T-BAR	LITHONIA #2SPG 440 RW A12.125	
AA4	REGRESS ALUM. HINGED & SPRING LOADED LATCHED DOOR	31K T8RS				
AA4	ACRYLIC #12.125 LENS					
BA1	2x2 FLUORESCENT TROFFER	2-F032/31K	75	RECESSED T-BAR	LITHONIA #2SPG 2U40 RW A12.125	
BA1	REGRESS ALUM. HINGED & SPRING LOADED LATCHED DOOR	31K T8RS				
BA1	ACRYLIC #12.125 LENS					
BA2	2x2 FLUORESCENT TROFFER	3-F032/31K	115	RECESSED T-BAR	LITHONIA #2SPG 3U40 RW A12.125	
BA2	REGRESS ALUM. HINGED & SPRING LOADED LATCHED DOOR	31K T8RS				
BA2	ACRYLIC #12.125 LENS W/ BALLAST INTERTIE					
JB3	4' FLUORESCENT STRIP STANDARD CHANNEL	2-F032/31K T8RS	75	SURFACE	LITHONIA #C240	
MB1	6" DIA. DOWN LIGHT	2-PL9	18	RECESSED	LITHONIA #LF 2/9TT-FB3	
MB1	SPECULAR CLEAR ALZAK REFLECTOR W/ BLACK BAFFLE					
MB5	6" DIA. DOWN LIGHT W/ MATTE BLACK STEPPED BAFFLE	1-R40	100	RECESSED T-BAR	LITHONIA #RB3LIC5-LSMC-LBH	
MB6	4 3/4" DIA. DOWN LIGHT	1-MR16	50	RECESSED T-BAR & PLASTER	HALO #H-1499RT-1421MB	
MB6	SPECULAR REFLECTOR W/ BLACK BAFFLE					
RC2	METAL HALIDE SCONCE	150 MH	150	WALL	ELLIPTIPAR #T427 SERIES	
RC2	ASYMMETRIC DISTRIBUTION SPECIAL DESIGN					
TE2	9"x3"x4' LONG CHANNEL, LINEAR INDIRECT, SPECIAL COLOR AS SELECTED BY ARCHITECT.	2-F032/31K T8RS	75	PENDANT	COLUMBIA #BSK-V9PM-240RS-4-WHT	
TE4	9"x3"x8' LONG CHANNEL, LINEAR INDIRECT, SPECIAL COLOR AS SELECTED BY ARCHITECT.	4-F032/31K T8RS	150	PENDANT	COLUMBIA #BSK-V9PM-440RS-8-WHT	
TH4	EXIT SIGN	2-F5TT	30	RECESSED WALL	SIGNATURE #F2RE-S-BLANK-1-G-HDEE N-277-ELN	
YA1	EMERGENCY BATTERY POWERED WALL MOUNTED POWER SYSTEM	2-PAR 36	30	WALL	LITHONIA #ELT LC 200	

NOTE: PROVIDE ALL FLUORESCENT FIXTURES WITH SOLID STATE BALLASTS.


ROOM SCHEDULE - FOUNDATION OFFICE

ROOM NUMBER	ROOM DESCRIPTION	ROOM NUMBER	ROOM DESCRIPTION
1	RECEPTION	12	SECRETARY
2	ANNUAL GIVING	13	CONFERENCE
3	PLANNED GIVING	14	DIRECTOR
4	STORAGE	15	DIRECTOR SECRETARY
5	GRANTS	16	CORRIDOR
6	DATA PROCESSOR	17	TELEPHONE EQUIPMENT
7	ACCOUNTANT	18	CAPITOL CAMPAIGN
8	DEVELOPMENT COORD.	19	TRANSCRIPTION
9	DONOR RELATIONS COORD.	20	OFFICE
10	SECRETARY	21	COFFEE
11	SUPPLY ROOM	22	HALL
		23	ELECTRICAL

CITY OF FRESNO
DEVELOPMENT DEPARTMENT

JUL 02 1991

Any changes to these plans must be approved by the Development Department. The assistance of a permit does not grant to any person the right to violate City or State Laws. APPROVED

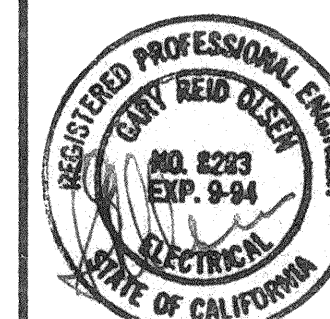

No. Revisions/Submissions Date:


Edwin S. Darden Associates, Inc.
ARCHITECTURE AND PLANNING
Edwin S. Darden FAIA / Edwin S. Darden Jr. AIA
Martin E. Dietz AIA CCS / Edwin C. Goodwin AIA
1177 W. Shaw Avenue / Fresno, California 93711 / 209 222-7483
987 Coco Street / San Luis Obispo, California 93401 / 805 545-3965

EPS & Associates, Inc.
Professional Engineers
4049 N. Fresno St. Fresno, CA 93726
(209) 221-7230 Consultant

VCH PROFESSIONAL CENTER
FOUNDATION OFFICE Project

LIGHTING PLAN Drawing

Designed By: Project No.:
Drawn By: Scale: 1/8"=1'-0"
Checked By:
Reviewed By: E101
Date: Sheet: of:

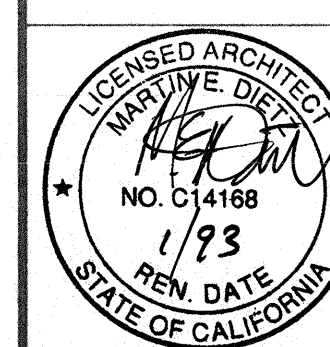

A 1 LIGHTING PLAN

1/8"=1'-0"




CHANGE ORDER INFORMATION

These drawings are for changes to the previously approved drawings for Valley Children's Professional Center, 1990 East Gettysburg, Fresno, Ca. Previously approved projects include the following:


1. Foundation Office, P.C. No. 910776
2. Human Resources Office, P.C. No. 911051
3. Conference Room, P.C. No. 911052

The scope of work for the changes includes the following:

1. Modification of the Corridor cgs., all P.C. Numbers.
2. Modification to the exterior stairs and landing for the Foundation Office Project.
3. Modification to the small office of the Human Resources Office Project.

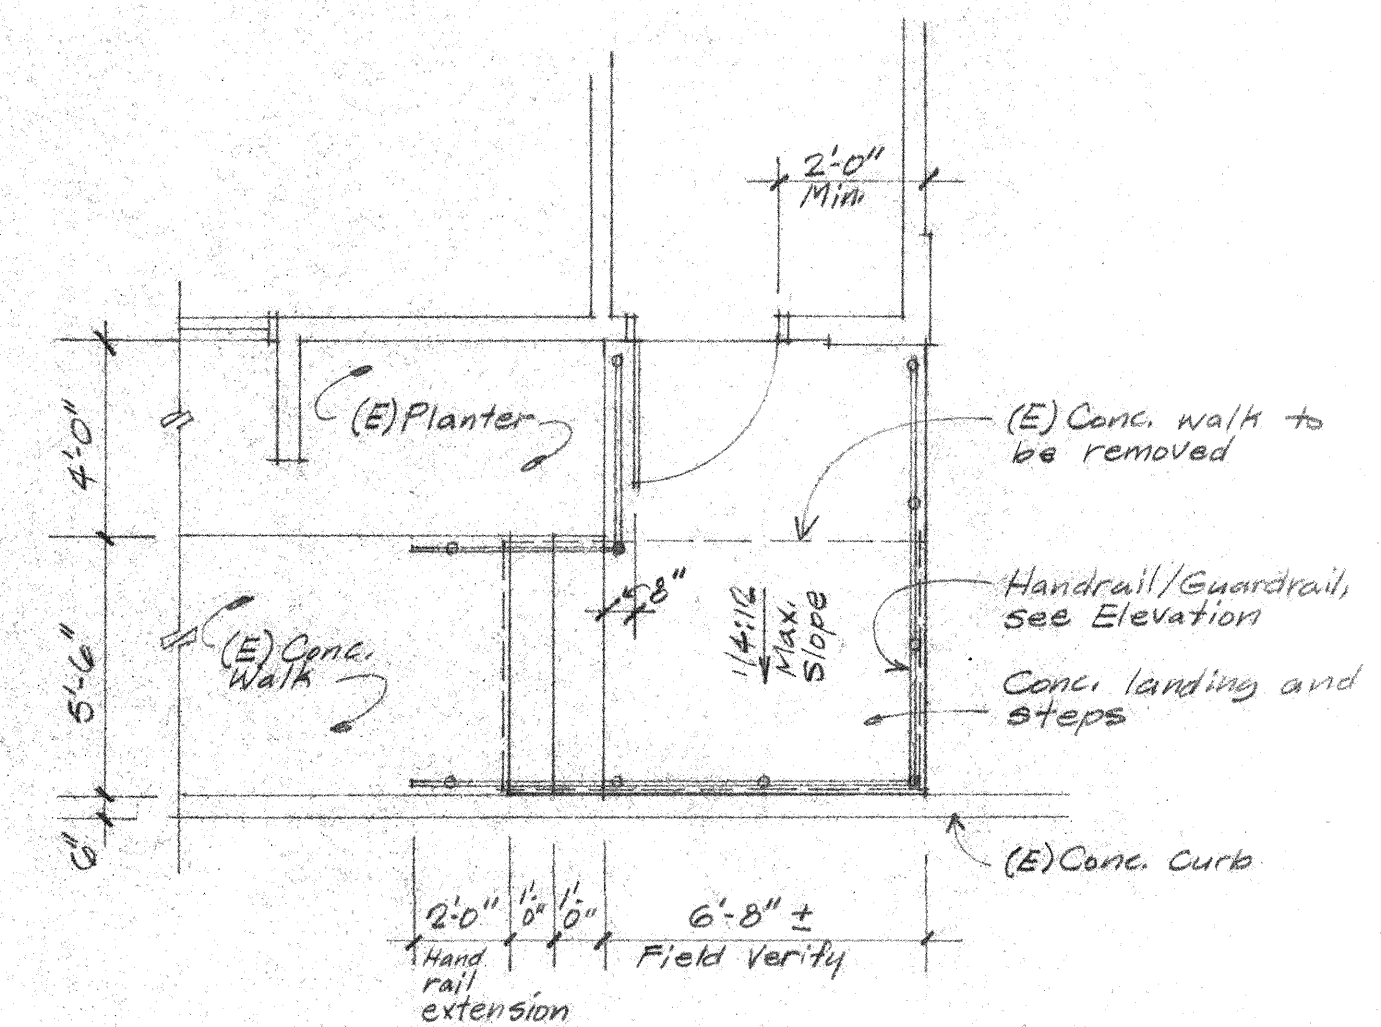


PLAN

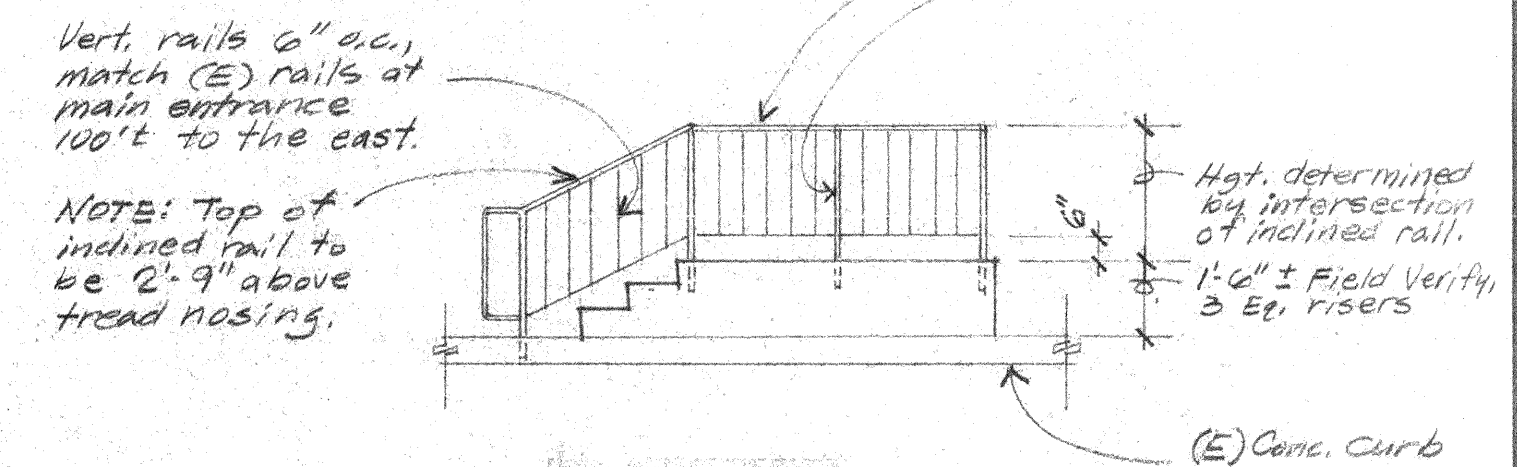

ELEVATION


Revisions to landing and handrail. Reference Plan Check #910776, VPC Foundation, Detail 14K/A5. All other notes and details apply.

14K EXTERIOR STAIRS AND LANDING 1/4"=1'-0"

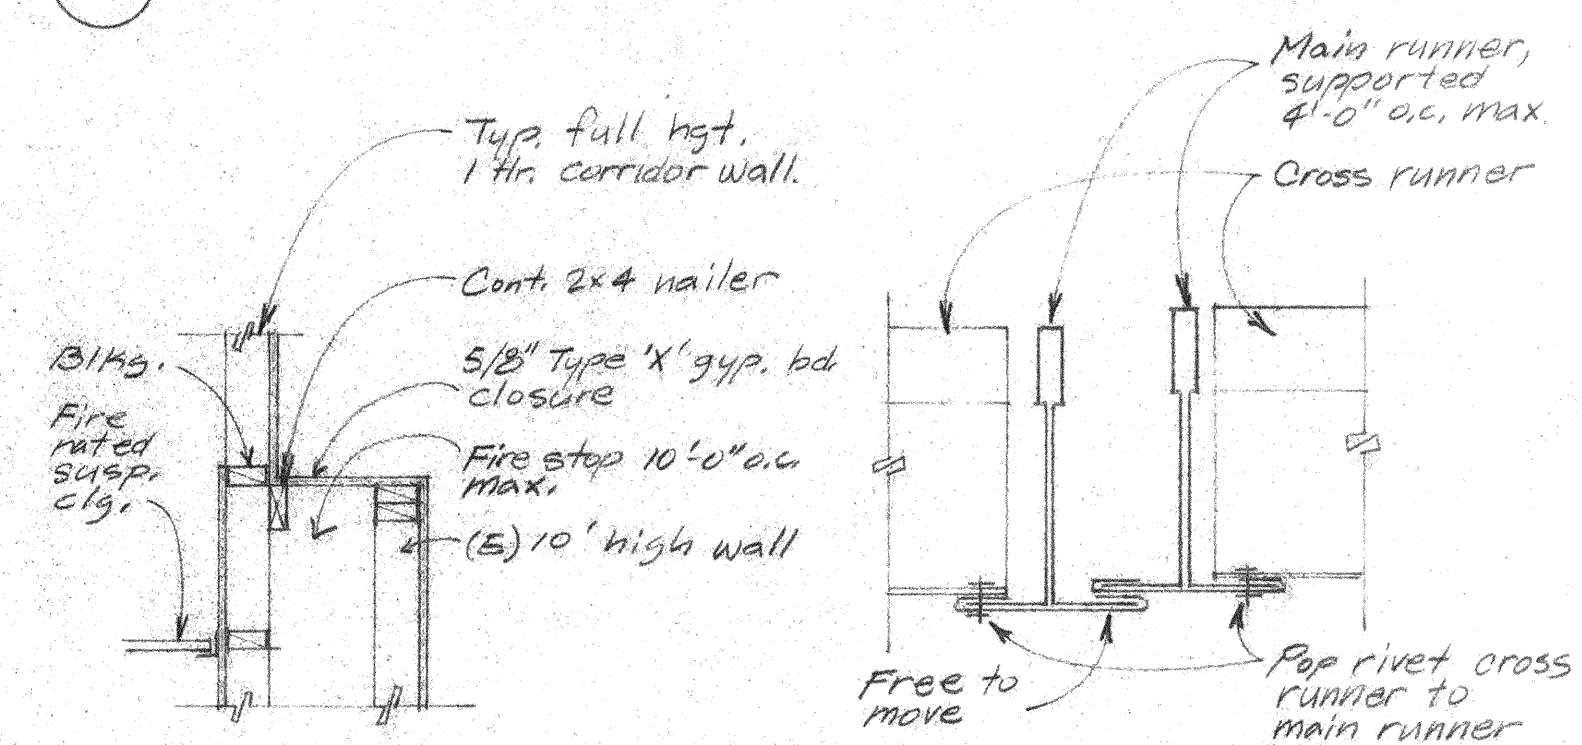

14H WALL SECTION 3/4"=1'-0"

16H CEILING INTERSECTION

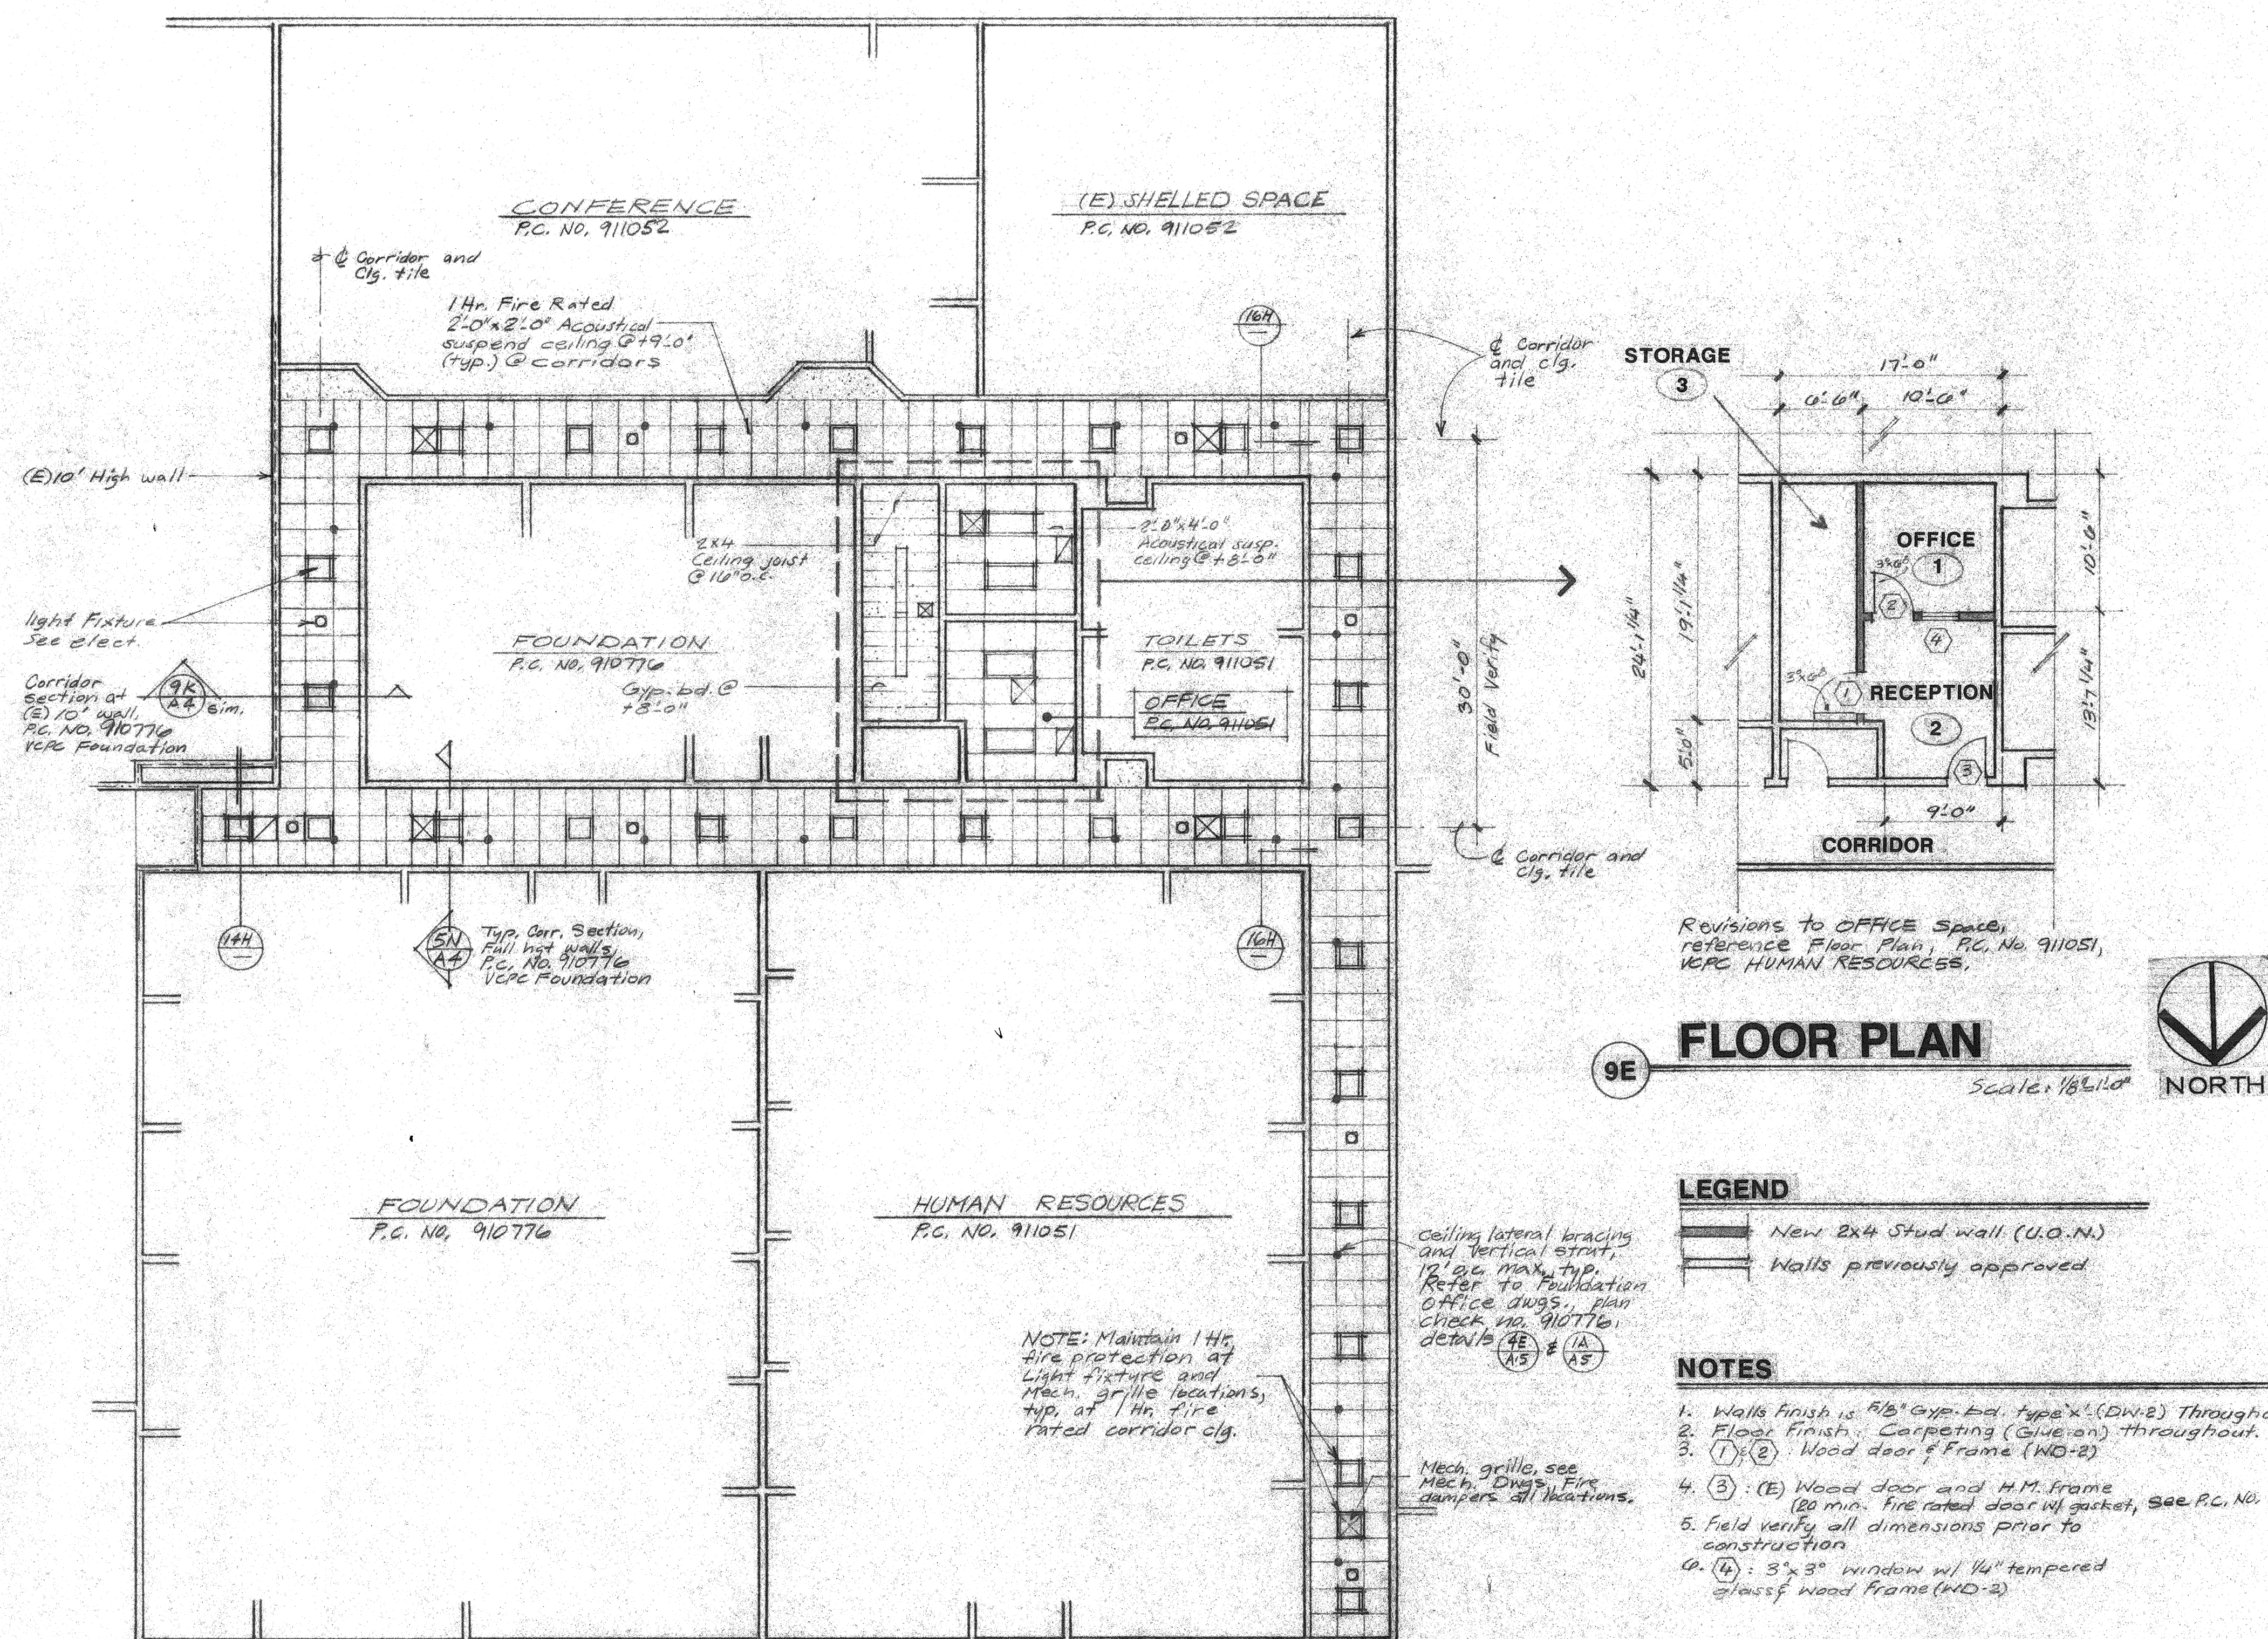

9E FLOOR PLAN Scale: 1/8"=1'-0"

LEGEND

- New 2x4 Stud wall (U.O.N.)
- Walls previously approved

NOTES

1. Walls Finish is 5/8" Gyp. bd. Type 'X' (DW-2) Throughout.
2. Floor Finish: Carpeting (Shaw-Wal) Throughout.
3. (1) (2) Wood door frame (WD-2)
4. (3) (E) Wood door and H.M. frame (20 min. fire rated door w/ gasket, see P.C. No. 911051)
5. Field verify all dimensions prior to construction.
6. (4) 3' x 3' window w/ 1/4" tempered glass w/ wood frame (WD-2)

1A REFLECTED CEILING PLAN Scale: 1/8"=1'-0"

DRAWING INDEX

CO1/A1 Plans and Details, Architectural
CO1/M1 AIR CONDITIONING PLAN
CO1/E1 LIGHTING PLAN, POWER PLAN,
SCHEDULES, SINGLE LINE.

No. Revisions/Submissions Date:

Edwin S. Darden Associates, Inc.
ARCHITECTURE AND PLANNING
Edwin S. Darden FAIA / Edwin S. Darden Jr. AIA
Martin E. Dietz AIA CCS / Edwin C. Goodwin AIA
1177 W. Shaw Avenue / Fresno, California 93711 / 209 222-7463
987 Oscar Street / San Luis Obispo, California 93401 / 805 543-3965

Consultant

FOUNDATION OFFICE, HUMAN RESOURCES OFFICE, AND CONFERENCE ROOM
VALLEY CHILDREN'S PROFESSIONAL CENTER
1990 EAST GETTYSBURG, FRESNO, CA
Project

CORRIDOR REFLECTED CEILING PLAN, OFFICE
FLOOR PLAN, AND DETAILS
Drawing

Designed By: Project No.: 9116A


Drawn By: Scale:


Checked By:

Reviewed By:


Date: Sheet: of:

CO1/A-1

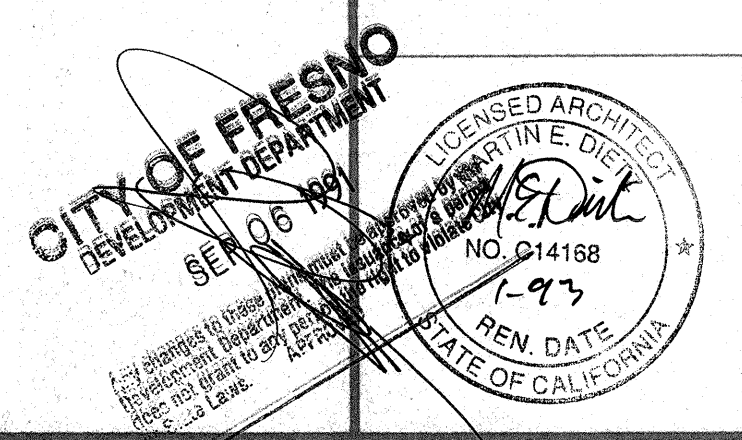

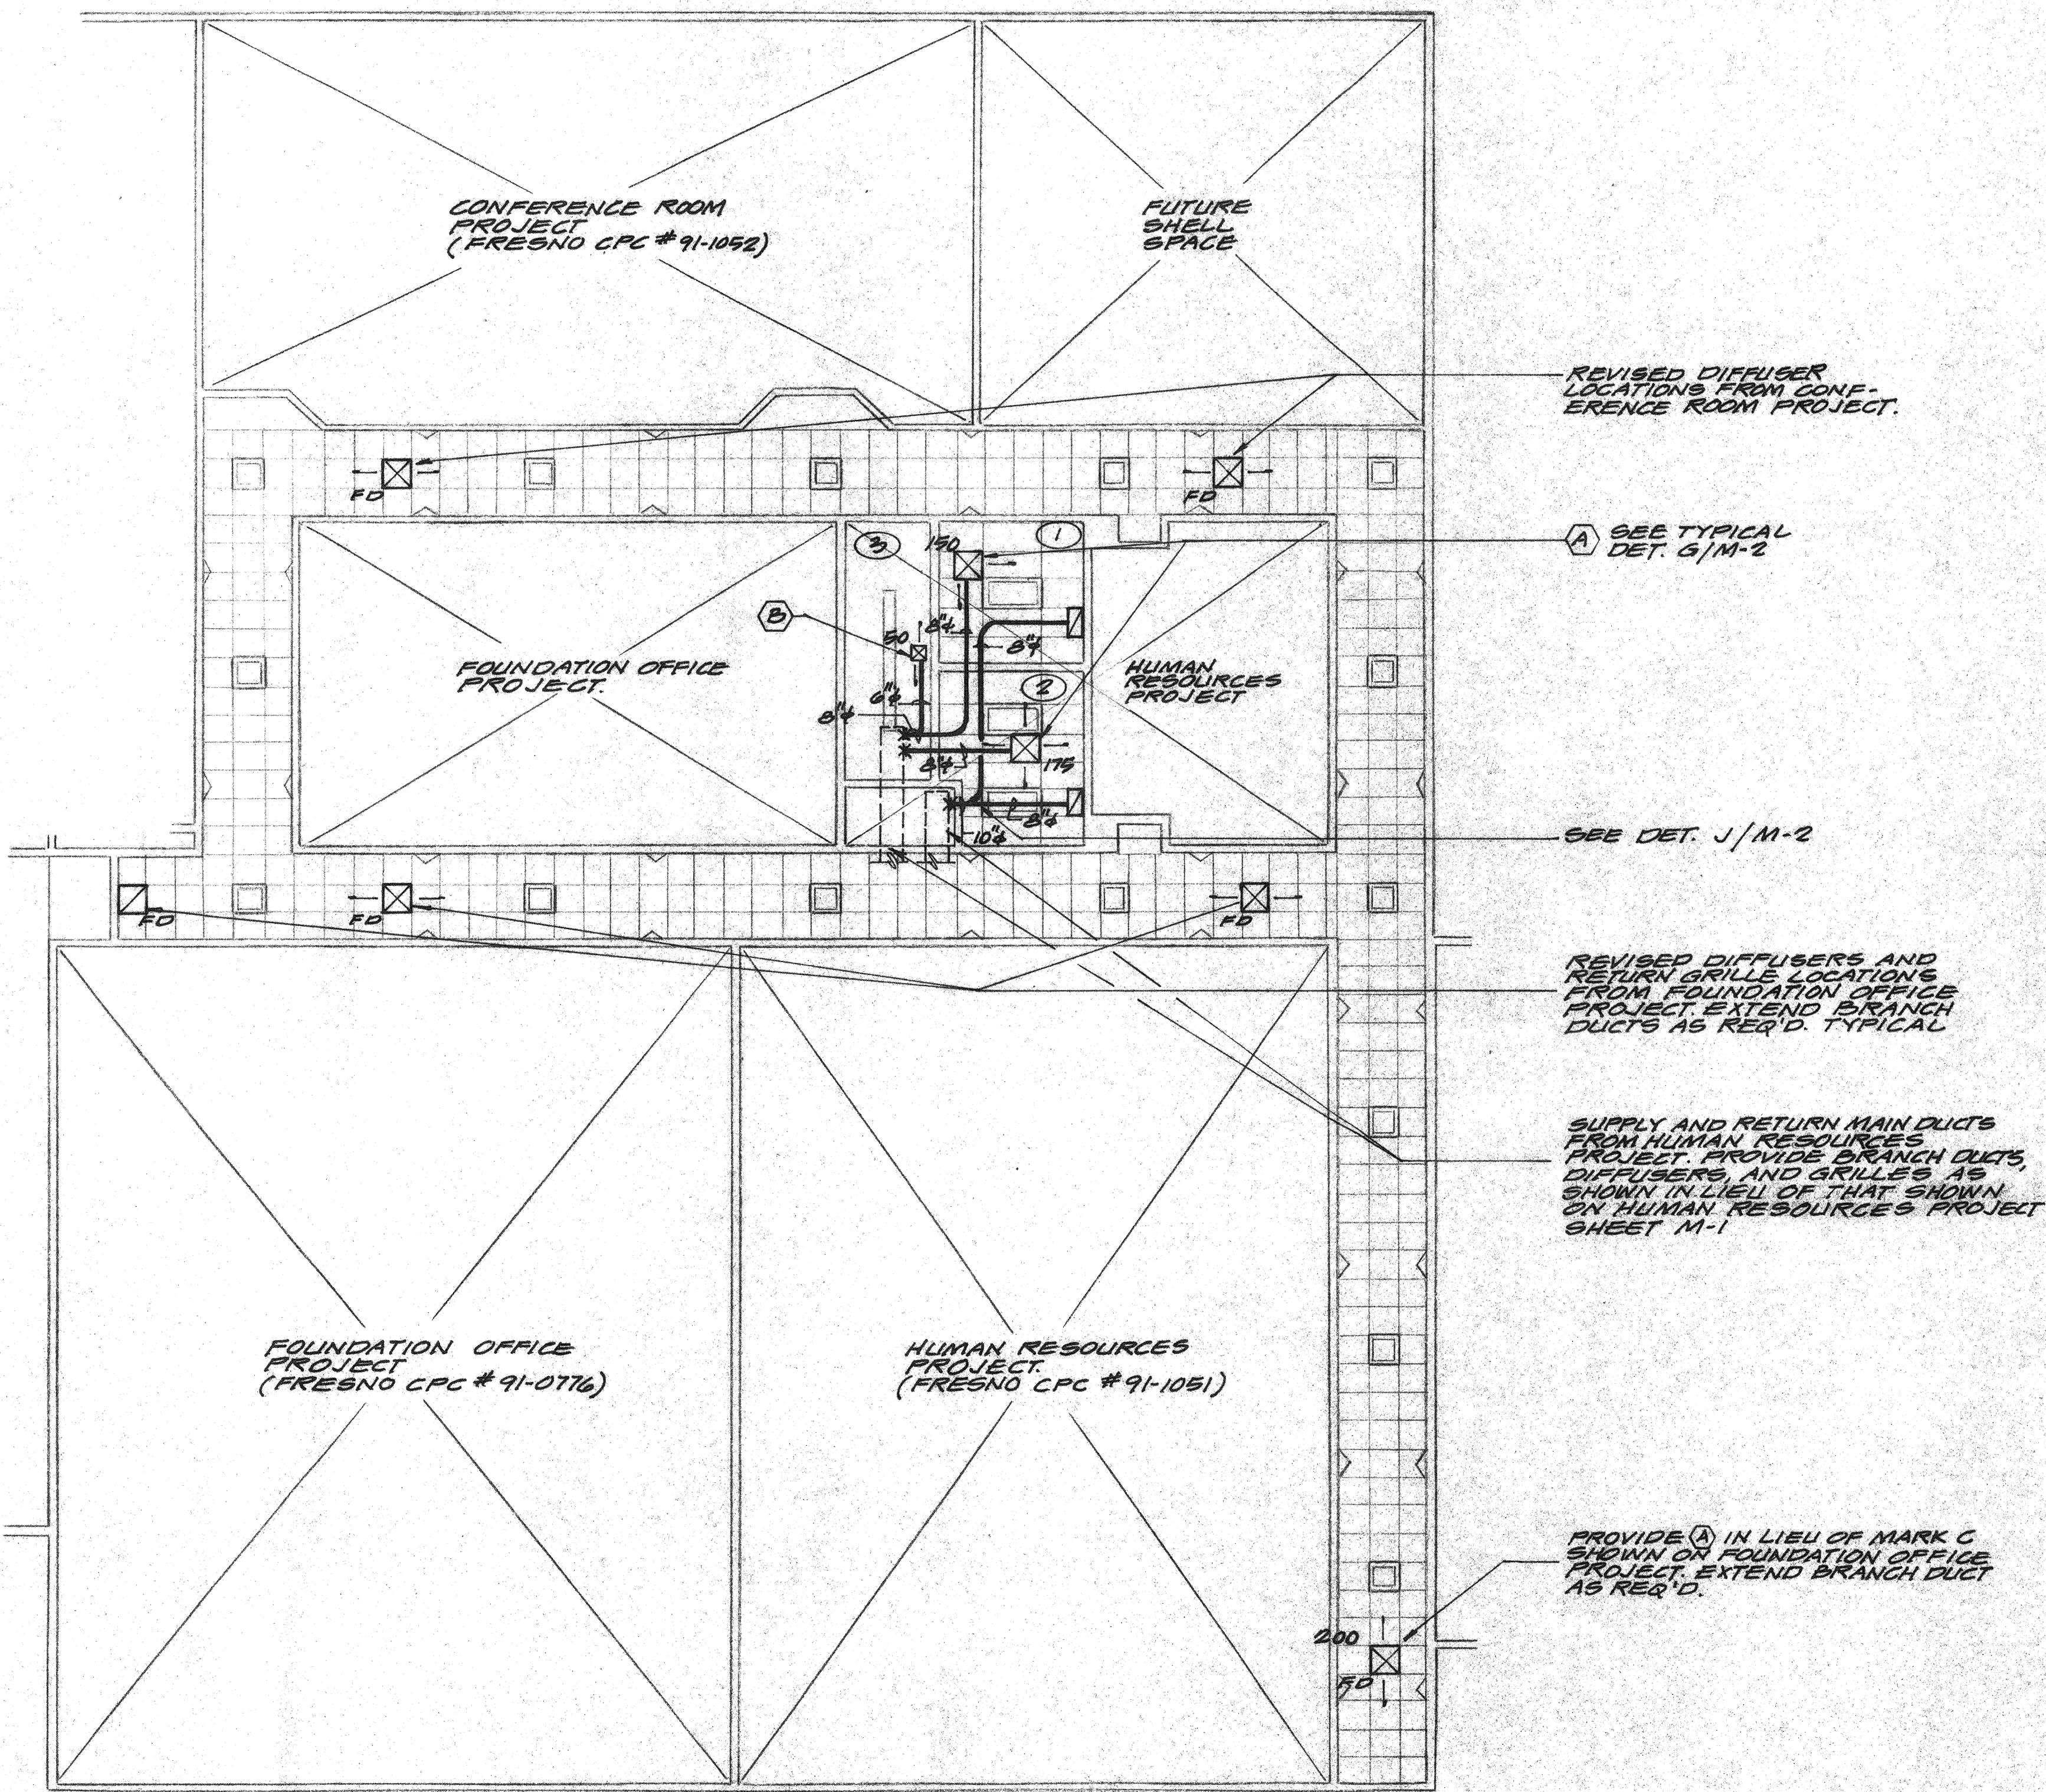

AIR CONDITIONING PLAN
SCALE 1/8"=1'-0"

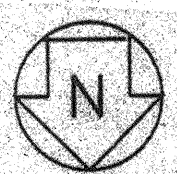

Note: GRILLE MARKS AND DETAIL REFERENCES ARE FROM HUMAN RESOURCES PROJECT. Plan Check No. 9/1051

GENERAL NOTES:
1. SPECIFICALLY OMITTED FROM THE SERVICES OF JOHN FRANK MITCHELL, INC., ARE ALL DESIGN AND CONSTRUCTION REVIEW SERVICES RELATING TO THE CONTRACTOR'S SAFETY PRECAUTIONS OR TO MEANS, METHODS, TECHNIQUES, SEQUENCES, OR PROCEDURES REQUIRED FOR THE CONTRACTOR TO PERFORM HIS WORK, BUT NOT RELATING TO THE FINAL OR COMPLETED STRUCTURE. OMITTED SERVICES INCLUDE BUT ARE NOT LIMITED TO SHORING, SCAFFOLDING, UNDERPINNING, TEMPORARY RETAINMENT OF EXCAVATIONS, ANY ERECTION METHODS AND BRACING.

AIR CONDITIONING LEGEND		
SYMBOL	ITEM	ABBR
	DUCT	
	DUCT WITH ACOUSTICAL LINING	
	SUPPLY AIR DUCT DROP	
	RETURN AIR DUCT DROP	
	SUPPLY AIR DUCT RISE	
	RETURN AIR DUCT RISE	
	TURNING VANES	
	EXTRACTOR	
	VOLUME CONTROL DAMPER	V.C.D.
	FIRE DAMPER WITH ACCESS PANEL	F.D.
	THERMOSTAT AT 42"-0"	
	DIRECTION OF FLOW	
	SUPPLY AIR	S.A.
	RETURN AIR	R.A.
	EXHAUST AIR	E.A.
	OUTSIDE AIR	O.A.
	EXISTING	(E)

No. _____

Revisions/Submissions _____

Date: _____

Edwin S. Darden Associates, Inc.
ARCHITECTURE AND PLANNING
Edwin S. Darden FAIA / Edwin S. Darden Jr. AIA
Martin E. Dietz AIA CCS / Edwin C. Goodwin AIA
1177 W. Shaw Avenue / Fresno, California 93711 / 209.222.7463
987 Ohio Street / San Luis Obispo, California 93401 / 805.943.3965

John Frank Mitchell, Inc.
ARCHITECT
1177 W. Shaw Avenue / Fresno, California 93711 / 209.222.7463
987 Ohio Street / San Luis Obispo, California 93401 / 805.943.3965

SEP 07 1991

SEP 07 1991

SEP 07 1991

FOUNDATION OFFICE, HUMAN RESOURCES OFFICE, AND CONFERENCE ROOM PROJECT

FOUNDATION OFFICE, HUMAN RESOURCES OFFICE, AND CONFERENCE ROOM PROJECT

FOUNDATION OFFICE, HUMAN RESOURCES OFFICE, AND CONFERENCE ROOM PROJECT

1900 EAST GERMANSBURG, FRESNO, CA

1900 EAST GERMANSBURG, FRESNO, CA

1900 EAST GERMANSBURG, FRESNO, CA

AIR CONDITIONING PLAN

AIR CONDITIONING PLAN

AIR CONDITIONING PLAN

MB

ACW

9/9

DATE

Designed By: _____

Drawn By: _____

Checked By: _____

Reviewed By: _____

Date: _____

Project No.: 9116 A

Scale: _____

COI/M-1

Sheet: / of: /

</

1819	
SHEET NOTES:	
1	EMERGENCY, BUT NOT FOR
2	LIGHT FIXTURES ARE TO BE INSTALLED IN ROOM 3 PLEASE AVOID THE EXISTING PROJECT
3	DELETE COMPUTER SPLITTER IN ROOM 19
4	DELETE ALL FIXTURES IN ROOM 19 WITH FIXTURES BAY. POSITION AND HEIGHT INDICATED.
5	REPOSITION AND RECIRCUIT EMERGENCY LIGHT FIXTURES INDICATED.
6	DELETE CIRCUITS 14 & 16, AND ALL ELECTRICAL DEVICES IN PREVIOUS ROOM 22. ADD DEVICES AND CIRCUITS IN ROOMS 3 & 3 AS INDICATED.
7	DELETE CIRCUIT 16 IN ROOM 20, AND RECIRCUIT DEVICES IN ROOMS 19 & 20 AS INDICATED.
8	75KVA TRANSFORMER 'TH' MOUNTED ON ROOF. SEE SINGLE LINE DIAGRAM, CONFERENCE ROOM PROJECT, AND DETAIL FOR RESOURCE OFFICE PROJECT.
9	DELETE LIGHT FIXTURES AA3, MB7 & 1E4 FROM PREVIOUS SCHEDULES.
10	REFER TO DETAIL N-1, SINGLE LINE DIAGRAM, SURFACE CONDUIT, ON ROOF, PER DETAIL K-1, TO (E) MAIN SWITCHBOARD 'MS1'.
11	PROVIDE FIXTURE WITH SELF CONTAINED BATTERY PACK.

J H G F E D C B A			
A-1		LIGHTING PLAN	
1/8"=1'-0"			
12345678910111213141516171819			
A-10		POWER & SIGNAL PLAN	
1/4"=1'-0"			
12345678910111213141516171819			

SYMBOL LEGEND	
INDICATES NUMBER OF DETAIL NOTE	
SUBSCRIPT LETTER ADJACENT TO SYMBOL INDICATES CONTROL	
NUMBER ADJACENT SYMBOL INDICATES CIRCUIT NUMBER ON PANELBOARD	
+24\"/>	
(E) EXISTING	
No. Revisions/Submissions Date:	
CITY OF FRESNO DEPARTMENT OF PUBLIC WORKS JUL 06 1991 Edwin S. Darden Associates, Inc. ARCHITECTURE AND PLANNING Edwin RAJA / Edwin S. Darden Jr. AIA Edwin RAJA / Edwin S. Darden Jr. AIA Edwin RAJA / Edwin S. Darden Jr. AIA 1177 W. Shaw Avenue / Fresno, California 93711 / 209 222-7463 887 Oaks Street / San Luis Obispo, California 93401 / 805 943-2985 Professional Engineers 4049 N. Fresno Street / Fresno, CA 93726 (209) 221-7230 Consultant VCH PROFESSIONAL CENTER CORRIDOR MODIFICATION Project LIGHTING PLAN, POWER PLAN, SCHEDULES, SINGLE LINE Drawing Designed By: Project No.: 9116 A Drawn By: Scale: NOTED Checked By: CO1/E-1 Reviewed By: Date: Sheet: of:	